

# LIFT STATION 12A ELECTRICAL PUMP & VFD REHABILIATION MANATEE COUNTY

PROJ. NO. 01024-0181 MARCH 17, 2021 ISSUED FOR BID

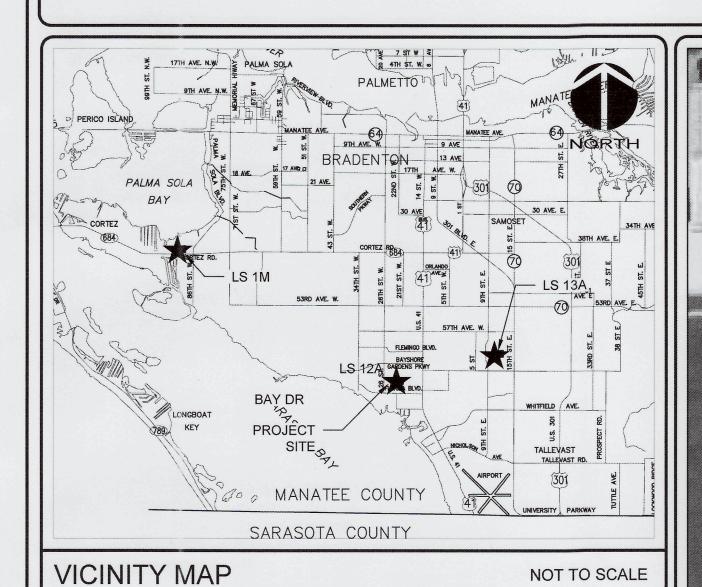

PROJECT NAME: LIFT STATION 12A ELECTRICAL PUMP & VFD

OWNER/DEVELOPER: 2007 BAY DRIVE BRADENTON, FLORIDA EMAIL

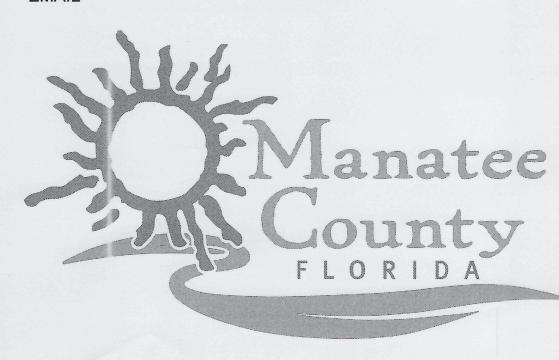



1365 Hamlet Avenue Clearwater, Florida 33756 Phone: (727) 442-7196, Fax: (727) 461-3827


SITE MAP

CA Lic. No. 29588 www.mckimcreed.com

PROJECT INFORMATION



Sheet Number	Sheet Title	
GENERAL		
G0.00	COVER SHEET	
G0.01	GENERAL NOTES	
G0.02	CIVIL-MECHANICAL- LEAD SHEET	
CIVIL: CIVIL SITE		
C0.00	SITE PLAN	
DEMOLITION		
D0.00	DEMOLITION OF EQUIPMENT I	
D0.01	DEMOLITION OF EQUIPMENT II	
MECHANICAL		
M0.00	PROPOSED PUMPS AND PIPING I	
M0.01	PROPOSED PUMPS AND PIPING II	
STRUCTURAL		
S00.0	STRUCTURAL GENERAL NOTES, DESIGN LOADS, CRITERIA & LEGEND	
S1.00	LIFT STA. MODS & ELECTR. BLDG. FDN. PLAN, SECTIONS & DETAILS	
S1.01	LIFT STA. MODS & ELECTR. BLDG. FRMG. PLAN, SECTIONS & DETAILS	
S1.02	LIFT STA. MODS ADD'L SECTIONS & DETAILS	
ELECTRICAL		
E0.00	SYMBOLS, ABBRIVIATIONS AND NOTES	
E0.01	SYMBOLS	
E0.02	SYMBOLS	
E1.00	DEMOLITION PLAN	
E1.01	SINGLE LINE DIAGRAM	
E1.02	ELECTRICAL SITE PLAN	
E1.03	ELECTRICAL PARTIAL SITE PLAN	
E1.04	ELECTRICAL BUILDING POWER PLAN	
E1.05	ELECTRICAL BUILDING LAYOUT	
E1.06	GROUNDING AND LIGHTNING PROTECTION PLAN	
E1.07	MCB, ATS AND MCC ELEVATIONS	
E1.08	LIGHTING PLAN	
E1.09	ELECTRICAL INTERCONNECTION DIAGRAM	
E1.10	PANEL BOARD SCHEDULES	
E1.11	DETAILS	
E1.12	ELECTRICAL CONTROLS SCHEMATICS	
INSTRUMENTATION		
10.00	INSTRUMENTATION SYMBOL SHEET 1	
10.01	INSTRUMENTATION SYMBOL SHEET 2	
11.00	PROCESS AND INSTRUMENT DIAGRAM	
11.01	CONTROL PANEL	

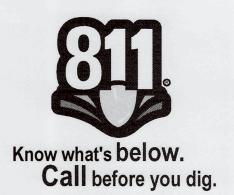

SCALE: 1" = 200'

SHEET INDEX

#### GENERAL NOTES

- 1. THE CONTRACTOR SHALL REVIEW AND VERIFY ALL LAYOUTS, DIMENSIONS AND ELEVATIONS ON THE PLANS WITH FINAL APPROVED EQUIPMENT DRAWINGS AS WELL AS ALL TECHNICAL SPECIFICATIONS PRIOR TO STARTING CONSTRUCTION AND SHOULD DISCREPANCIES OCCUR, THE CONTRACTOR SHALL NOTIFY THE ENGINEER TO OBTAIN THE ENGINEERS CLARIFICATION BEFORE COMMENCING WITH CONSTRUCTION.
- 2. THE CONTRACTOR SHALL COORDINATE ALL RELATED DISCIPLINE DRAWINGS TO ENSURE ACCURATE INSTALLATION OCCURS.
- 3. THESE PLANS ARE SOLELY TO ASSIST THE CONTRACTOR IN ASSESSING THE NATURE AND EXTENT OF THE EXISTING CONDITIONS WHICH MAY BE ENCOUNTERED DURING THE COURSE OF THE WORK. CONTRACTORS ARE DIRECTED TO CONDUCT WHATEVER INVESTIGATION THEY DEEM NECESSARY. PRIOR TO BIDDING, TO DETERMINE THE ACTUAL CONDITIONS THAT WILL BE ENCOUNTERED.
- 4. LOCATIONS, ELEVATIONS AND DIMENSIONS OF EXISTING UTILITIES, STRUCTURES, AND OTHER FEATURES ARE SHOWN BASED ON THE BEST INFORMATION AVAILABLE AT THE TIME OF PREPARATION OF THESE PLANS BUT DO NOT PURPORT TO BE ABSOLUTELY CORRECT. THE CONTRACTOR SHALL VERIFY, PRIOR TO CONSTRUCTION, THE LOCATIONS, ELEVATIONS, AND DIMENSIONS OF ALL EXISTING UTILITIES, STRUCTURES, AND OTHER FEATURES (WHETHER OR NOT SHOWN ON THE PLANS) AFFECTING HIS WORK.
- THE CONTRACTOR SHALL REVIEW AND VERIFY ALL DIMENSIONS ON THE PLANS AND REVIEW ALL FIELD CONDITIONS THAT MAY AFFECT CONSTRUCTION. SHOULD DISCREPANCIES OCCUR, THE CONTRACTOR SHALL NOTIFY THE ENGINEER TO OBTAIN WRITTEN CLARIFICATION BEFORE COMMENCING WITH CONSTRUCTION.
- THE CONTRACTOR SHALL PROTECT ALL EXISTING STRUCTURES, STORM DRAINS, SEWERS, UTILITIES, AND OTHER FACILITIES IN THE CONSTRUCTION AREA. THE CONTRACTOR SHALL REPAIR ANY DAMAGES DUE TO HIS CONSTRUCTION ACTIVITIES AT NO ADDITIONAL COST TO THE OWNER.
- 7. THE CONTRACTOR SHALL PROVIDE CERTIFIED RECORD DRAWINGS AS OUTLINED IN THE SPECIFICATIONS.
  RED-LINE DRAWINGS SHALL BE CURRENT WITH EACH PAY APPLICATION SUBMITTED AND WILL BE CHECKED
  AS PART OF THE PAY APPLICATION REVIEW PROCESS. PAYMENT WILL NOT BE MADE TO CONTRACTOR
  WITHOUT APPROVED RED-LINE DRAWINGS.
- 8. ALL PROPOSED WORK SHALL BE COORDINATED WITH MANATEE COUNTY UTILITIES DEPARTMENT AT LEAST TWO WEEKS IN ADVANCE OF PROPOSED CONSTRUCTION.
- 9. UNLESS OTHERWISE INDICATED OR APPROVED, ALL BELOW GROUND DUCTILE IRON AND PVC PIPE SHALL HAVE PUSH-ON OR MECHANICAL JOINTS, AND ALL ABOVE GROUND DUCTILE IRON PIPE SHALL HAVE FLANGED JOINTS. ALL JOINTS SHALL BE FULLY RESTRAINED.
- 10. WATER SHALL NOT BE PERMITTED IN EXCAVATIONS AND TRENCHES DURING CONSTRUCTION. DEWATERING IS REQUIRED TO A MINIMUM OF 18" BELOW BOTTOM OF EXCAVATION.
- 11. THE CONTRACTOR SHALL NOT ALLOW ANY DISCHARGE OF WASTEWATER TO LANDS AND/OR ADJACENT WATER BODIES OR STORM DRAINS. ANY LEAKAGE MUST BE CONTAINED AND TRANSFERRED BY THE CONTRACTOR TO THE PLANT DRAIN PUMP STATION AT THE WASTEWATER TREATMENT PLANT.
- 12. ALL EXPOSED NEW PIPING SHALL BE PAINTED WITH DESIGNATED COLORS ASSOCIATED WITH THEIR USAGE AS PROVIDED IN THE SPECIFICATIONS.
- 13. ALL NEW PIPELINES SHALL BE FLUSHED, PRESSURE TESTED, AND APPROVED PRIOR TO TIE-INS TO EXISTING FACILITIES. THE CONTRACTOR WILL BE ALLOWED TO USE TEMPORARY PLUGS FOR PRESSURE TESTING.
- 14. ALL CONCRETE THRUST BLOCKS INSTALLED FOR TESTING PURPOSES AND NOT REQUIRED FOR THE PIPELINE SHALL BE REMOVED AND DISPOSED OF BY THE CONTRACTOR PRIOR TO FINAL ACCEPTANCE.
- 15. CONTRACTOR SHALL PROVIDE PROTECTIVE MATTING, FUEL CONTAINMENT AND ALL OTHER MATERIALS, EQUIPMENT AND LABOR TO PROTECT THE STAGING AREA DURING CONSTRUCTION.
- 16. CONTRACTOR SHALL, PRIOR TO BEGINNING CONSTRUCTION, SUBMIT A "FUELING SPILL PREVENTION PLAN"
  THAT SHALL CLEARLY INDICATED HOW FUEL SPILLS WILL BE PREVENTED WHEN FUELING BOTH WITHIN AND
- OUTSIDE OF THE STAGING AREA.

  17. CONTRACTOR SHALL EMPLOY A PROFESSIONAL SURVEYOR, LICENSED IN THE STATE OF FLORIDA TO PERFORM CONSTRUCTION STAKING IN ACCORDANCE WITH RULE 61G17—6.004 (3) OF THE FLORIDA ADMINISTRATIVE CODE.
- 18. JOINT RESTRAINT SHALL BE INSTALLED AS NECESSARY TO PREVENT MOVEMENT OF EXISTING UNRESTRAINT PRESSURE PIPE AT ALL TIE-IN LOCATIONS WHETHER SPECIALLY IDENTIFIED ON THE PLANS OR NOT.
- 19. ALL WORK, EQUIPMENT AND MATERIALS SHALL MEET OR EXCEED CURRENT MANATEE COUNTY STANDARDS, UNLESS OTHERWISE STATED IN CONTRACT DOCUMENTS.

#### **RESTORATION AND MISCELLANEOUS NOTES:**

- 1. THE CONTRACTOR SHALL PROVIDE AN ASPHALT PATCH FOR TRENCH AREAS CONSTRUCTED IN EXISTING ROADWAYS UNLESS INDICATED OTHERWISE ON THE DRAWINGS. ADJUST ALL CASTINGS TO MATCH NEW PAVEMENT SURFACE.
- 2. WHERE SURFACE IMPROVEMENTS ARE TO BE REPLACED IN KIND, AS INDICATED ON THE DRAWINGS, THE CONTRACTOR SHALL REPLACE ALL EXISTING PAVING, STABILIZED EARTH, CURBS, SIDEWALKS, FENCES, LANDSCAPING AND OTHER IMPROVEMENTS WITH THE SAME OR BETTER TYPE OF MATERIAL THAT WAS REMOVED DURING CONSTRUCTION OR AS DIRECTED BY THE ENGINEER.
- 3. ALL RESTORATION WORK PERFORMED THROUGHOUT THE PROJECT SHALL CONFORM TO EXISTING LINES AND GRADES UNLESS OTHERWISE NOTED.
- 4. ALL EXISTING FENCES DISTURBED DURING CONSTRUCTION SHALL BE REPLACED AND REINSTALLED BY THE CONTRACTOR AT NO ADDITIONAL COST TO THE OWNER UNLESS SHOWN TO BE REMOVED ON CONSTRUCTION PLANS.
- 5. CONTRACTOR SHALL RESTORE GRADE PRECONSTRUCTION ELEVATIONS UNLESS OTHERWISE NOTED.

#### 6. SOIL EROSION & SEDIMENTATION CONTROL NOTES:

- 1. ALL SOIL EROSION AND SEDIMENTATION CONTROL MEASURES SHALL BE IN PLACE PRIOR TO THE START OF ANY CONSTRUCTION, DEMOLITION, DEWATERING, OR MOBILIZATION ACTIVITIES, MAINTAINED THROUGHOUT CONSTRUCTION AND SHALL REMAIN IN PLACE UNTIL WORK IS COMPLETE.
- 2. CONTRACTOR SHALL FOLLOW BEST MANAGEMENT PRACTICES THROUGHOUT DEMOLITION AND CONSTRUCTION.
- 3. HAY BALES AND/OR SILT SCREENS SHALL BE INSTALLED ADJACENT TO THE WORK AREAS TO PREVENT
- SEDIMENT TRANSPORT PRIOR TO THE COMMENCEMENT OF WORK.

  4. INLET PROTECTION SHALL BE PLACED AT ALL INLETS IN OR ADJACENT TO THE PROJECT AREA.
- 5. AS SOON AS PRACTICAL, ALL DRESSED SLOPES AND DISTURBED AREAS SHALL BE SODDED OR SEEDED AND MULCHED TO PREVENT EROSION.
- 6. NO EXCAVATION SHALL EXTEND BELOW THE DEPTHS/ELEVATIONS SHOWN ON THE DRAWINGS OR IN THE SPECIFICATIONS WITHOUT PRIOR APPROVAL.
- 7. CONTRACTOR SHALL PREPARE AND SUBMIT A STORM WATER POLLUTION PLAN (SWPPP) FOR REVIEW AND APPROVAL PRIOR TO COMMENCEMENT OF ANY CONSTRUCTION ACTIVITIES AND PROVIDE APPROVED FDEP NOT TO COUNTY.
- CONTRACTOR SHALL PREPARE AND SUBMIT A DISPOSAL PLAN FOR EXCAVATION MATERIAL INCLUDING THE LOCATION OF DISPOSAL SITE(S) AND DISPOSAL PLANS SHOWING APPLICABLE BEST MANAGEMENT PRACTICES FOR REVIEW AND APPROVAL PRIOR TO ANY EARTHWORK ACTIVITIES.

#### PLANT WORK NOTES

- . CONTRACTOR SHALL MAINTAIN A CLEAR PATH FOR ALL SURFACE WATER DRAINAGE STRUCTURES AND DITCHES DURING CONSTRUCTION.
- 2. ALL PIPE LINES SHALL HAVE A MINIMUM COVER OF 36" UNLESS OTHERWISE NOTED OR DIRECTED.
- 3. NOTE; ALL VAULTS, MANHOLES, INLET STRUCTURES, BASINS, WET WELLS ETC. SHALL BE CONSIDERED "CONFINED SPACE ENTRY" AND SHALL BE MARKED AS SUCH BY MEANS OF STAMPING MANHOLE COVERS AND PLACING PERMANENT SIGNAGE ON THE VAULTS, BASINS OR STRUCTURES WARNING OF THE "CONFINED SPACE ENTRY" CONDITION.
- 4. CONTRACTOR SHALL BE RESPONSIBLE FOR ALL PIPE SUPPORTS WHETHER SHOWN ON THE CONTRACT DOCUMENTS OR NOT. PIPE SUPPORTS SHALL BE INSTALLED PER MANUFACTURER'S RECOMMENDATIONS FOR SPACING AND SUPPORT. ADDITIONALLY, PROVIDE SUPPORT WHERE ABOVE GRADE PIPING CHANGES DIRECTION, IS ADJACENT TO FLANGED VALVES OR OTHER APPURTENANCES OR AT EQUIPMENT CONNECTIONS AND HEAVY FITTINGS.
- 5. NOTE: ALL NON-POTABLE/PLANT WATER USERS MUST BE CLEARLY LABELED AS "NON-POTABLE", NOT FOR HUMAN CONSUMPTION.
- 6. PLANT TRAFFIC FLOW SHALL BE MAINTAINED AT ALL TIMES DURING CONSTRUCTION. IF TRAFFIC FLOW IS TO BE RE—DIRECTED, CONTRACTOR SHALL COORDINATE TEMPORARY TRAFFIC FLOW PATTERNS WITH OWNER AND ENGINEER.
- 7. CONTRACTOR SHALL RESTRAIN ALL UNDERGROUND PRESSURE PIPING AT ALL FITTINGS AND PIPE JOINTS.

#### **EXISTING UTILITY NOTES**

- I. UNDERGROUND UTILITIES SHOWN ON THE PLANS HAVE BEEN MADE AVAILABLE FROM VARIOUS ENTITIES THAT MAY INCLUDE UTILITY OWNERS, SURVEY SUBSURFACE UTILITY INVESTIGATIONS (SUE), RECORD DRAWINGS AND OTHERS. THIS INFORMATION MAY NOT ALL—INCLUSIVE AND THE CONTRACTOR IS ADVISED THAT ADDITIONAL UNDERGROUND UTILITIES AND CABLES INVESTIGATION MAY BE NECESSARY PRIOR TO STARTING CONSTRUCTION. THE CONTRACTOR SHALL NOTIFY THE ENGINEER OF RECORD IMMEDIATELY OF ALL POTENTIAL CONFLICTS.
- 2. THE CONTRACTOR SHALL FIELD VERIFY SIZE, DEPTH, LOCATION AND MATERIAL OF ALL UNDERGROUND UTILITIES PRIOR TO THE START OF CONSTRUCTION.
- 3. THE CONTRACTOR SHALL CAREFULLY SUPPORT AND PROTECT ANY UTILITIES, STRUCTURES, POWER POLES, PIPE LINES AND CONDUITS WHICH MAY BE ENCOUNTERED DURING COMPLETION OF THE WORK AT NO ADDITIONAL COST TO THE OWNER. THE CONTRACTOR SHALL APPLY NECESSARY MEANS TO PROTECT EXISTING UTILITIES DURING CONSTRUCTION. ANY DAMAGE RESULTING FROM THE CONTRACTOR'S OPERATIONS SHALL BE REPAIRED BY THE CONTRACTOR OR UTILITY OWNER (WHERE REQUIRED) TO THE SATISFACTION OF THE ENGINEER AND UTILITY OWNER AT THE CONTRACTOR'S EXPENSE.

#### AS NEEDED NOTES

\_

DESCRIPTION

DESCRIPTION

DESCRIPTION

DATE

NO 66861

1365 Hamlet Avenue Clearwater, Florida 33756

Phone: (727) 442-7196, Fax: (727) 461-3827

CA Lic. No. 29588 www.mckimcreed.com



LIFT STATION 12A ELECTRICAL PUMP & VFD REHABILITATION

GENERAL NOTES

-	PROJ. START DATE:	2020. JUN
	MCE PROJ. #	01024-0181
	DRAWN	JG
	DESIGNED	AAH
	CHECKED	MAC
	PROJ. MGR.	AAH
,		

SCALE

HORIZONTAL:
N/A
VERTICAL:
TBD

ORAWING NUMBER

ORAWING NUMBER

ISSUED FOR BID

STATUS:

#### **ABBREVIATIONS** 1 STORY FRAMED DWELLING 1SBKBUS 1 STORY BRICK BUSINESS ASBESTOS CEMENT AL OR ALUM ALUMINUM AIR RELEASE VALVE ASPHALT BACK OF CURB BUTTERFLY VALVE BLIND BOLLARD BLOW OFF VALVE BALL VALVE CABLE TELEVISION CATV CATCH BASIN C&G CURB AND GUTTER CHAIN CURB INLET CENTERLINE CORRUGATED METAL PIPE CONCRETE MASONRY UNIT CLEAN OUT CONCENTRIC CONCRETE COUPLING CORRUGATED PLASTIC PIPE COMPOST SOCK COMBO SILT / TREE PROTECTION FENCE CHECK VALVE CWTD CLEAN WATER TEMPORARY DIVERSION DROP INLET / DUCTILE IRON DUCTILE IRON PIPE DUCT BANK DRIVE WAY DRAWING EL OR ELEV ELEVATION EDGE OF GRAVEL END OF INFORMATION EP, EOP EDGE OF PAVEMENT EYEWASH EXISTING **EXPANSION** LIGHT POLE FLANGE COUPLING ADAPTER FLOOR DRAIN FIRE DEPARTMENT CONNECTOR FINISHED FLOOR ELEVATION FIRE HYDRANT FIRE HYDRANT ASSEMBLY FINISHED FLANGE **FLEXIBLE** FLOOR FORCE MAIN FIBERGLASS REINFORCED PIPE FIBER OPTIC FLAT ON TOP GUTTER LINE GAS METER GRAV GRAVEL GAS TEST STATION GAS VALVE GATE VALVE GUY WIRE HOSE BIB нот вох HIGH-DENSITY POLYETHYLENE HIGH POINT HIGH WATER LEVEL INVERT ELEVATION IRON POST FOUND JUNCTION BOX LINEAR FEET LIMITS OF DISTURBANCE LOW POINT LONG RADIUS LANDSCAPE AREA LOW WATER LEVEL MAIL BOX MAXIMUM MANHOLE MINIMUM MECHANICAL JOINT MOTOR OPERATED VALVE NORMALLY CLOSED NORMALLY OPEN NOT IN CONTRACT NORMAL WATER LEVEL OHE/OE OVER HEAD ELECTRIC OVERFLOW OVER HEAD UTILITIES PLAIN END POST INDICATOR VALVE POLYMER POWER POLE PRESSURE REDUCING VALVE POLYTETRAFLUOROETHYLENE PLUG VALVE POLY VINYL CHLORIDE POTABLE WATER REINFORCED CONCRETE PIPE PER RECORD REDUCER

1	ABBREVIATIONS CONTINUED	
RFCA	RESTRAINED FLANGE COUPLING ADAPTER	
RJ	RESTRAINED JOINT	
RK	ROCK	
R/W, RO	OW RIGHT OF WAY	
S	SIGN	
SDMH	STORM DRAIN MANHOLE	
SF	SILT FENCE	
SS	SANITARY SEWER	
S.S.	STAINLESS STEEL	
SSF	SUPER / HIGH HAZARD SILT FENCE	
SSMH	SANITARY SEWER MANHOLE	
STA	STATION	
SUE	SUBSURFACE UTILITY ENGINEERING	
s/W	SIDE WALK	
SVC	SERVICE	
TBM	TEMPORARY BENCH MARK	
TC	TERRA COTTA	
TLP	TRAFFIC LIGHT POLE	
TOB	TOP OF BANK	
TOC TOP OF CONCRETE		
TOG		
TOS	TOP OF SLAB	
TOW	TOP OF WALL	
TH	TEST HOLE	
TPF	TREE PROTECTION FENCE	
TSBOX	TRAFFIC SIGNAL BOX	
TYP	TYPICAL	
UNO UNLESS NOTED OTHERWISE		
UNK		
VAR VARIABLE		
VCP	VITRIFIED CLAY PIPE	
WD	WOOD	
WL WATER LINE		
WL WM	WATER LINE WATER METER	

WATER VALVE

YARD INLET

DESCRIPTION

11.25° HORIZONTAL BEND 22.50° HORIZONTAL BEND

45° HORIZONTAL BEND

90° HORIZONTAL BEND

AC UNIT

BENCH MARK

TEMP. BENCH MARK

BLOW OFF VALVE

BOLLARD

TEST BORE HOLE LOCATION

CABLE TV PEDISTAL

CATCH BASIN

CLEAN OUT

CONCRETE MONUMENT FOUND

CONTROL POINT

CROSS

CURB INLET

ELECTRIC BOX

ELECTRIC MANHOLE

END OF INFORMATION

FLAG POLE

GAS METER

GUY POLE

**GUY WIRE** 

HANDHOLE

**HYDRANT** IRON POST FOUND

IRON ROD FOUND

LIGHT POLE

MAIL BOX

MONITOR WELL

POWER POLE

WATER MANHOLE

PK FOUND

RAIL ROAD SPIKE

SANITARY SEWER MANHOLE

SHRUB

SIGN

STORM DRAIN MANHOLE

TAPPING SLEEVE AND VALVE

TEE

TELEPHONE MANHOLE

TELEPHONE PEDESTAL

TRAFFIC SIGNAL BOX

TRANSFORMER

DECIDUOUS TREE

PINE TREE

UTILITY POLE

VALVE

WATER METER

WATER WELL

YARD HYDRANT

CROSS LIGHT POLE WELDED WIRE FABRIC

**EXISTING SYMBOL LEGEND** 

SYMBOL

H

H

•

0

MO

OBO

000

□ CMF

•

OFP

GM()

-0

HH

OIPF

OIPF

OLP

OPP

W

OPKF

**O RRSPIKE** 

\_\_\_\_

0

 $\bowtie$ 

**(W)** 

8.9

MBD

	DESCRIPTION	LINETYPE
	UNDERGROUND CABLE TV	TV
UNDE	RGROUND PER RECORD CABLE TV	TV(R)-
		E
PER		E(R)-
		FO
PER R		FO(R) $-$
PER RE		FM(R)
		G
Ul		
	OVER HEAD UTILITIES	OU
DED		
PER	~~~~~~~~~~~~~~~~~~~~~~~~~~~~~~~~~~~~~~~	
DED	RECORD GRAVITY SANITARY SEWER	
I LIV	STORM DRAINAGE	
		T
UNDF		T(R)
01102		U
	WATER LINE -	w
		W(R)-
	FENCE -	× ×
	GUARD RAIL -	0 0
	BACK OF CURB	
	EASEMENT -	
	EDGE OF GRAVEL	
	EDGE OF PAVEMENT -	
	PROPERTY LINE	***************************************
	RIGHT OF WAY	*******************
	ROAD CENTER LINE	
	100 YEAR FLOODPLAIN	100FP
	DITCH ©	
	MAJOR CONTOUR	
	MINOR CONTOUR	wg 4
	RIPARIAN BUFFER ZONE 1 RIPARIAN BUFFER ZONE 2	
	TOP OF BANK	7.2
	TREELINE	
	WATERCOURSE &	6
	WETLAND BOUNDARY	

4	PROPOSED SYMB	OL LEGEN
	DESCRIPTION	SYMBOL
***************************************	11.25° HORIZONTAL BEND	H
***************************************	22.50° HORIZONTAL BEND	4
	45° HORIZONTAL BEND	4
	90° HORIZONTAL BEND	4
	VERTICAL BEND	II
	AIR RELEASE VALVE	(A)
	VALVE	H
	BLOWOFF VALVE	He
	HYDRANT	·Op
	YARD HYDRANT	छ
	CROSS	田
	TEE	<b></b>
Т	APPING SLEEVE AND VALVE	墨
	REDUCER	•
CAP/PLUG		
POTABLE WATER SERVICE METER		W
RECLAIMED WATER SERVICE METER		R
EXISTIN	G UTILITY SERVICE RECONNECTION	(
CONCE	NTRIC SANITARY SEWER MANHOLE	0
ECCEN	TRIC SANITARY SEWER MANHOLE	© • • • • • • • • • • • • • • • • • • •
FLAT	TOP SANITARY SEWER MANHOLE	0
	CLEAN OUT	•
	ARC FILTER	8
	CHECK DAM	<b>(4)</b>
	INLET PROTECTION	
	PIPE INLET PROTECTION	
SILT FENCE OUTLET		<b>250</b>
	WATTLE	00
5	PROPOSED LINE I	EGEND
	DESCRIPTION	LINETYPE

5	PROPOSED LINE L	EGEND
	DESCRIPTION	LINETYPE
	PERMANENT EASEMENT	
	TEMPORARY EASEMENT	
SA	NITARY SEWER FORCE MAIN	——-FM-——
	RECLAIMED WATER LINE	R
	GRAVITY SANITARY SEWER	
	WATER LINE	—— W ——
	TO BE ABANDONED	· /· /· /· /· /· /· /· /· /· /·
	DIVERSION DITCH	$\rightarrow \longrightarrow$
	OF DISTURBANCE/CLEARING LIMITS	
COMBINAT	TION SILT FENCE/TREE PROTECTION	CSF
	TEMPORARY SILT FENCE	SF
	MPORARY SUPER SILT FENCE	SSF
TEMPO	PRARY TREE PROTECTION FENCE	———TPF———
	COMPOST SOCK	cs
	PERMANENT FENCE	<del></del>
	GUARD RAIL	

### PROFILE LINE LEGEND

	T
DESCRIPTION	LINETYPE
 EXISTING GRADE PAVEMENT PROFILE	
EXISTING GRADE GROUND PROFILE	
PROPOSED GRADE PROFILE	
THEORETICAL 1:1 SLOPE	
WETLAND CROSSING	

### AREA LEGEND

A PROCESS AIR

BW BACKWASH

ALUM WTP ALUM SLUDGE

AS ACTIVATED SLUDGE

BWD BACKWASH DRAIN

BWS BACK WASH SUPPLY

-		
	WETLANDS	\(\psi\) \(\
	RIP-RAP	
	TEMP. SLOPE STABILIZATION	+ + + + + + + + + + + + + + + + + + +
	STRAW WITH NET LINER	

## PROCESS ABBREVIATIONS

D 44.2	DACK WASII SOFFEI
BWW	BACK WASH WASTE
D	DRAIN
EXP	EXPANSION
FA	FOUL AIR
FE	FINAL EFFLUENT
FI	FILTER INFLUENT
FFM	FILTRATE FORCE MAIN
FTD	FILTER DRAIN
FTE	FILTER EFFLUENT
GR	GRIT
GV	GATE VALVE
HWR	HOT WATER RETURN
HWS	HOT WATER SUPPLY
IFM	INFLUENT FORCE MAIN
ML	MIXED LIQUOR
NAOCL	SODIUM HYPOCHLORITE
NAOH	SODIUM HYDROXIDE (CAUSTIC SODA)
NG	NATURAL GAS
NPW	NON-POTABLE WATER
NRCY	NITRIFIED RECYCLE
PD	PROCESS DRAIN
PE	PRIMARY EFFLUENT
PS	PRIMARY SLUDGE
PTE	PRELIMINARY TREATMENT EFFLUENT
PTFE	POLYTETRAFLUOROETHYLENE
PW	POTABLE WATER
RAS	RETURN ACTIVATED SLUDGE
RW	RAW WASTEWATER
SBR	SEQUENCING BATCH REACTOR
SD	STORM DRAIN
SPD	SUMP PUMP DISCHARGE
SR	SCRUBBER RECIRCULATION
SRD	SCRUBBER RECIRCULATION DISCHARGE
SRP	SCRUBBER RECIRCULATION PUMP
SRS	SCRUBBER RECIRCULATION SUCTION
SUP	DIGESTER SUPERNATANT
SW	SEAL WATER
UV	ULTRAVIOLET
0 1	OL HVAVIOLE I

#### 10 GENERAL NOTES

#### **GENERAL NOTES:**

- THE CONTRACTOR SHALL REVIEW AND VERIFY ALL LAYOUTS, DIMENSIONS AND ELEVATIONS ON THE PLANS WITH FINAL APPROVED EQUIPMENT DRAWINGS AS WELL AS ALL TECHNICAL SPECIFICATIONS PRIOR TO STARTING CONSTRUCTION AND SHOULD DISCREPANCIES OCCUR, THE CONTRACTOR SHALL NOTIFY THE ENGINEER TO OBTAIN THE ENGINEERS CLARIFICATION BEFORE COMMENCING WITH CONSTRUCTION.
- THE CONTRACTOR SHALL COORDINATE ALL RELATED DISCIPLINE DRAWINGS TO ENSURE ACCURATE INSTALLATION OCCURS, INCLUDING P&ID'S.
- 3. CONTRACTOR SHALL MAINTAIN A CLEAR PATH FOR ALL SURFACE WATER DRAINAGE STRUCTURES AND DITCHES DURING CONSTRUCTION.
- 4. ALL PIPE LINES SHALL HAVE A MINIMUM COVER OF 36" UNLESS OTHERWISE NOTED OR DIRECTED.
- NOTE; ALL VAULTS, MANHOLES, INLET STRUCTURES, BASINS, WET WELLS ETC. SHALL BE CONSIDERED "CONFINED SPACE ENTRY" AND SHALL BE MARKED AS SUCH BY MEANS OF STAMPING MANHOLE COVERS AND PLACING PERMANENT SIGNAGE ON THE VAULTS, BASINS OR STRUCTURES WARNING OF THE "CONFINED SPACE ENTRY" CONDITION.
- CONTRACTOR SHALL BE RESPONSIBLE FOR ALL PIPE SUPPORTS WHETHER SHOWN ON THE CONTRACT DOCUMENTS OR NOT. PIPE SUPPORTS SHALL BE INSTALLED PER MANUFACTURER'S RECOMMENDATIONS FOR SPACING AND SUPPORT. ADDITIONALLY, PROVIDE SUPPORT WHERE ABOVE GRADE PIPING CHANGES DIRECTION, IS ADJACENT TO FLANGED VALVES OR OTHER APPURTENANCES OR AT EQUIPMENT CONNECTIONS AND HEAVY FITTINGS.
- 7. NOTE: ALL NON-POTABLE/PLANT WATER USERS MUST BE CLEARLY LABELED AS "NON-POTABLE", NOT FOR HUMAN CONSUMPTION
- 8. PLANT TRAFFIC FLOW SHALL BE MAINTAINED AT ALL TIMES DURING CONSTRUCTION. IF TRAFFIC FLOW IS TO BE RE-DIRECTED, CONTRACTOR SHALL COORDINATE TEMPORARY TRAFFIC FLOW PATTERNS WITH OWNER AND ENGINEER.
- 9. CONTRACTOR SHALL RESTRAIN ALL UNDERGROUND PRESSURE PIPING AT ALL FITTINGS AND PIPE JOINTS.

#### **EXISTING UTILITIES:**


- UNDERGROUND UTILITIES SHOWN ON THE PLANS HAVE BEEN MADE AVAILABLE FROM VARIOUS ENTITIES THAT MAY INCLUDE UTILITY OWNERS, SURVEY SUBSURFACE UTILITY INVESTIGATIONS (SUE), RECORD DRAWINGS AND OTHERS. THIS INFORMATION MAY NOT ALL-INCLUSIVE AND THE CONTRACTOR IS ADVISED THAT ADDITIONAL UNDERGROUND UTILITIES AND CABLES INVESTIGATION MAY BE NECESSARY PRIOR TO STARTING CONSTRUCTION. THE CONTRACTOR SHALL NOTIFY THE ENGINEER OF RECORD IMMEDIATELY OF ALL POTENTIAL CONFLICTS.
- THE CONTRACTOR SHALL FIELD VERIFY SIZE, DEPTH, LOCATION AND MATERIAL OF ALL UNDERGROUND UTILITIES PRIOR TO THE START OF CONSTRUCTION.
- THE CONTRACTOR SHALL CAREFULLY SUPPORT AND PROTECT ANY UTILITIES, STRUCTURES, POWER POLES, PIPE LINES AND CONDUITS WHICH MAY BE ENCOUNTERED DURING COMPLETION OF THE WORK AT NO ADDITIONAL COST TO THE OWNER. THE CONTRACTOR SHALL APPLY NECESSARY MEANS TO PROTECT EXISTING UTILITIES DURING CONSTRUCTION . ANY DAMAGE RESULTING FROM THE CONTRACTOR'S OPERATIONS SHALL BE REPAIRED BY THE CONTRACTOR OR UTILITY OWNER (WHERE REQUIRED) TO THE SATISFACTION OF THE ENGINEER AND UTILITY OWNER AT THE CONTRACTOR'S EXPENSE.

#### PIPING SCHEDULE


ABBREVIATION	DESIGNATION	PIPE MATERIAL	NOTES
INF	INFLUENT	RESTRAINED DUCTILE IRON	RESTRAIN ENTIRE NETWORK
EFF	EFFLUENT	RESTRAINED DUCTILE IRON	RESTRAIN ENTIRE NETWORK, PROVIDE PIPE WITH PROTECTIVE LINING - ENTIRE NETWORK
D or SS	DRAIN OR SANITARY SEWER	DUCTILE IRON / SCH. 80 PVC	>=4" DIP / <=3" SCH. 80 PVC SOLVENT WELD, RESTRAIN ALL FITTINGS
FM	FORCE MAIN	RESTRAINED DUCTILE IRON	RESTRAIN ENTIRE NETWORK
NPW	NON-POTABLE WATER	RESTRAINED DUCTILE IRON / SCH. 80 PVC	>=4" DIP / <=3" SCH. 80 PVC SOLVENT WELD, RESTRAIN ENTIRE NETWORK
Α	PROCESS AIR	SCH. 10 304 STAINLESS STEEL	
SL	SLUDGE	RESTRAINED DUCTILE IRON	RESTRAIN ENTIRE NETWORK
SC	SCUM	RESTRAINED DUCTILE IRON	RESTRAIN ENTIRE NETWORK
PW	POTABLE WATER	RESTRAINED DUCTILE IRON / SCH. 80 PVC	>=4" DIP / <=3" SCH. 80 PVC SOLVENT WELD, RESTRAIN ENTIRE NETWORK
FA	FOUL AIR	SCH. 80 PVC / FRP	FRP ABOVE GRADE SCH. 80 PVC BELOW GRADE
ATAD	ATAD SUPPLY & DISCHARGE	RESTRAINED DUCTILE IRON	RESTRAIN ENTIRE NETWORK
PE	PLANT EFFLUENT	RESTRAINED DUCTILE IRON	RESTRAIN ENTIRE NETWORK, PROVIDE PIPE CONNECTING NEW EQ TANK W/ EXISTING EQ BASIN AND (NEW AND EXISTING) BIODENOPHO DITCHES WITH PROTECTIVE LINING
RAS/WAS	WASTE/RETURN ACTIVATED SLUDGE	RESTRAINED DUCTILE IRON	RESTRAIN ENTIRE NETWORK

### 9 MECHANICAL SYMBOLS

DESCRIPTION
BUTTERFLY VALVE
CHECK VALVE
GATE VALVE
PLUG VALVE
BALL VALVE
GLOBE VALVE

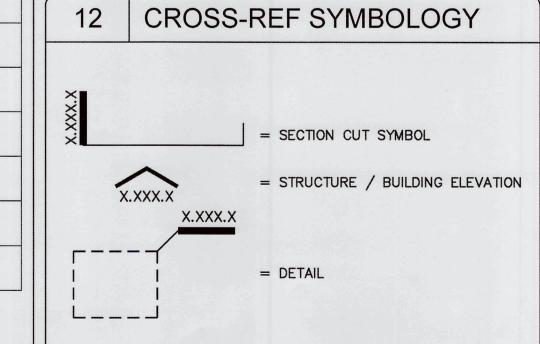

		11111
V.NO.	DESCRIPTION DATE	SPIRITE A.
		No 5
		PR
		STATE STATE
0	ISSUED FOR BID MAR 2021	11,5,10N
U	ISSUED FOR BID MAR 2021 REVISIONS	MITCHEL A. CH No. 56335

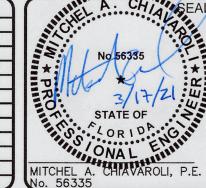



Phone: (727) 442-7196, Fax: (727) 461-3827 CA Lic. No. 29588 www.mckimcreed.com



#### **LIFT STATION 12A ELECTRICAL PUMP & VFD REHABILITATION**

 
**GENERAL** 

**CIVIL-MECHANICAL-LEAD SHEET** 

	Approximation of the second se	AND DESCRIPTION OF THE PERSON
1	PROJ. START DATE:	2020. JUN
	MCE PROJ. #	01024-0181
П	DRAWN	JG
	DESIGNED	AAH
	CHECKED	MAC
П	PROJ. MGR.	AAH
1		

G0.02 HORIZONTAL VERTICAL:





#### SITE CONTROL

DESIGNATION	NORTHING	EASTING	ELEVATION	DESCRIPTION	
CP #1	1121780.62	467360.95	5.20'	ND (LB 7203)	
CP #2	1121742.13	467200.98	4.27'	IR (LB 7203)	

#### LEGEND

PID PARCEL IDENTIFICATION CP CONTROL POINT R/W RIGHT OF WAY ND NAIL W/ DISC IR IRON ROD SR STATE ROAD EL ELEVATION FFE FINISHED FLOOR ELEVATION UNKN UNKNOWN

CONTROL POINT UTILITY POLE

← GUY WIRE ■ SEWER VALVE ₩ WATER VALVE

S SANITARY MANHOLE LIGHT POLE

O BOLLARD AIR RELEASE VALVE

O UTILITY RISER **BLOW OFF** 

UTILITY BOX OUTLET

SPIGOT

ANTENNA

FIRE HYDRANT

GRATE INLET

MONITOR WELL

CA Lic. No. 29588 www.mckimcreed.com



#### LIFT STATION 12A ELECTRICAL PUMP & **VFD REHABILITATION**


CIVIL SITE SITE PLAN

-		
	PROJ. START DATE:	2020. JUN
	MCE PROJ. #	01024-0181
	DRAWN	JG
	DESIGNED	AAH
	CHECKED	MAC
	PROJ. MGR.	ААН


SCALE HORIZONTAL: 1"=10'-0" VERTICAL:

**ISSUED FOR BID** 


\\MCKIMCREED.COM\NASUNI\DATA\PROJ\01024\0181\WATER\80-DRAWINGS\CIVIL\SSITE PLAN.DWG 03/17/2021 11:40:49 SUVATH SENG

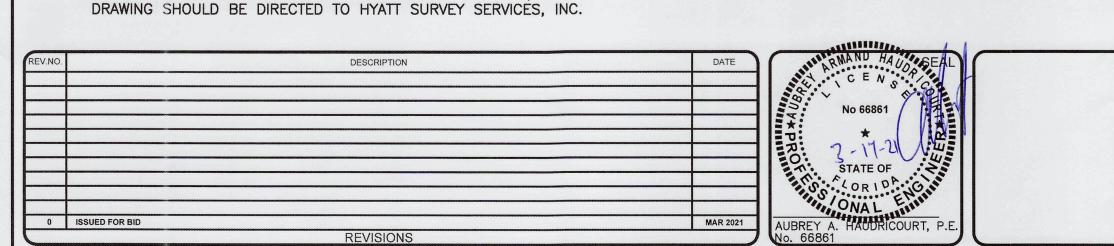

**MKIM&CREED** 1365 Hamlet Avenue Clearwater, Florida 33756 Phone: (727) 442-7196, Fax: (727) 461-3827

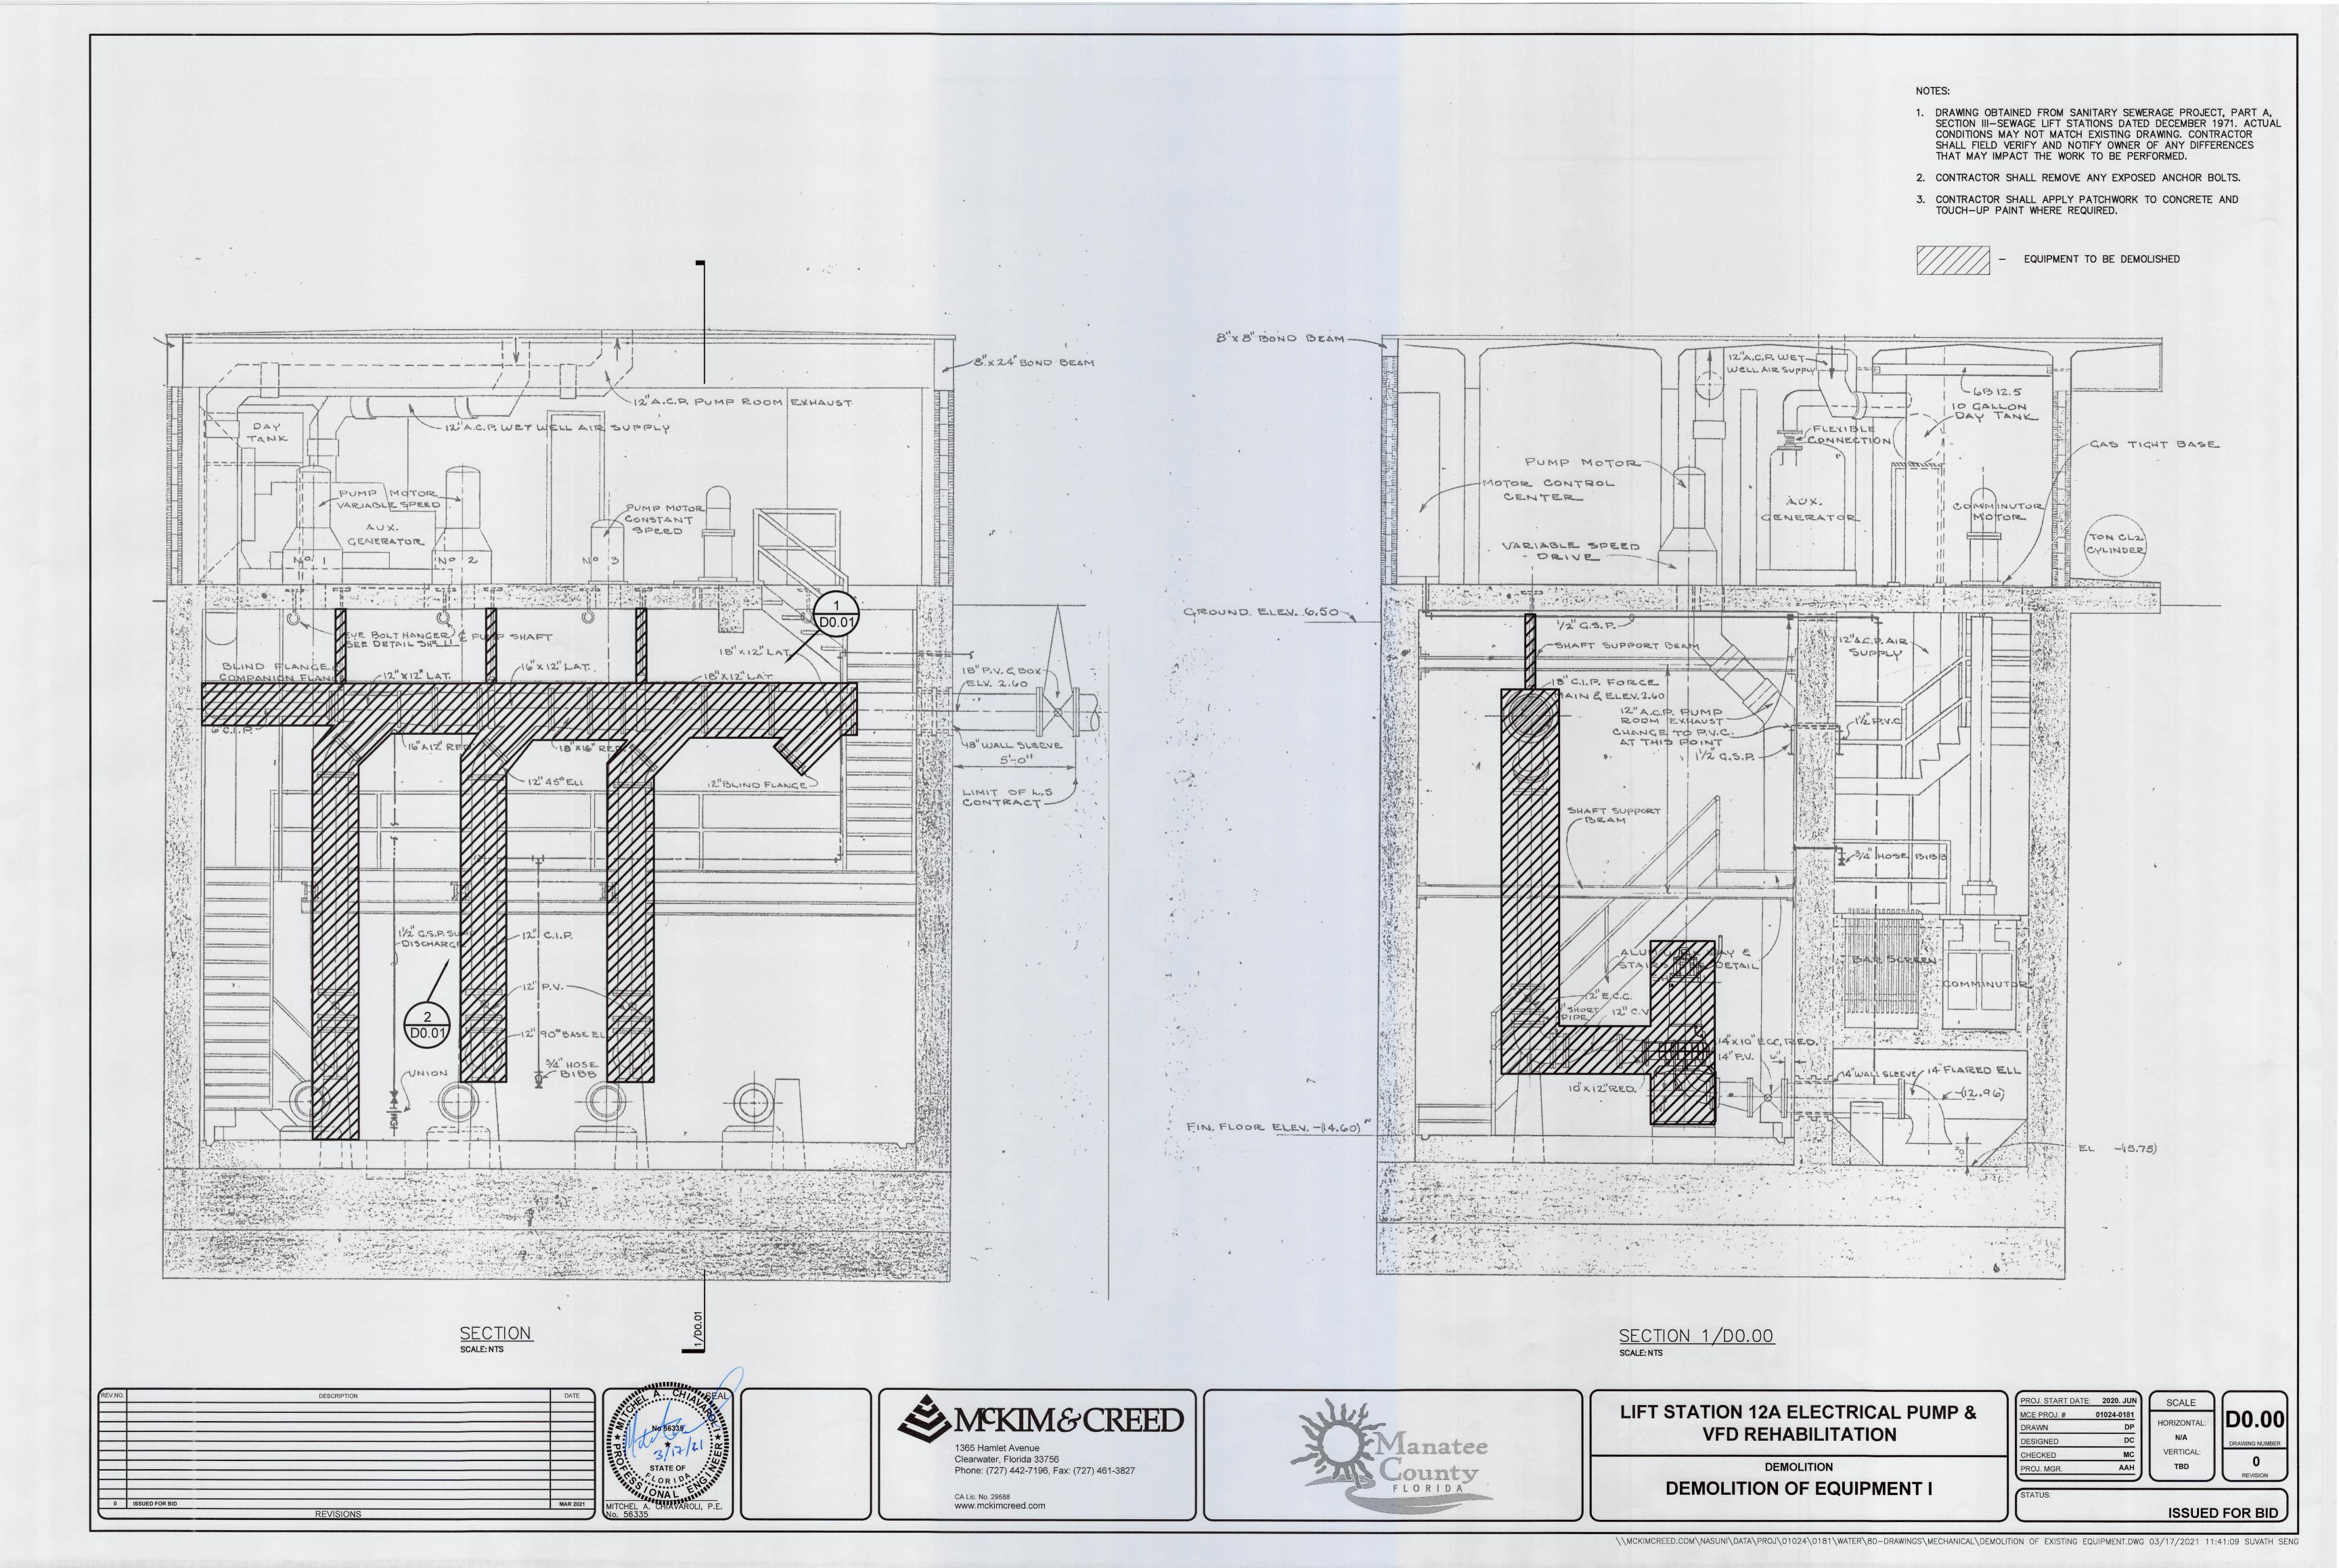




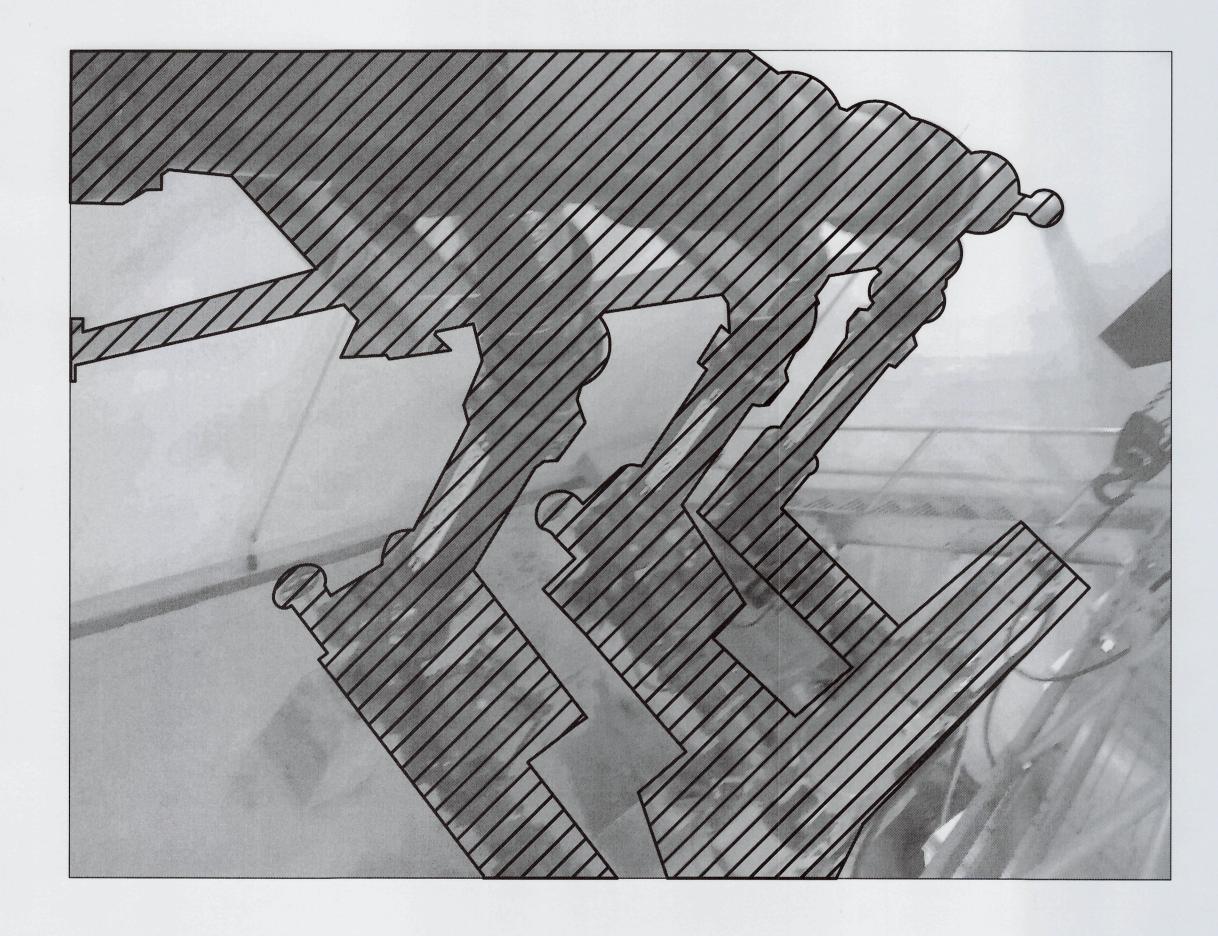


DEMOLITION PHOTO 1/DO.01
scale: nts



DEMOLITION PHOTO 2/DO.01
scale: NTS

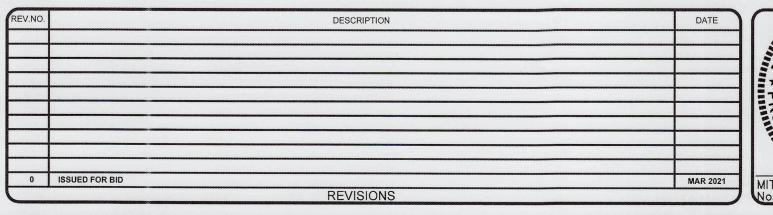

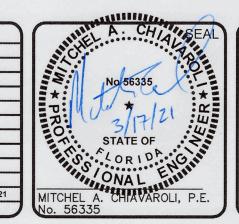







LIFT STATION 12A ELECTRICAL PUMP & VFD REHABILITATION

DEMOLITION

DEMOLITION OF EQUIPMENT II

1	PROJ. START DATE: 2020. JUN	SCALE	
	MCE PROJ. # 01024-0181		DO
	DRAWN DP	HORIZONTAL:	טען
	DESIGNED DC	N/A	DRAWING
	CHECKED MC	VERTICAL:	
	PROJ. MGR. AAH	TBD	
			REV

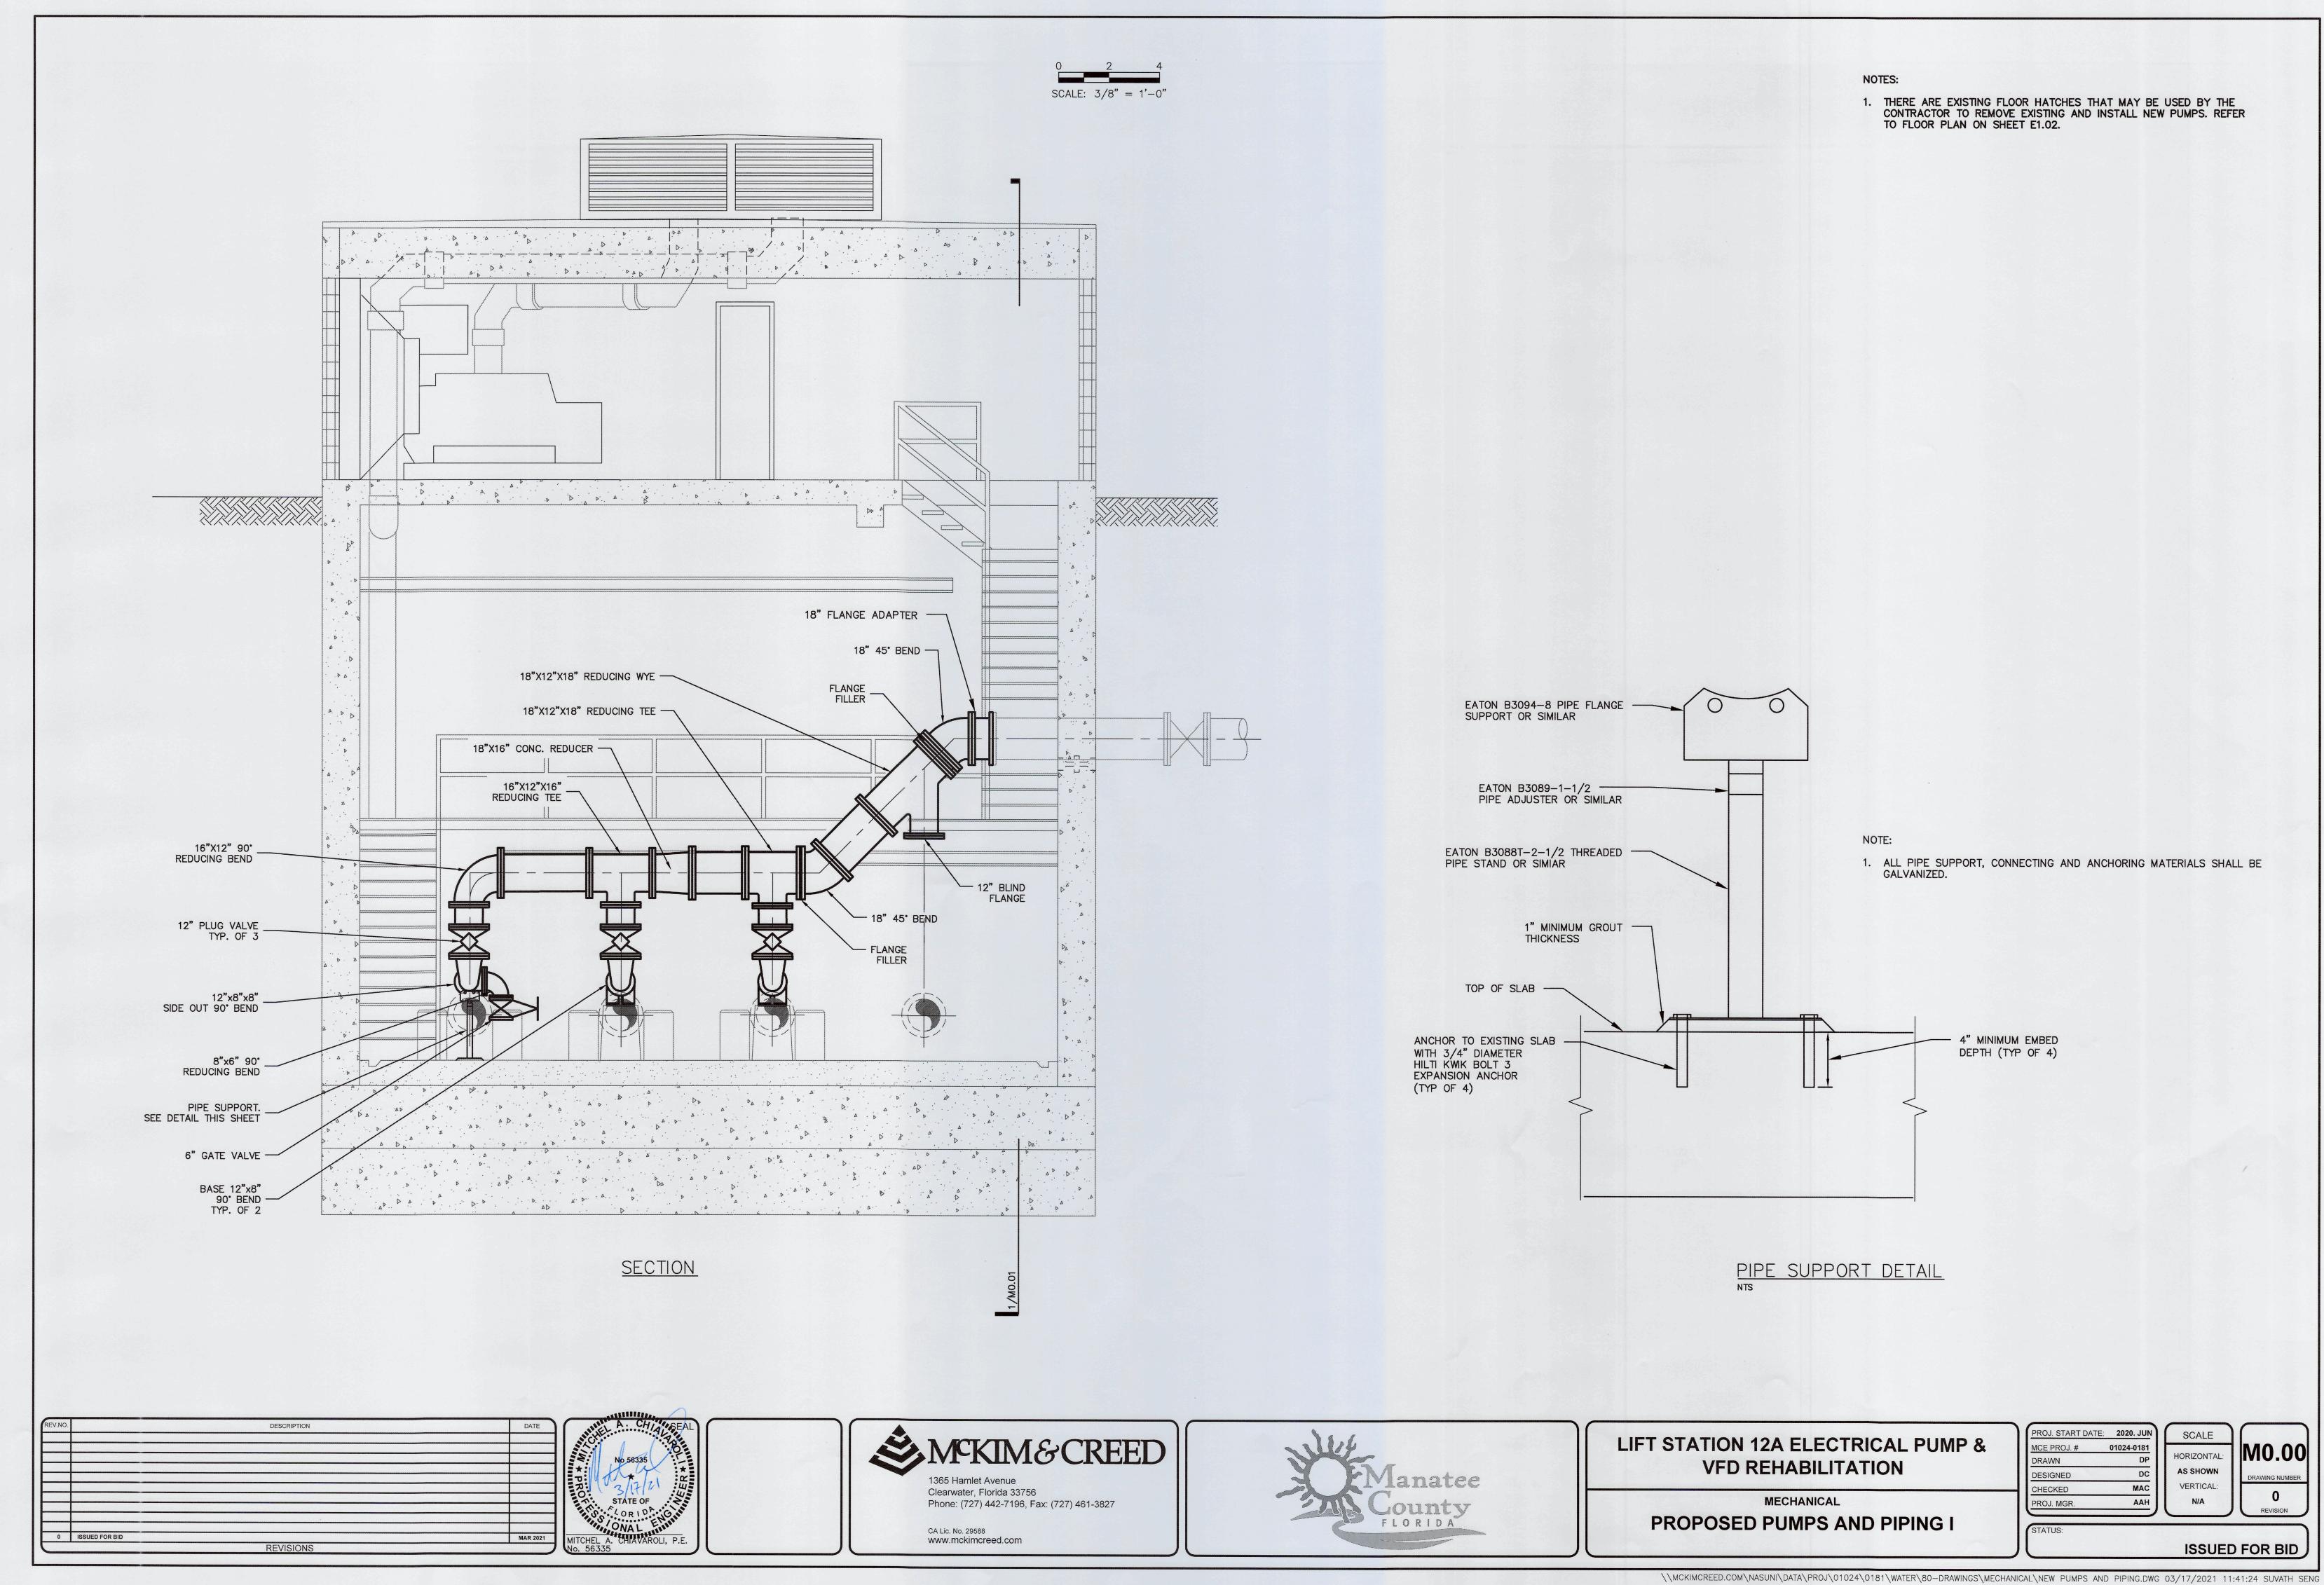


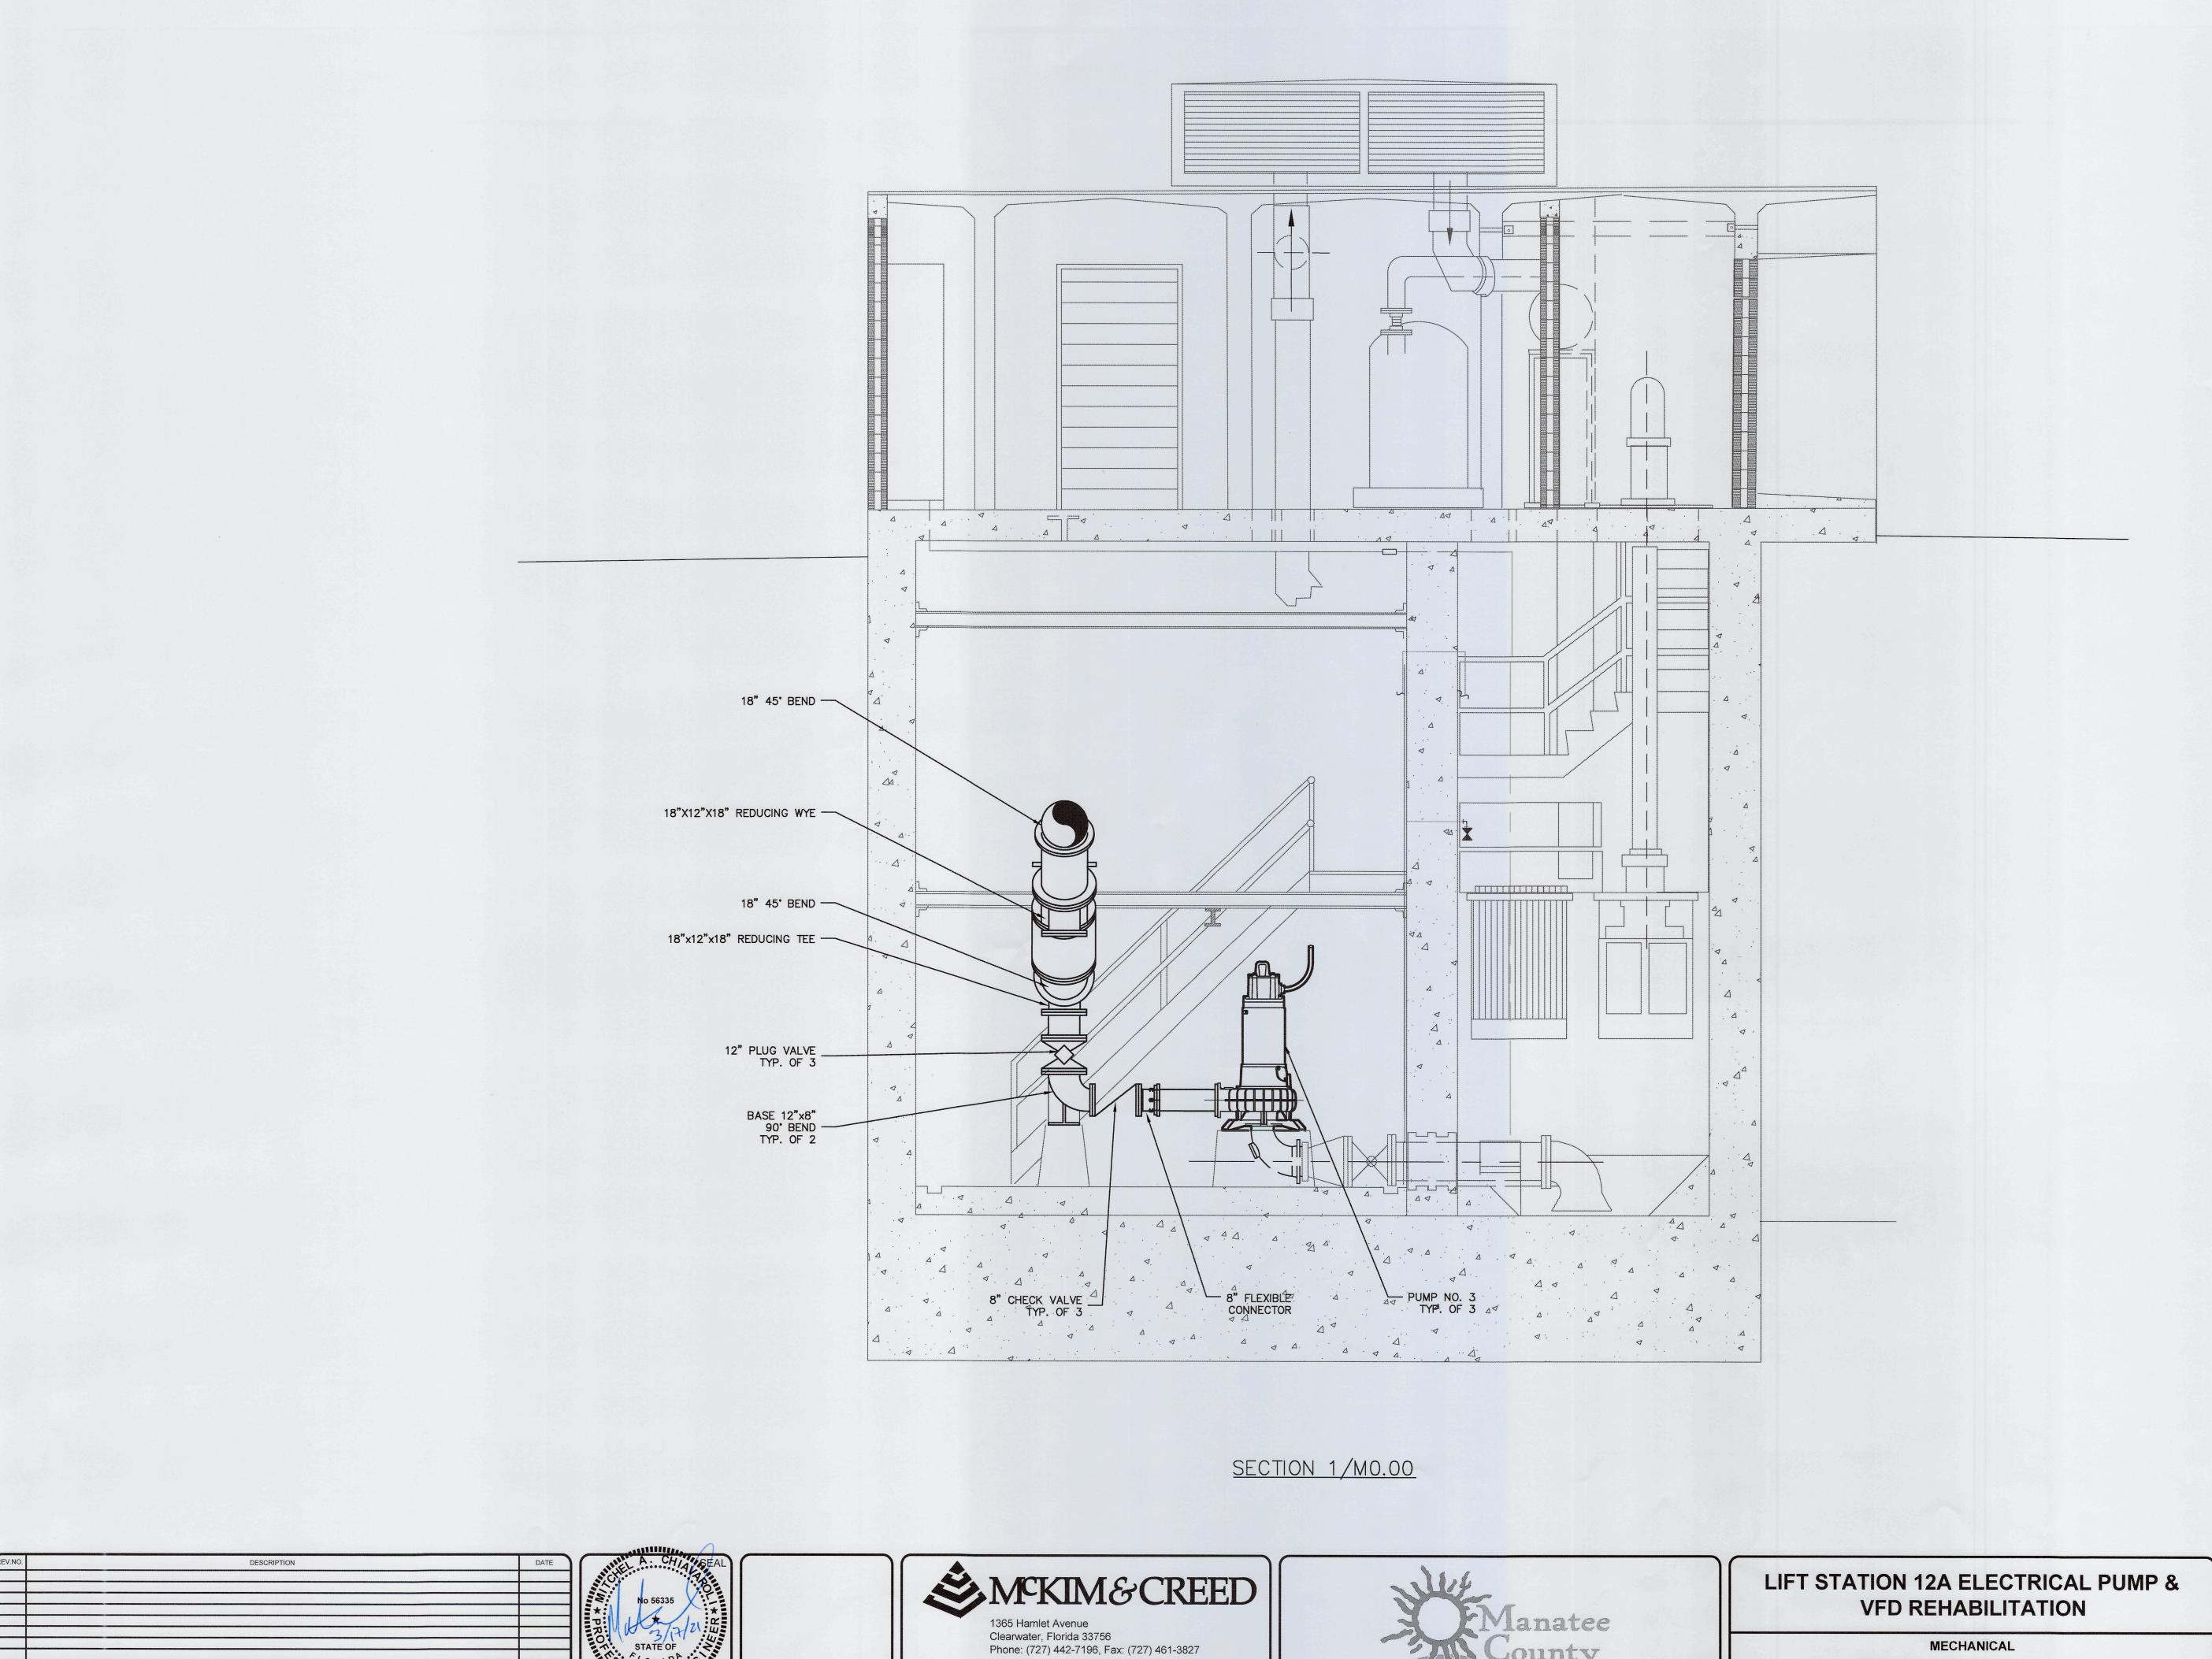

CA Lic. No. 29588 www.mckimcreed.com

0 ISSUED FOR BID

 REVISIONS



MECHANICAL PROPOSED PUMPS AND PIPING II PROJ. MGR.

#### **GENERAL NOTES**

1.1 ALL WORK IS TO BE PERFORMED IN A GOOD, WORKMANLIKE AND PROFESSIONAL MANNER.

1.2 ALL CONSTRUCTION SHALL BE IN STRICT COMPLIANCE WITH THE REQUIREMENTS OF THE FLORIDA STATE BUILDING CODE (FBC), LATEST EDITION, OR LOCAL BUILDING CODE REQUIREMENTS IF MORE STRINGENT

1.3 THESE DRAWINGS DO NOT SHOW PROVISIONS FOR SAFETY DURING CONSTRUCTION. IT IS THE RESPONSIBILITY OF THE GENERAL CONTRACTOR TO PROVIDE THE REQUIRED BRACING, SHORING, AND SAFETY DEVICES THROUGHOUT THE CONSTRUCTION OF THIS PROJECT.

#### COORDINATION

2.1 STRUCTURAL DRAWINGS SHALL BE USED IN CONJUNCTION WITH & COORDINATED WITH CIVIL AND ELECTRICAL DRAWINGS, INCLUDING VENDOR SUBMITTAL DRAWINGS AND OTHER CONTRACT DOCUMENTS.

2.2 COORDINATE THE EXACT SIZE AND LOCATION OF ALL SLEEVES AND OPENINGS THROUGH WALLS OR CONCRETE SLABS WITH CIVIL AND ELECTRICAL DRAWINGS. INCLUDING VENDOR SUBMITTAL DRAWINGS AND OTHER CONTRACT DOCUMENTS.

2.3 ANY DISCREPANCIES BETWEEN ACTUAL CONDITIONS AND THOSE SHOWN ON THESE DRAWINGS ARE TO BE BROUGHT TO THE ATTENTION OF THE STRUCTURAL ENGINEER BEFORE WORK PROCEEDS. INCLUDING ORDERING AND FABRICATING MATERIALS.

2.4 INDEPENDENT TESTING/REVIEW OF MATERIALS SHALL BE PROVIDED AS DEFINED IN PROJECT SPECIFICATIONS IF APPLICABLE. IN GENERAL PROJECT INVOLVES THE FOLLOWING: A. SOIL/FILL COMPACTION & BEARING. B. C.I.P. CONCRETE.

2.5 IF COORDINATION OF INFORMATION PRESENTED CONFLICTS w/ THE PROJECT SPECIFICATIONS, THE DRAWINGS WILL TAKE PRECEDENCE.

2.6 IN GENERAL CALL-OUTS ARE FOR NEW CONSTRUCTION U.N.O.. EXISTING CONSTRUCTION CALL-OUTS, ELEVATIONS AND DIMENSIONS OF EXISTING STRUCTURES ARE BASED ON EXISTING RECORD DRAWINGS PROVIDED TO McKIM & CREED. THE (\*) SYMBOL ON INDIVIDUAL FACILITY "STRUCTURAL" DRAWINGS INDICATES EXISTING CONSTRUCTION CALL-OUTS, CONDITIONS ELEVATIONS AND DIMENSIONS TO BE FIELD VERIFIED BY THE GENERAL CONTRACTOR U.N.O. PRIOR TO CONSTRUCTION. INCLUDING ORDERING AND FABRICATING MATERIALS. RECORD DRAWINGS PROVIDED BY MANATEE COUNTY UTILIZED INCLUDES:

A. "MANATEE COUNTY, FLA. SANITARY SEWERAGE PART A SECTION III - SEWAGE LIFT STATIONS" BY RUSSELL & AXON, CONSULTING ENGINEERS, INC. (DTD. DECEMBER 1971).

2.7 SPECIAL INSPECTIONS (IF APPLICABLE): ALL FOUNDATION SOILS, REINF. STEEL, C.I.P. CONCRETE, CONCRETE MASONRY. STRUCTURAL STEEL & PRE-CAST CONCRETE BUILDINGS/STRUCTURES WORK SHALL BE REVIEWED AS STATED IN CONJUNCTION w/ THEIR RESPECTIVE NOTES BELOW.

#### **FOUNDATIONS**

3.1 DESIGN ALLOWABLE SOIL BEARING PRESSURE - 2,500 PSF IN ACCORDANCE w/ THE PROJECT GEOTECHNICAL REPORT AS PREPARED BY DRIGGERS ENGINEERING SERVICES, INC. (PROJECT NO. DES 208566, DTD. OCTOBER 06, 2020). THE CONTRACTOR IS RESPONSIBLE FOR VERIFYING THIS VALUE PRIOR TO FOUNDATION CONSTRUCTION. IN AREAS WHERE THE SOIL DOES NOT YIELD THIS BEARING STRESS VALUE, ADJUSTMENT IN THE FOOTING DEPTHS AND FOUNDATION DIMENSION MAY BE MADE BY THE ENGINEER BEFORE WORK PROCEEDS. CONTRACTOR IS RESPONSIBLE FOR PERFORMING ANY SUCH ADJUSTMENTS.

3.2 PREPARE THE EXISTING SUBGRADE IN ACCORDANCE w/ THE PROJECT GEOTECHNICAL REPORT AS PREPARED BY DRIGGERS ENGINEERING SERVICES, INC. (PROJECT NO. DES 208566, DTD. OCTOBER 06, 2020). IN THE EVENT UNUSUAL SOIL CONDITIONS ARE UNCOVERED, NOTIFY THE OWNER AND ENGINEER PRIOR TO FOUNDATION CONSTRUCTION FOR INSTRUCTIONS HOW TO PROCEED. ADJUSTMENT IN THE FOOTING DEPTHS AND GENERAL FOUNDATION CONSTRUCTION MAY BE MADE BY THE ENGINEER BEFORE WORK PROCEEDS. CONTRACTOR IS RESPONSIBLE FOR PERFORMING ANY SUCH ADJUSTMENTS.

3.3 FOOTING, PIER & SLAB EXCAVATIONS AND FORMS SHALL BE REVIEWED BY AN OWNER'S CONSTRUCTION REPRESENTATIVE PRIOR TO PLACEMENT OF CONCRETE.

3.4 FOOTING, PIER & SLAB ELEVATIONS SHALL NOT BE RAISED OR LOWERED WITHOUT APPROVAL OF THE STRUCTURAL

3.5 ALL EXCAVATIONS SHALL BE ADEQUATELY DEWATERED BEFORE PLACEMENT OF CONCRETE. NO CONCRETE OR CONCRETE FILL SHALL BE PLACED IN STANDING WATER. ACCUMULATION EXCEEDING 1 INCH SHALL BE PUMPED OUT.

3.6 ALL FILL MATERIAL, IF REQUIRED, INSIDE THE BUILDING's/STRUCTURE'S FOOTPRINT AND BELOW FOUNDATION'S SHALL BE SELECT MATERIAL FREE FROM ROOTS, TRASH WOOD SCRAPS, AND OTHER EXTRANEOUS MATERIALS. PLACE FILL IN LIFTS NOT EXCEEDING THE RECOMMENDATIONS OF THE PROJECT GEOTECHNICAL REPORT AS PREPARED BY DRIGGERS ENGINEERING SERVICES, INC. (PROJECT NO. DES 208566, DTD. OCTOBER 06, 2020).

3.7 ALL FOOTINGS & PIERS SHALL BE CENTERED UNDER THE SUPPORTED WALL/COLUMN MEMBER UNLESS NOTED OTHERWISE.

3.8 CONSTRUCTION JOINTS IN FOUNDATION SLABS, WALLS & FOOTINGS SHALL BE MADE AT LOCATIONS SHOWN ON DRAWINGS.

3.9 ANCHOR BOLTS SHALL BE SET BY MEANS OF TEMPLATE. "FLOATING" ANCHOR BOLTS INTO PLACE IS PROHIBITED.

0 ISSUED FOR BID

#### **FOUNDATIONS CTD**

3.10 CONTRACTOR IS TO VERIFY THE ELEVATION AND LOCATION OF ALL EXISTING AND PROPOSED UTILITIES PRIOR TO CONSTRUCTION. ANY "KNOWN" UTILITY LINES DAMAGED WILL BE REPLACED AT THE CONTRACTOR'S EXPENSE. IF ANY "UNKNOWN" UTILITY LINES ARE ENCOUNTERED WHEN EXCAVATING THE CONTRACTOR IS TO CEASE ALL EXCAVATION ACTIVITY UNTIL THE ENGINEER AND OWNER ARE NOTIFIED AND INSTRUCTIONS ARE PROVIDED ABOUT HOW TO PROCEED.

3.11 THE CONTRACTOR SHALL OBTAIN THE OWNER'S PERMISSION BEFORE ENCASING OR BACK FILLING AROUND ANY EXISTING UNDERGROUND STRUCTURE, PIPING, ELECTRICAL, OR OTHER UNDERGROUND WORK.

#### REINFORCING STEEL

4.1 BARS SHALL BE ROLLED FROM NEW BILLET-STEEL OF DOMESTIC MANUFACTURE CONFORMING TO "STANDARD SPECIFICATION FOR DEFORMED AND PLAIN BILLET STEEL BARS FOR CONCRETE REINFORCEMENT," ASTM A615, GRADE 60 AND SUPPLEMENTARY REQUIREMENT S-1.

4.2 DETAIL AND FABRICATE REINFORCING STEEL IN ACCORDANCE WITH THE AMERICAN CONCRETE INSTITUTE "ACI DETAILING MANUAL," LATEST PUBLICATION.

4.3 REINFORCING STEEL IN PLACE SHALL BE REVIEWED BY THE OWNER'S CONSTRUCTION REPRESENTATIVE PRIOR TO PLACEMENT OF CONCRETE.

4.4 WELDED WIRE FABRIC SHALL CONFORM TO "STANDARD SPECIFICATION FOR WELDED STEEL WIRE FABRIC FOR CONCRETE REINFORCEMENT," ASTM A1064.

4.5 PLACE WELDED WIRE FABRIC AT CENTER OF SLABS-ON-GRADE AND ELEVATED SLAB TOPPINGS OVER METAL DECK. UNLESS NOTED OTHERWISE.

4.6 PROVIDE BARS AT CORNERS AND INTERSECTIONS OF WALLS & FOOTINGS OF THE SAME NUMBER AND SIZE AS LONGITUDINAL BARS, U.N.O. ON THE DRAWINGS.

4.7 FABRICATE CONTINUOUS BARS IN SLABS, WALLS AND FOOTINGS TO THE LONGEST PRACTICABLE LENGTHS.

4.8 REINFORCING STEEL SHALL NOT BE BENT AFTER BEING PARTIALLY EMBEDDED IN HARDENED CONCRETE.

4.9 BARS SHALL BE COLD BENT AND SHALL NOT BE HEATED FOR ANY REASON.

4.10 REINFORCING BARS SHALL NOT BE WELDED.

4.11 REFERENCE DRAWINGS FOR REQUIREMENTS FOR LAP SPLICING REINFORCING STEEL IN CONCRETE, ALL "LCS" SHALL CONFORM TO CLASS B SPLICE CRITERIA. IT IS ACCEPTABLE TO TO LAP SPLICE NON "LCS" A MINIMUM OF 50 BAR DIAMETERS UNLESS NOTED OTHERWISE.

4.12 LAP SPLICED BARS IN CONCRETE ARE TO BE WIRE TIED.

4.13 LAP SPLICED BARS IN MASONRY ARE TO BE NO FARTHER APART THAN 8".

#### CONCRETE

5.1 IN GENERAL CONCRETE SHALL DEVELOP 4.000 PSI MINIMUM COMPRESSIVE STRENGTH AT 28 DAYS. IN ADDITION REFERENCE "DESIGN CRITERIA" THIS DWG. & PROJECT SPECIFICATIONS FOR APPLICATION & SPECIFIC CONCRETE MIX DESIGN REQUIREMENTS.

5.2 CONCRETE WORK SHALL CONFORM TO "BUILDING CODE" REQUIREMENTS FOR REINFORCED CONCRETE", ACI 318 & TO "CODE REQUIREMENTS FOR ENVIRONMENTAL ENGINEERING CONCRETE STRUCTURES", ACI 350 (LATEST EDITIONS).

5.3 PLACE 1/2 INCH EXPANSION JOINT MATERIAL BETWEEN EDGES OF CONCRETE AND VERTICAL SURFACES UNLESS NOTED OTHERWISE.

5.4 PROVIDE CONSTRUCTION OR CONTROL JOINTS IN SLABS & WALLS AT LOCATIONS SHOWN ON DRAWINGS.

5.5 CHAMFER EXPOSED EDGES OF CONCRETE 3/4 INCH, UNLESS NOTED OTHERWISE. 5.6 CONTRACTOR SHALL BE RESPONSIBLE FOR PROPER CURING

OF ALL CONCRETE. CURING METHODS SHALL CONFORM TO "BUILDING CODE REQUIREMENTS FOR REINFORCED CONCRETE" ACI 318, "CODE REQUIREMENTS FOR ENVIRONMENTAL ENGINEERING CONCRETE STRUCTURES" ACI 350 AND "STANDARD PRACTICE FOR CURING CONCRETE," ACI 308 (LATEST EDITIONS).

5.7 UNLESS NOTED OTHERWISE DOWELS SHALL BE THE SAME NUMBER AND SIZE AS THE LARGEST VERTICAL BAR TO WHICH THEY ARE SPLICED.

5.8 REFERENCE PROJECT SPECIFICATIONS FOR REQUIRED FINISHES.

5.9 CONTRACTOR SHALL SUBMIT REBAR SHOP DRAWINGS FOR APPROVAL TO OWNER PRIOR TO FABRICATION. DO NOT FABRICATE REINFORCING PRIOR TO RECEIPT OF APPROVED SHOP DRAWINGS.

5.10 CONCRETE MIXES TO BE REVIEWED BY THE OWNER'S CONSTRUCTION REPRESENTATIVE PRIOR TO PLACEMENT OF CONCRETE. COMPRESSIVE STRENGTH TEST CYLINDERS TO BE REVIEWED BY THE OWNER'S CONSTRUCTION REPRESENTATIVE THROUGHOUT CONCRETE CONSTRUCTION OF THE PROJECT.

STATE OF

////mi////

#### GROUT

6.1 GROUT WHERE REQUIRED SHALL BE NON-SHRINK GROUT IN CONFORMANCE TO ASTM C1107.

6.2 GROUT SHALL BE NON-METALLIC AND NON-STAINING AND HAVE A MINIMUM COMPRESSIVE STRENGTH OF 5,000 PSI.

#### **MASONRY**

NOT APPLICABLE.

#### STRUCTURAL STEEL

8.1 STEEL SHALL CONFORM TO "STANDARD SPECIFICATION FOR STRUCTURAL STEEL," ASTM A36 (Fy=36 ksi) FOR ANGLES, PLATES & CHANNELS. WIDE FLANGE SECTIONS SHALL CONFORM TO ASTM A992 (Fy=50 ksi). HOLLOW STEEL SECTIONS (HSS) SHALL CONFORM TO ASTM A500, GRADE B (Fy=46 ksi). STEEL PIPE SHALL CONFORM TO ASTM A53, GRADE B, (Fy=35 ksi).

8.2 STEEL WORK SHALL CONFORM TO "SPECIFICATION FOR THE DESIGN, FABRICATION AND ERECTION OF STRUCTURAL STEEL BUILDINGS", OF THE AMERICAN INSTITUTE OF STEEL CONSTRUCTION, INC., (LATEST EDITION), INCLUDING ALL SUPPLEMENTS AND THE "CODE OF STANDARD PRACTICE FOR STEEL BUILDINGS AND BRIDGES", (LATEST EDITION).

8.3 CONNECTION BOLTS SHALL BE 3/4 INCH DIAMETER CONFORMING TO "STANDARD SPECIFICATION FOR HIGH-STRENGTH BOLTS FOR STRUCTURAL STEEL JOINTS". ASTM A325, UNLESS NOTED OTHERWISE CONNECTIONS ARE BEARING TYPE WITH THREADS EXCLUDED FROM SHEAR PLANES (A325x)

8.4 WELDING SHALL BE IN ACCORDANCE WITH THE LATEST EDITION OF THE AMERICAN WELDING SOCIETY AWS D1.1 "STRUCTURAL WELDING CODE". WELDING SHALL BE PERFORMED BY CERTIFIED PERSONNEL WHO HAVE BEEN PREVIOUSLY QUALIFIED BY TEST PRESCRIBED IN THE AWS "STRUCTURAL WELDING CODE". ELECTRODES SHALL CONFORM TO AWS 5.5, E70XX.

8.5 LINTELS SHALL BEAR EIGHT (8) INCHES MINIMUM ON MASONRY UNLESS NOTED OTHERWISE.

8.6 THE CONTRACTOR SHALL PROVIDE ADEQUATE TEMPORARY BRACING, SHORING, AND GUYING OF STEEL FRAMING AGAINST WIND, CONSTRUCTION LOADS, AND OTHER TEMPORARY FORCES UNTIL SUCH PROTECTION IS NO LONGER REQUIRED FOR THE SAFE SUPPORT OF THE FRAMING.

8.7 ALL COPES, BLOCKS, CUTS, CUT-OFFS AND OTHER CUTTING OF STRUCTURAL MEMBERS SHALL HAVE ALL RE-ENTRANT CORNERS SHAPED, AND NOTCH-FREE TO A RADIUS OF AT LEAST 1/2 INCH. THE FILLET AND ITS CONTIGUOUS CUTS SHALL MEET WITHOUT OFFSET OR CUTTING PAST THE POINT OF TANGENCY.

8.8 ANCHOR BOLTS SHALL BE ASTM F1554 OR ASTM A36 & SHALL BE EITHER HEADED w/ NUTS TACK WELDED TO BOLTS OR NON-HEADED w/ HOOKS AS REQUIRED BY THE DRAWINGS. PROVIDE (2) NUTS AND WASHERS WITH EACH ANCHOR BOLT AT COLUMNS UNLESS NOTED OTHERWISE. ANCHOR BOLTS FOR EQUIPMENT & OTHER ASSEMBLIES MAY BE POST APPLIED ANCHOR ASSEMBLIES AS INDICATED ON THE DRAWINGS.

8.9 OVERSIZED AND SLOTTED HOLES SHALL NOT BE USED FOR BOLTED CONNECTIONS ON THIS PROJECT EXCEPT AT LOCATIONS NOTED ON DRAWINGS.

8.10 SPLICING OF STRUCTURAL STEEL MEMBERS IS PROHIBITED WITHOUT THE APPROVAL OF THE STRUCTURAL ENGINEER, AS TO LOCATION AND TYPE OF SPLICE. ANY MEMBER HAVING A SPLICE NOT SHOWN AND DETAILED ON THE SHOP DRAWINGS WILL BE REPLACED.

8.11 PRE-GROUTING BASE PLATES IS NOT PERMITTED.

8.12 ALL HOLES IN STRUCTURAL STEEL ARE TO BE PUNCHED OR DRILLED. FLAME CUTTING OF STEEL IS STRICTLY PROHIBITED.

8.13 ALL DESIGN, DETAILING, FABRICATION AND ERECTION SHALL BE IN ACCORDANCE WITH THE LATEST EDITION OF THE AMERICAN INSTITUTE OF STEEL CONSTRUCTION (AISC) MANUAL OF STEEL CONSTRUCTION.

8.14 IN GENERAL SHOP CONNECTIONS SHALL BE EITHER WELDED OR BOLTED AND FIELD CONNECTIONS SHALL BE BOLTED UNLESS NOTED OTHERWISE.

8.15 FABRICATOR/CONTRACTOR SHALL SUBMIT SHOP DRAWINGS FOR OWNER/ENGINEER APPROVAL PRIOR TO FABRICATION. ALL SHOP DRAWINGS MAY BE EXPEDITED IF THE FABRICATOR ADHERES CLOSELY TO THE DETAILS, NOTES, AND INSTRUCTIONS, SHOWN ON THE DRAWINGS.

8.16 ALL GALVANIZED MATERIALS THAT ARE FIELD CUT, FIELD WELDED OR DAMAGED IN SURFACE FINISH SHALL BE CLEANED AND RE-COATED w/ A 98% ZINC RICH OXIDE AND IN CONFORMANCE w/ THE PROJECT SPECIFICATIONS.

8.17 STRUCTURAL STEEL FRAMING & DECKING ERECTION TO BE REVIEWED BY THE THE OWNER'S CONSTRUCTION REPRESENTATIVE THROUGHOUT CONCRETE & STEEL CONSTRUCTION OF THE PROJECT.

#### **ALUMINUM**

NOT APPLICABLE.

#### PRECAST CONCRETE

10.1 PRE-CAST CONCRETE FIELD ASSEMBLED STRUCTURES TO BE DESIGNED BY THE PRE-CAST MANUFACTURER UTILIZING "DESIGN LOADS" PROVIDED THIS DRAWING AND/OR THE RESPECTIVE FACILITY STRUCTURAL DRAWINGS AND IN ACCORDANCE w/ THE PROJECT SPECIFICATIONS. COORDINATE w/ THE CIVIL, ELECTRICAL, MECHANICAL AND VENDOR EQUIPMENT DRAWINGS FOR ADDITIONAL MATERIALS REQUIRED FOR CALCULATION OF THE DEAD LOADS, LIVE LOADS AND EQUIPMENT LOADS, THAT MAY BE SUSPENDED FROM THE SIDES OF WALL PANELS AND UNDERSIDE OF THE TOP SLAB PANELS AS APPLICABLE.

10.2. PRE-CAST CONCRETE FIELD ASSEMBLED STRUCTURES MANUFACTURER IS REQUIRED TO SUBMIT DRAWINGS AND CALCULATION PACKAGES SEALED. SIGNED AND DATED BY AN ENGINEER CURRENTLY LICENSED BY THE STATE OF FLORIDA. FABRICATION OF THE PRE-CAST FIELD ASSEMBLED STRUCTURES COMPONENTS SHOULD NOT OCCUR UNTIL "FINAL" ACCEPTANCE OF THE MANUFACTURER'S DRAWINGS AND CALCULATIONS SUBMITTALS.

10.3 REFERENCE MECHANICAL AND STRUCTURAL DRAWINGS FOR PRE-CAST CONCRETE FIELD ASSEMBLED STRUCTURES FOUNDATION SYSTEMS AND BEARING ELEVATIONS, DIMENSIONS, WALL AND TOP SLAB OPENINGS & TOP SLAB SLOPE REQUIREMENTS.

10.4 REFERENCE MECHANICAL DRAWINGS & PROJECT SPECIFICATIONS FOR ALL INTERIOR AND EXTERIOR WALL AND SLAB SECTIONS FINISH REQUIREMENTS.

10.5 PRE-CAST FIELD ASSEMBLED STRUCTURES WALL AND SLAB SECTIONS TO HAVE A MINIMUM 28 DAY COMPRESSIVE STRENGTH

10.6 REFERENCE ALL PROJECT SPECIFICATIONS RELATED TO THE PRE-CAST CONCRETE FIELD ASSEMBLED STRUCTURES FOR ADDITIONAL REQUIREMENTS AND INFORMATION.

10.7 CONSTRUCTION ACTIVITIES RELATED TO THE PRE-CAST FIELD ASSEMBLED STRUCTURES TO BE REVIEWED BY THE THE OWNER'S CONSTRUCTION REPRESENTATIVE THROUGHOUT

#### PRE-ENGR. TIMBER TRUSS

NOT APPLICABLE

#### MISC. BUILDING MATERIALS

13.1 ALL MISCELLANEOUS MATERIALS ARE TO BE DELIVERED TO SITE & STAGED ON SITE PRIOR TO INSTALLATION, STORE ON SITE AS REQUIRED BY THE MATERIAL MANUFACTURER TO AVOID

13.2 CAULK & SEALANT MATERIAL SHALL BE MASTERSEAL "NP 1" ONE COMPONENT, MOISTURE CURING HIGH PERFORMANCE POLY-URETHANE SEALANT, OR AN APPROVED EQUAL.

#### **ABBREVIATIONS**

14.1 THE FOLLOWING LIST OF ABBREVIATIONS IS NOT INTENDED TO REPRESENT ALL THOSE USED ON THE DRAWINGS. BUT TO SUPPLEMENT THE MORE COMMON ABBREVIATIONS USED.

ADD'L = ADDITIONAL = ALUMINUM ALT. = ALTERNATE BLDG. = BUILDING BLK. = BLOCK BM. BEAM \*\*\*\*

BOTTOM OF \*\*\*\* BEARING \*\*\*\*\* C.I.P. = CAST-IN-PLACE CLR. = CLEAR CMU = CONC. MAS. UNIT

CONST. = CONSTRUCTION

CONT. = CONTINUOUS

COORD.= COORDINATE

CTR. = CENTER

DBL. =

EA. =

EXIST. =

E.O.

EXP.

FLG.

FDN.

F.S.

FT.

FTG.

HRS.

INTR.

JST.

LLV

L.P.

LSL

MAS.

GA. =

EQ.

CTR'D. = CENTERED

DWG.'s. = DRAWINGS

EQUIP. = EQUIPMENT

\*\*\*\*\*

\*\*\*\*

\*\*\*\*\*

300000 400000

C.O. = CLEAN OUT COL. = COLUMN CONC. = CONCRETE CONN. = CONNECTION

DOUBLE

DRAWING

ELEVATION

EDGE OF

EXISTING

FLANGE

= FOUNDATION

= FAR SIDE

= FEET

GALV. = GALVANIZED

GALV'D = GALVANIZED

HORZ. = HORIZONTAL

I/F = INSIDE FACE

INFO. = INFORMATION

= INTERIOR

JOIST

JOINT

= LOW POINT

= MASONRY

MFG. = MANUFACTURER

N/A = NOT APPLICABLE

NA = NOT APPLICABLE

N.T.S. = NOT TO SCALE

= OUTSIDE FACE

MAT'L. = MATERIAL

MIN. = MINIMUM

NOM. = NOMINAL

N.S. = NEAR SIDE

0.C. = ON CENTER

O/H = OVERHANG

OPNG. = OPENING

PLCS. = PLACES

RAD.

REF.

SIM.

STD.

STL.

T/D THK.

P.P. = PUMP PAD

= RADIUS

REINF. = REINFORCING

= SIMILAR

SPECS. = SPECIFICATIONS

S.S. = STAINLESS STEEL

= SHORT SLOTTED

STANDARD

= TOP & BOTTOM

OTHERWISE

= CROSS OR "X"-BRACE

= TURN DOWN

= THICK

T.O.S = TOP OF STEEL

U.N.O. = UNLESS NOTED

THK'D = THICKENED

T.O. = TOP OF

TYP. = TYPICAL

VERT. = VERTICAL

W.P. = WORK POINT

REQ'D. = REQUIRED

RET. = RETAINING

ROT. = ROTATE

SPA. = SPACED

===

\*\*\*\*

= REFERENCE

OPP. = OPPOSITE

0/0 = OUT TO OUT

ORIENT.= ORIENTATION

MTL. = METAL

= LONG SLOTTED

KNEE BRACE

STRUCTURES

= LONG LEG VERTICAL

LLH = LONG LEG HORIZONTAL

LIQUID CONTAINMENT

H.P. = HIGH POINT

\*\*\*\*\*

\*\*\*\*\*\*

\*\*\*\*

= FOOTING

GAGE

HOURS

= EXPANSION

EQUAL

= DIRECTION

EACH

OF 5,000 PSI.

CONCRETE CONSTRUCTION OF THE PROJECT.

#### PRE-ENGR. METAL BLDGS.

NOT APPLICABLE.

DAMAGE PRIOR TO INSTALLATION.

#### **DESIGN LOADS**

DESIGN LOADS BASIS OF DESIGN: FLORIDA BUILDING CODE (FBC) - 2020 EDITION MINIMUM DESIGN LOADS FOR BUILDINGS & OTHER STRUCTURES - ASCE 7-16

EQUIP. LOAD: N/A LIVE LOAD: 125 PSF (ELECTRICAL BLDG. FLOOR), 100 PSF (ACCESS STAIRS & PLATFORMS)

ROOF LOAD: 65 PSF (ELECTRICAL BLDG. ROOF) SNOW LOAD: N/A

WIND LOAD: 160 mi/hr, EXPOSURE C, OCCUPANCY/RISK CATEGORY III CALCULATED WIND BASE SHEARS:

Vx = 13.9 k & Vy = 4.9 kCOMPONENTS & CLADDING WIND PRESSURES: ZONE 1, ZONE 2 & ZONE 3 ROOF PRESSURES = BY ELECTRICAL BLDG. MFG.

ZONE 4 & ZONE 5 WALL PRESSURES = BY ELECTRICAL BLDG. MFG. SEISMIC:

SOIL BEARING: FIELD TEST PER PROJECT GEOTECH REPORT = 2,500 PSF REF. "FOUNDATIONS" NOTE 3.1 DWG. S0.00

ALUMINUM WELD FILLERS ALLOYS SHALL CONFORM TO: AWS A5.10 (N/A)

#### **DESIGN CRITERIA**

STEEL ELECTRODES SHALL CONFORM TO:

CONCRETE 28 DAY COMPRESSIVE STRENGTH: SLABS-ON-GRADE & NON LCS SLABS f'c = 4.000 PSIPIPE ENCASEMENTS: f'c = 3,000 PSI (N/A)SLABS & WALLS OF LCS: f'c = 4,500 PSI (N/A)BEAMS & COLUMNS OF LCS: f'c = 4,500 PSI (N/A)NON-LCS FOOTINGS & PIERS: f'c = 4,000 PSIBELOW GRADE & RETAINING WALLS: fc = 4,000 PSI (N/A)SIDEWALK, DRIVEWAY, CURB & GUTTER: fc = 3,000 PSI (N/A)REINFORCING STEEL: ASTM A615, GRADE 60 WELDED WIRE FABRIC: **ASTM A1064** STRUCTURAL STEEL: REF. STRUCTURAL NOTE 8.1 REF. STRUCTURAL NOTE 9.2 (N/A) **ALUMINUM:** BOLTS SHALL BE 3/4" Ø ASTM A325 OR TYPE 316 S.S.: REF. STRUCTURAL NOTE 8.3 ANCHOR BOLTS SHALL BE 3/4" ASTM F-1554 OR ASTM A36 (STEEL); TYPE 316 S.S. (ALUMINUM): REF. STRUCTURAL NOTE 8.8

AWS 5.5 E70XX

REF. "DESIGN LOADS" TABLE

X-SYY.Y

SOIL BEARING CAPACITY:

LEGEND ENLARGED PLAN AREA,  $\times\!\!\times\!\!\times\!\!\times$ (EXISTING) CONC. MASONRY BLOCK BRICK VENEER (EXISTING) CONC. WALL, SLAB, ETC. . . . . . . . . . (EXISTING) (EXISTING) GRATING

DETAIL OR SECTION

PROJECT NORTH

**ELEVATION DATUM** 

NO./SHEET NO. REFERENCE

NORTH

ELEVATION NO./SHEET NO.

ELEVATIONS X'-X" (Y.YY')

MOMENT CONNECTION

REFERENCE

X'-X" = DISTANCE TO/FROM FACILITY REFERENCE EL 0'-0" Y.YY' = EQUIVALENT SITE EL VERTICAL DATUM

STEP IN FOOTING ELEVATION STL. FRAMING COL./BM.

### **LIFT STATION 12A ELECTRICAL PUMP & VFD REHABILITATION**

STRUCTURAL GENERAL NOTES, DESIGN LOADS, CRITERIA & LEGEND

PROJ. START DATE: 2020. JUN SCALE 01024-0181 **HORIZONTAL** DAR / WFB DRAWN NA DESIGNED VERTICAL: CHECKED WFB / AEA PROJ. MGR. AAH

ISSUED FOR BID

WILLIAM F. BAND, P.E.





Phone: (727) 442-7196, Fax: (727) 461-3827

CA Lic. No. 29588 www.mckimcreed.com




STRUCTURAL

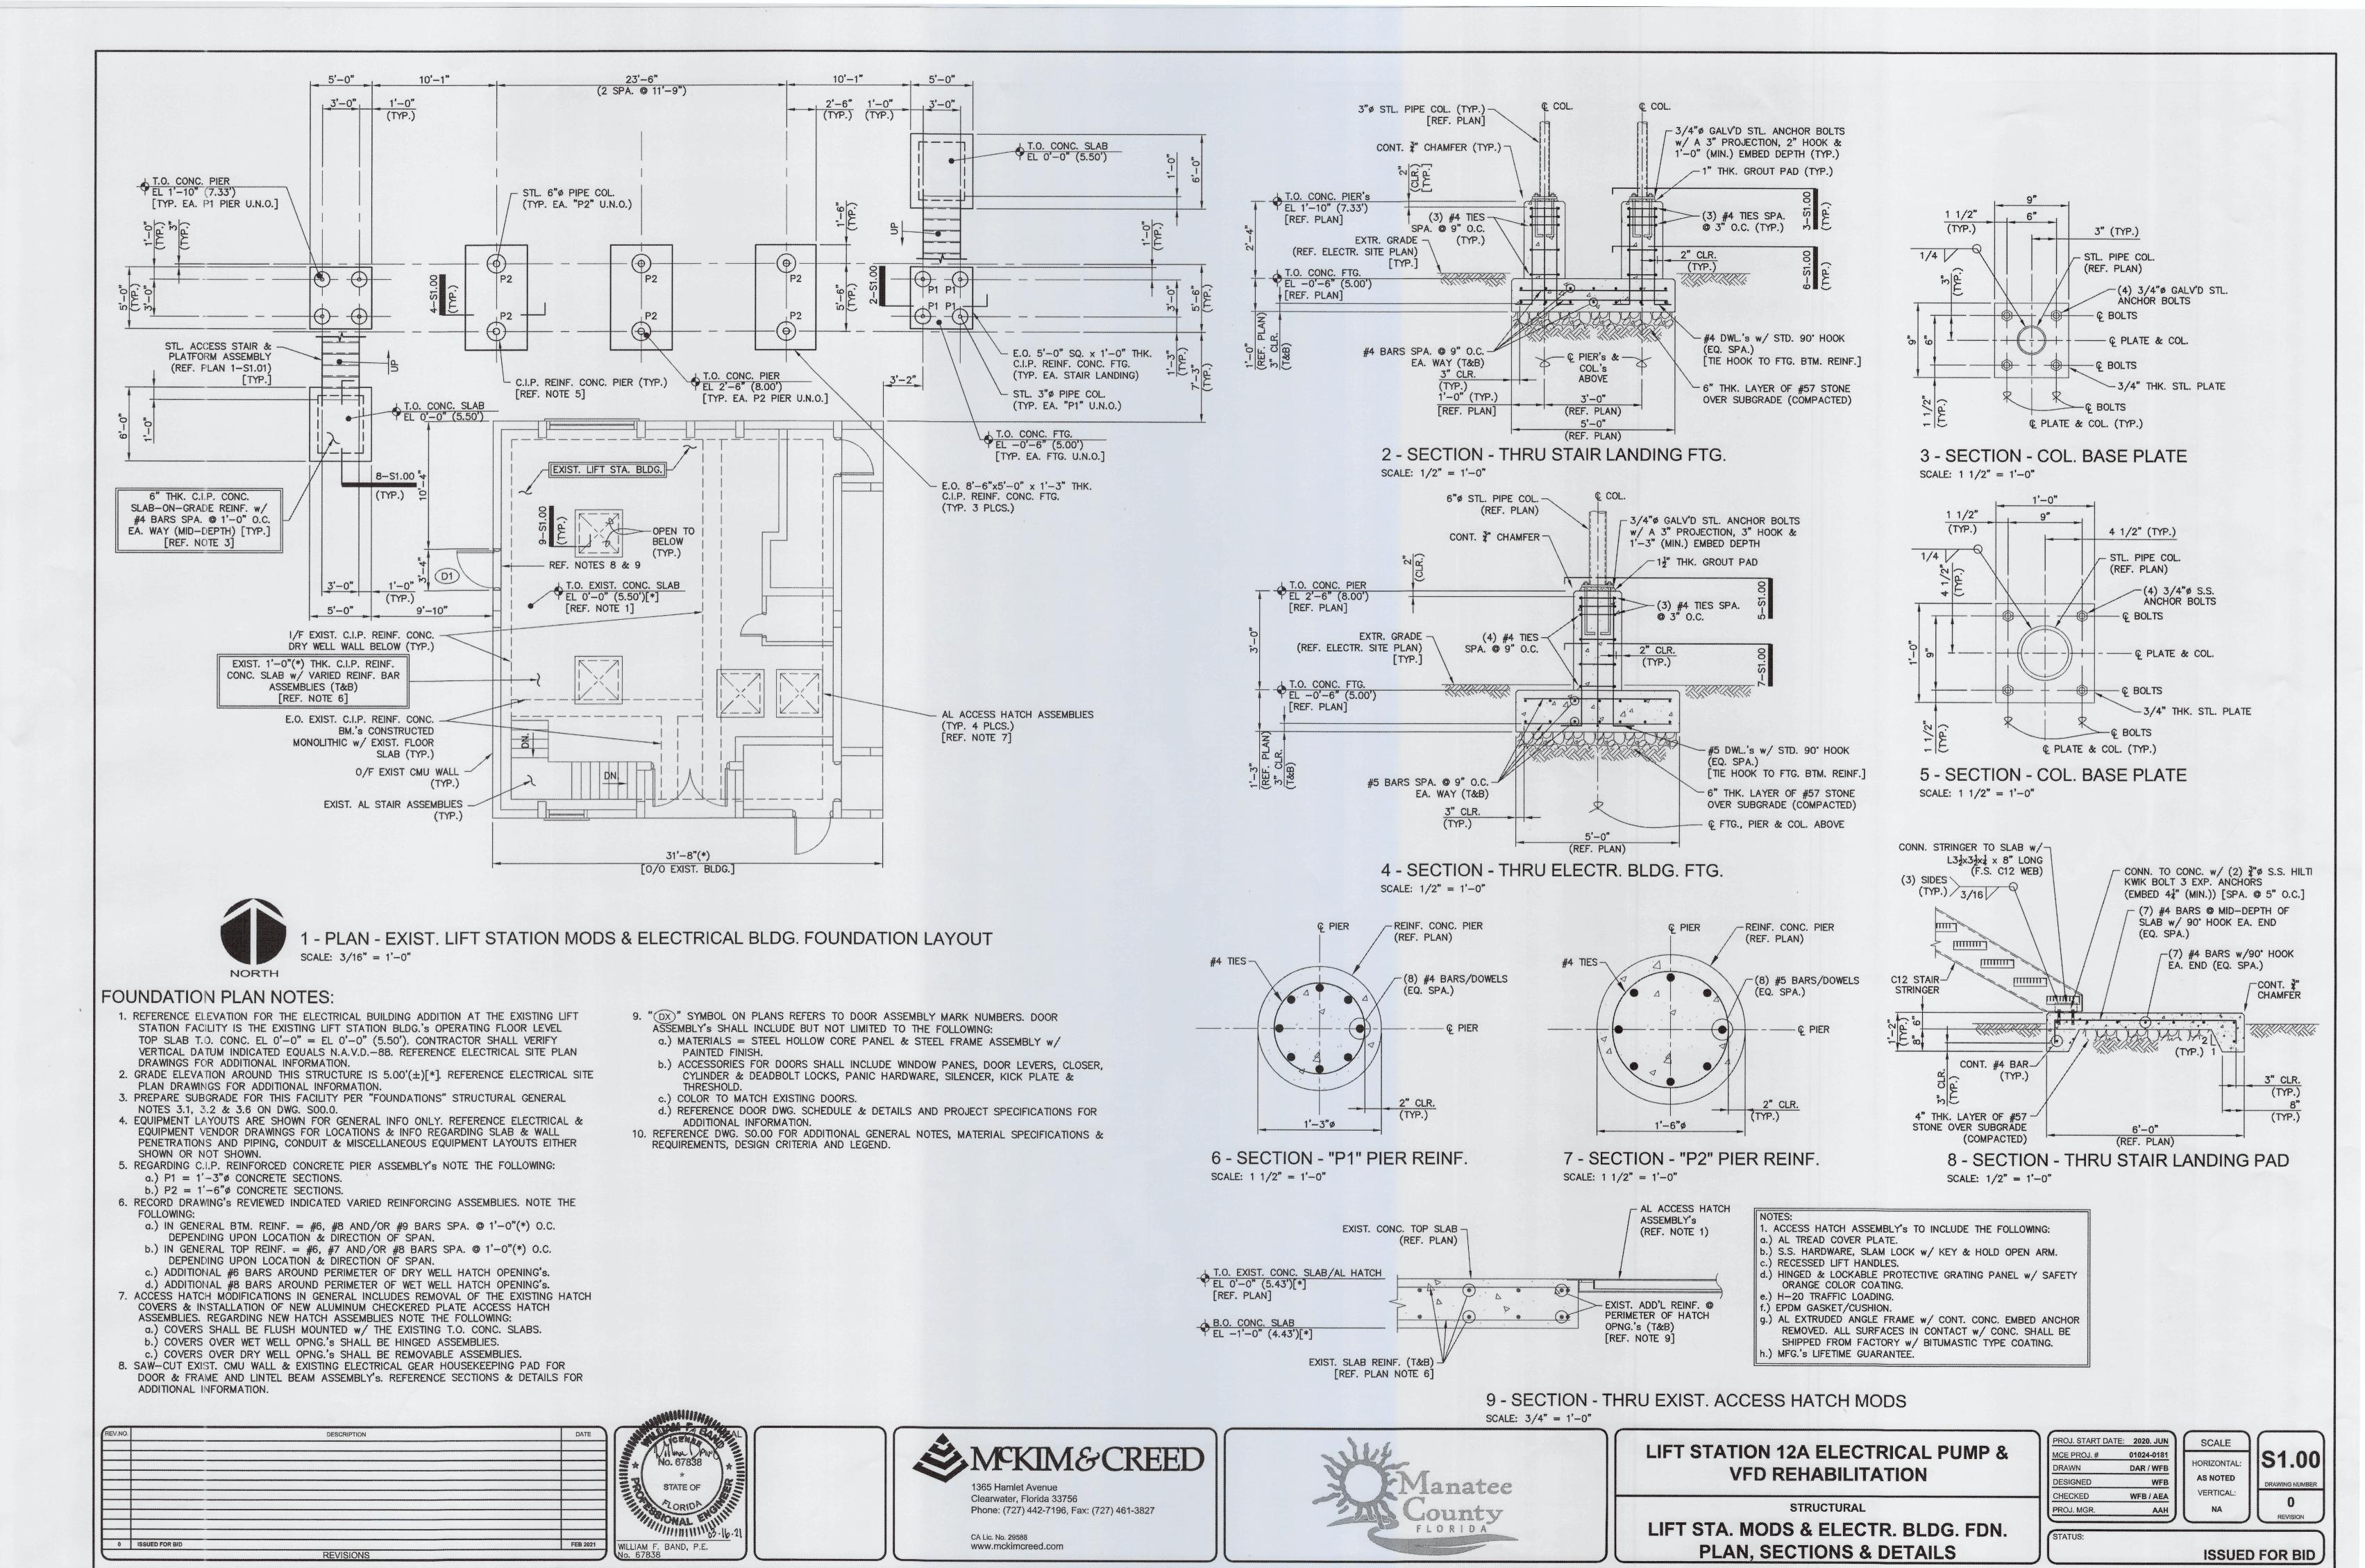


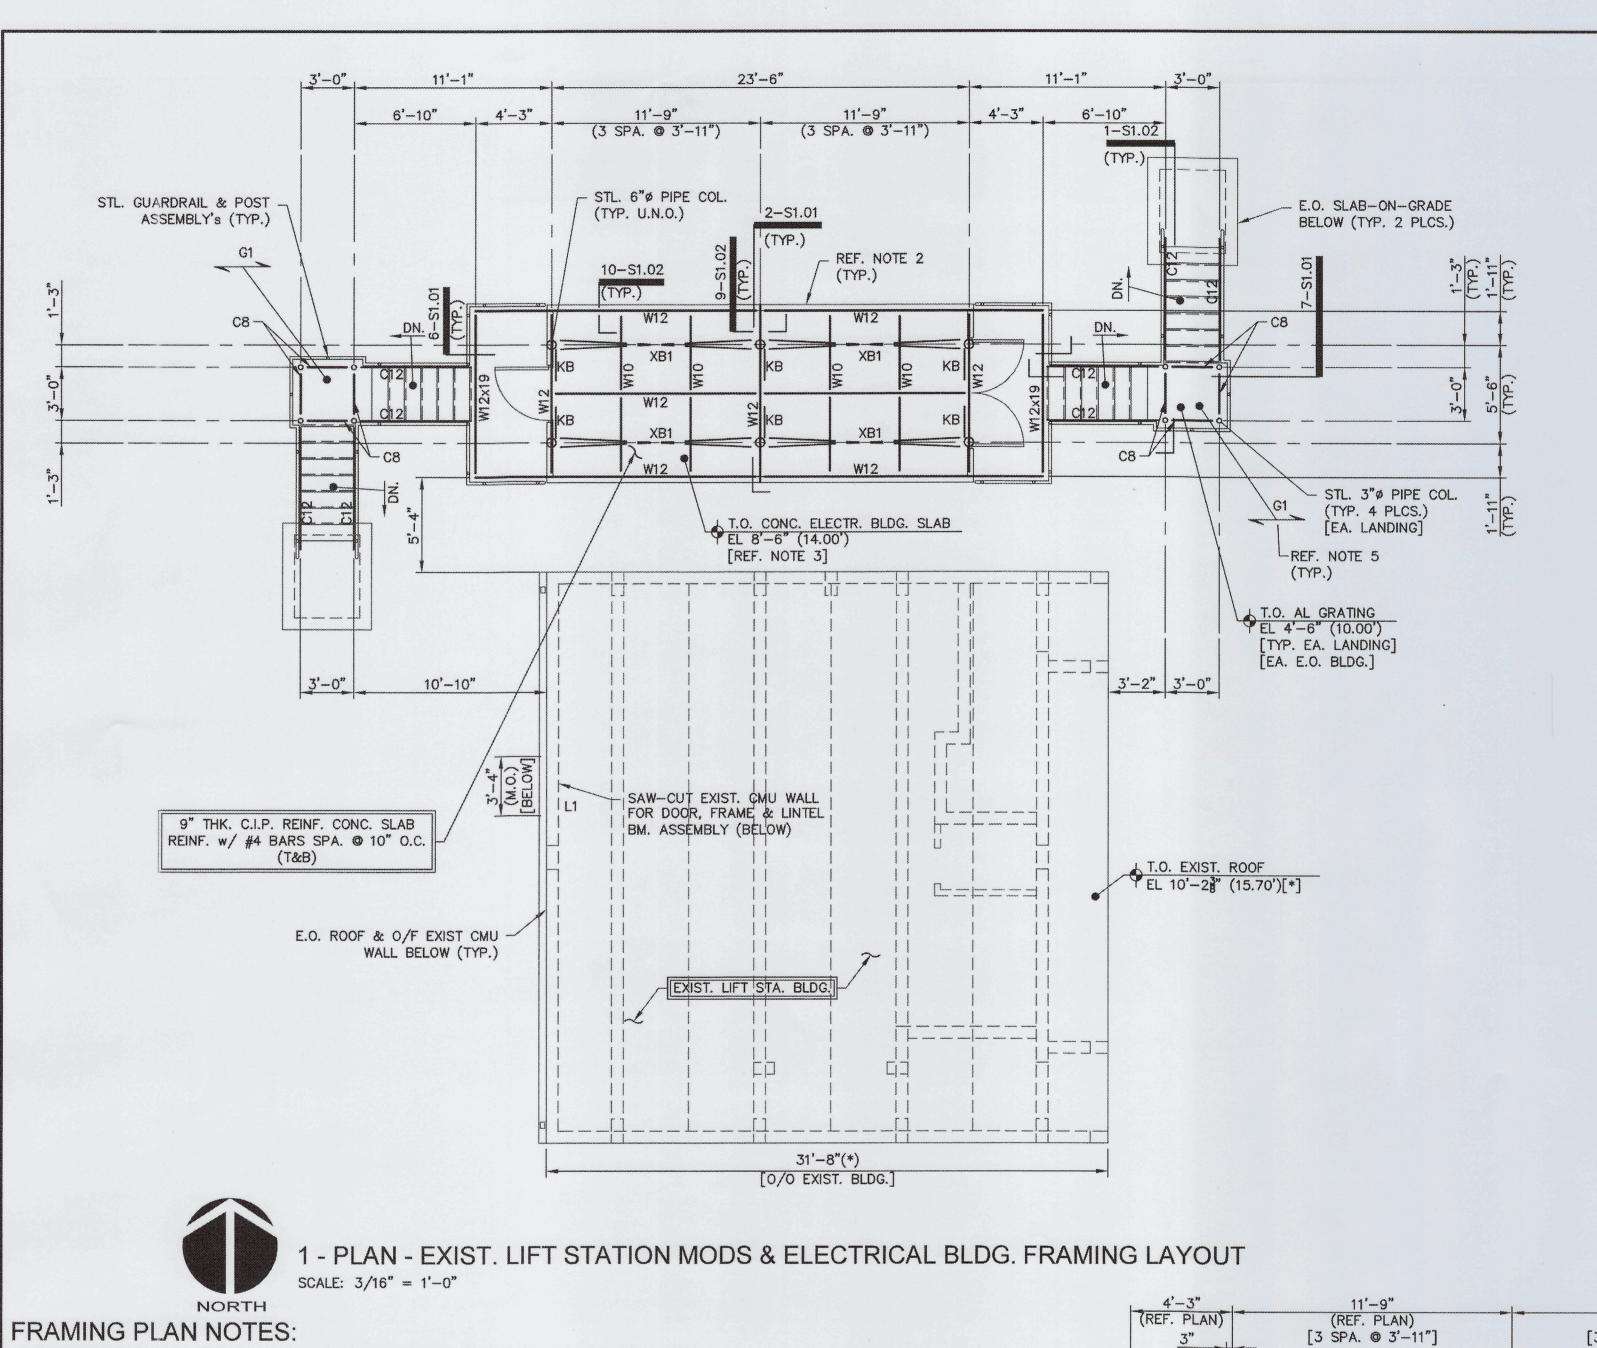


, REFERENCE BLDG. MFG.'s "APPROVED" SUBMITTAL FOR WALL THICKNESS & CONNECTIONS TO THE SLAB-ON-GRADE. . PREPARE COMPACTED SUBGRADE IN CONFORMANCE w/ THE PROJECT GEOTECHNICAL REPORT. 3. COORD. w/ OWNER DURING SHOP DWG. SUBMITTAL REVIEWS DURING CONSTR. REGARDING BLOCK EXTERIOR SURFACE FINISH TO BE PROVIDED. 9'-4"

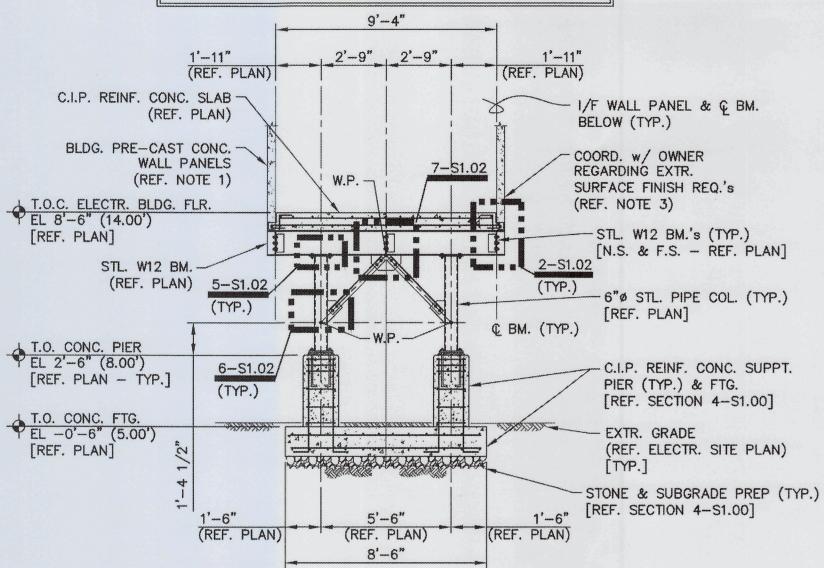

2 - SECTION - THRU ELECTR. BLDG. SUPPT. ASSEMBLY SCALE: 1/4" = 1'-0"

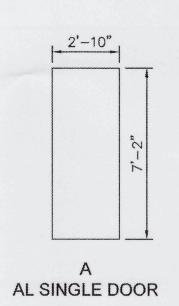

3 - DETAIL - EXIST. BLDG. MOD.'s DOOR TYPES SCALE: 1/4" = 1'-0"

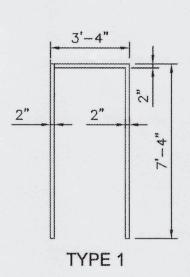

4 - DETAIL - EXIST. BLDG. MOD's DOOR FRAME TYPES SCALE: 1/4" = 1'-0"

	DOOR & FRAME SCHEDULE													
DOOR	UL -	······································	DOOR							FRAME	m mm	······································	HDW.	
NO.	LABEL -	MARTIL	SIZE			TYPE	GLAZING	MAT'L	TYPE	YPE DETAILS		SET	REMARKS	
		***************************************			***************************************						JAMB	SILL	-	
(D1)	N/A	2'-10"	7'-2"	13/4"	AL	Α	N/A	AL.	1	*1	*1	*1	*2	REF. 3-S1.01 & 4-S1.01
***************************************														
AL -A IAL -IN SCW-S	WIDTH HEIGHT THK. WILL HEAD JAMB SILL								LAN	1 - LAN	IINATE			REF. ?.S1.01 FOR HEAD, JAMB & SILL DETAILS. REF. PLAN NOTES & PROJECT SPECS.

5 - SCHEDULE - DOORS & FRAMES SCALE: N.T.S.

1. REFERENCE ELEVATION FOR THE ELECTRICAL BUILDING ADDITION AT THE EXISTING LIFT STATION FACILITY IS THE EXISTING LIFT STATION BLDG.'S OPERATING FLOOR LEVEL TOP SLAB T.O. CONC. EL 0'-0" = EL 0'-0" (5.50'). CONTRACTOR SHALL VERIFY VERTICAL DATUM INDICATED EQUALS N.A.V.D.-88. REFERENCE ELECTRICAL SITE PLAN DRAWINGS FOR ADDITIONAL INFORMATION.

2. APPROXIMATE OUTLINE OF 24'-0" LONG x 10'-0" WIDE PRE-CAST CONCRETE ELECTRICAL BUILDING ASSEMBLY. REFERENCE ELECTR. DWG.'s & PROJECT

SPECIFICATIONS FOR ADD'L INFO. 3. EQUIPMENT LAYOUTS ARE SHOWN FOR GENERAL INFO ONLY. REFERENCE ELECTRICAL & EQUIPMENT VENDOR DRAWINGS FOR LOCATIONS & INFO REGARDING SLAB & WALL PENETRATIONS AND PIPING, CONDUIT & MISCELLANEOUS EQUIPMENT LAYOUTS EITHER SHOWN OR NOT SHOWN.

4. REGARDING STEEL FRAMING ASSEMBLIES NOTE THE FOLLOWING:

W12 = W12 $\times$ 35 WIDE FLANGE SECTION.

C12 = C12x20.7 CHANNEL SECTION W10 = W10x19 WIDE FLANGE SECTION.

 $C8 = C8 \times 11.5$  CHANNEL SECTION. 6"ø = SCHEDULE 80 PIPE SECTION

REQUIREMENTS, DESIGN CRITERIA AND LEGEND.

3"ø = SCHEDULE 40 PIPE SECTION.

= L3x3x¾ ANGLE SECTION.

XB1 =  $L3 \times 3 \times \frac{3}{2}$  ANGLE SECTION. 5. " - " SYMBOL ON PLAN INDICATES SPAN DIRECTION OF THE STEEL BAR GRATING ASSEMBLIES MAIN BEARING BARS. IN GENERAL GRATING ASSEMBLIES ARE TO BE MANUFACTURED BY REPUTABLE VENDOR(S) EXPERIENCED IN MANUFACTURING THE ASSEMBLIES REQUIRED. GRATING ASSEMBLIES ARE TO INCLUDE RECTANGULAR MAIN BEARING BARS, RECTANGULAR CROSS BARS OR RODS AND RECTANGULAR BEARING BARS ALONG PERIMETERS OF PANELS AND OPENINGS. FABRICATE ASSEMBLIES W/ GALV'D STEEL FINISH & CONNECTED TO FORM STANDARD PANEL WIDTHS. REFERENCE PLANS, SECTIONS & DETAILS FOR ADDITIONAL INFORMATION & REQUIREMENTS. NOTE THE FOLLOWING:

a.) GRATING "G1" = 11" LIGHT DUTY WELDED STEEL IN ACCORDANCE w/ MFG.'s 19-4 "W" SERIES SPACE PROFILE.


b.) GRATING PANELS SHALL BE ANCHORED TO STEEL FRMG. w/ GALV'D STL. FASTENERS & TYPE AS RECOMMENDED BY THE MANUFACTURER.

6. REFERENCE DWG. SO.00 FOR ADDITIONAL GENERAL NOTES, MATERIAL SPECIFICATIONS &


c.) COORDINATE w/ THE OWNER REGARDING PANEL ASSEMBLIES INCLUDING SERRATED TOP SURFACE SKID FINISH FOR SLIP RESISTANCE.


11'-9" (REF. PLAN) 4'-3" (REF. PLAN) [3 SPA. @ 3'-11"] (TYP.) GALV'D STL. GUARD RAIL ASSEMBLY (REF. PLAN) BLDG. PRE-CAST CONC. -4-S1.02 WALL PANELS - W10x19 STL. BM.'s (REF. NOTE 1) C.I.P. REINF. CONC. SLAB -(TYP. EA. BAY) W12x35 STL. BM.'s (TYP. U.N.O.) (REF. PLAN) [REF. PLAN] [REF. PLAN] T.O.C. ELECTR. BLDG. FLR. EL 8'-6" (14.00') [REF. PLAN] 8-S1.02 (TYP.) - W12x19 STL. BM. (REF. PLAN) 6"ø STL. PIPE COL. [TYP. EA. END] (REF. PLAN) [TYP.] T.O. CONC. PIER EL 2'-6" (8.00') C.I.P. REINF. CONC. SUPPT. -L3x3x X.B. (TYP.) PIER's & FTG.'s (TYP.) [REF. PLAN] [REF. PLAN] [REF. SECTION 4-S1.00] T.O. CONC. FTG. EL -0'-6" (5.00') [REF. PLAN] EXTR. GRADE (REF. ELECTR. SITE PLAN) REF. DETAIL 6-S1.02 (SIM.) [TYP. COL. X.B. CONNI's] © FTG., PIER & COL. ABOVE STONE & SUBGRADE PREP (TYP.) [REF. SECTION 4-S1.00] 6 - SECTION - THRU ELECTR. BLDG. SUPPT. ASSEMBLY

SCALE: 1/4" = 1'-0"

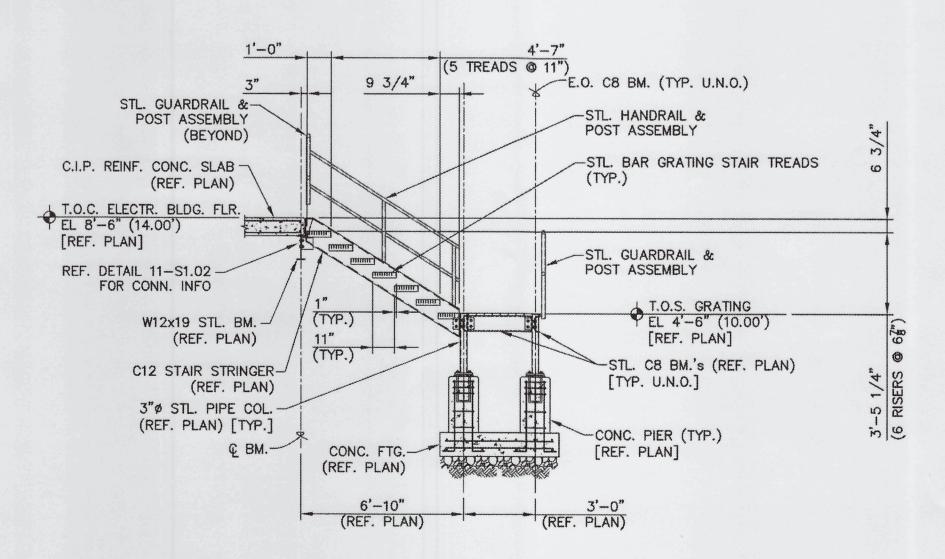

7 - SECTION - THRU "HI" EAST ACCESS STAIR ASSEMBLY SCALE: 1/4" = 1'-0"

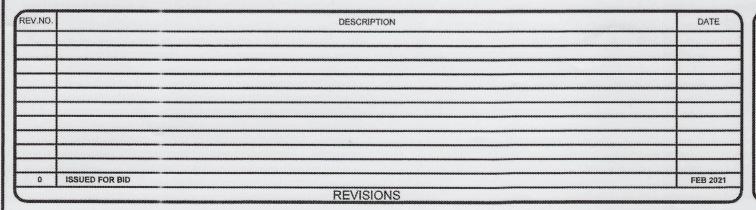

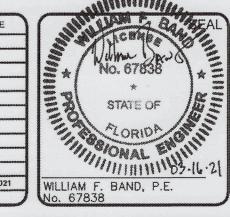







#### **LIFT STATION 12A ELECTRICAL PUMP & VFD REHABILITATION**


STRUCTURAL

LIFT STA. MODS & ELECTR. BLDG. FRMG. **PLAN, SECTIONS & DETAILS** 

PROJ. START DA	TE: 2020. JUN	SCALE	
MCE PROJ. #	01024-0181		10 12
DRAWN	DAR/WFB	HORIZONTAL:	01.01
DESIGNED	WFB	AS NOTED	DRAWING NUMBER
CHECKED	WFB / AEA	VERTICAL:	0
PROJ. MGR.	AAH	NA	REVISION

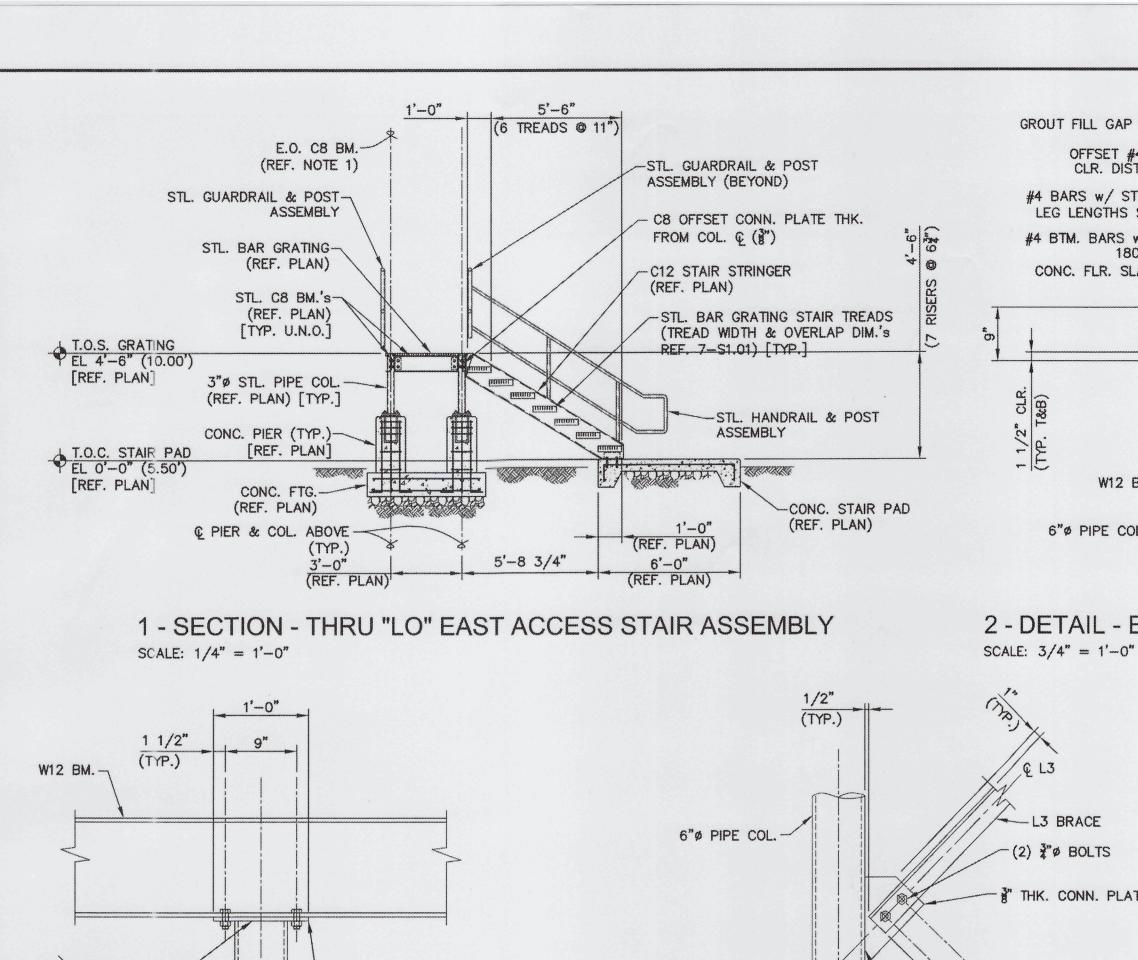

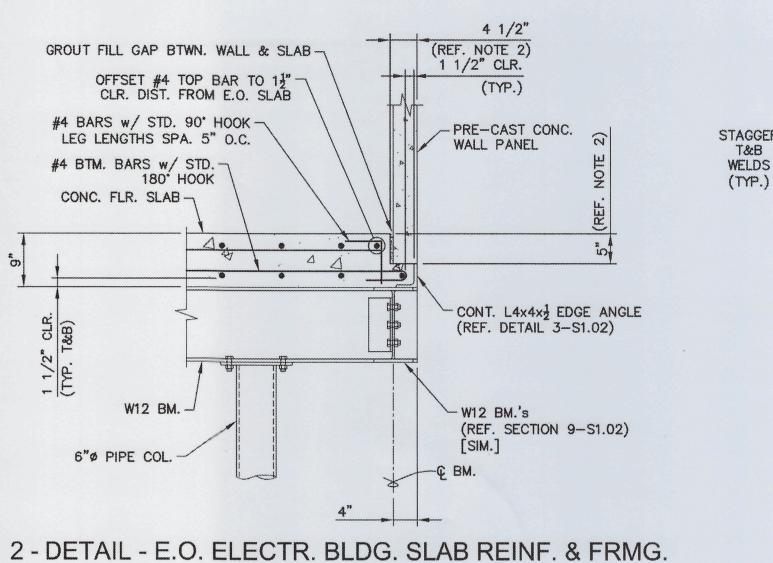


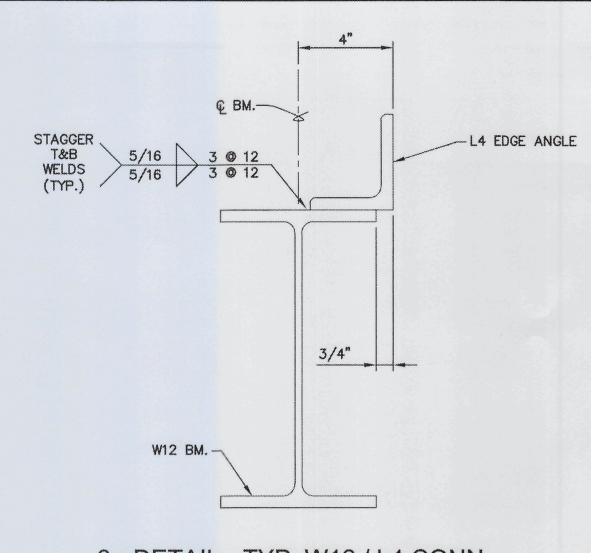


O/F WALL PANEL - PRE-CAST CONC. WALL PANEL GROUT FILL GAPS BTWN. WALL & SLAB-#4 TOP BARS w/ 90" HOOK --5" WIDE x 5" DEEP SLAB POCKET (REF. NOTE 2) CONC. FLR. SLAB -ADD'L #4 STRAIGHT BARS SPA. @ 5" O.C. (BTM.) ADD'L #4 BARS OFFSET AS—
REQ'D & 1½" CLR. DIST. FROM
E.O. SLAB (T&B) [EA. SIDE] [TYP. EA. INTR. POCKET]

3 - DETAIL - TYP. W12 / L4 CONN. SCALE: 3'' = 1'-0''


4 - DETAIL - INTR. ELECTR. BLDG. SLAB REINF. SCALE: 3/4" = 1'-0"

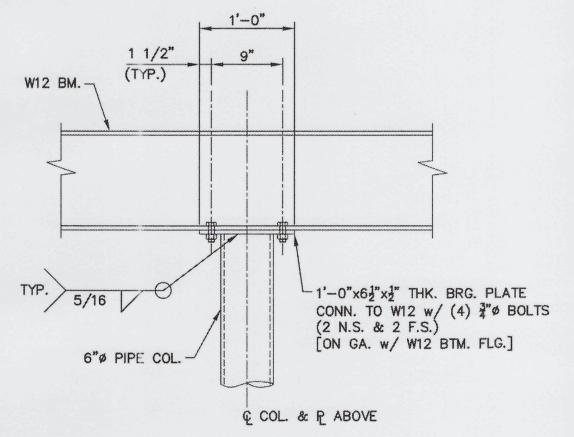


5 - DETAIL - 6"Ø PIPE COL. / W12 BM. CONN. SCALE: 1" = 1'-0"

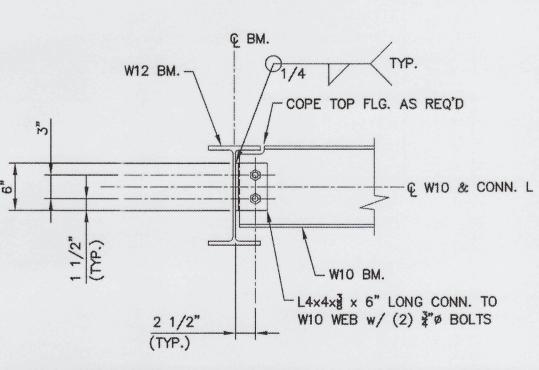


10 - SECTION - W12 BM. / W10 BM. CONN. SCALE: 1" = 1'-0"

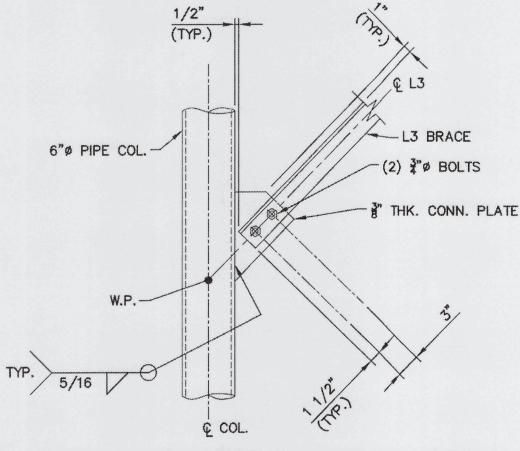

6 - DETAIL - 6"Ø PIPE COL. / L3 K.B. CONN. SCALE: 1" = 1'-0"

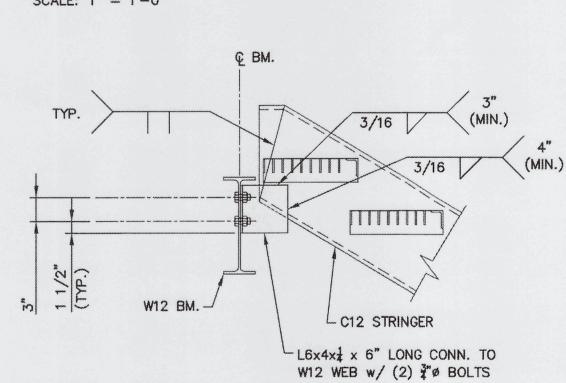


11 - DETAIL - W12 BM. / C12 STRINGER CONN. SCALE: 1" = 1'-0"

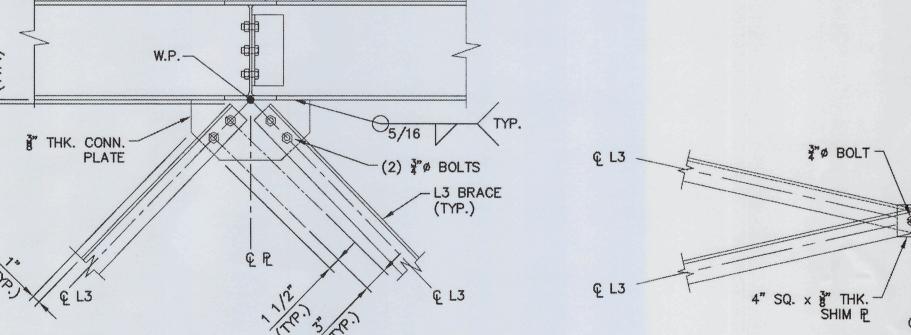


W12 BM.'s (REF. DETAIL 10-S1.02)

7 - DETAIL - W12 BM. / L3 K.B. CONN. SCALE: 1" = 1'-0"

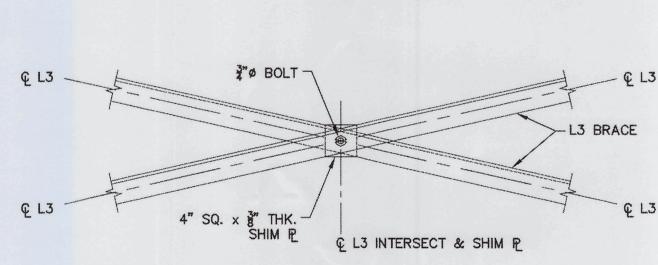

8 - DETAIL - L3 / L3 X.B. CONN. SCALE: 1" = 1'-0"

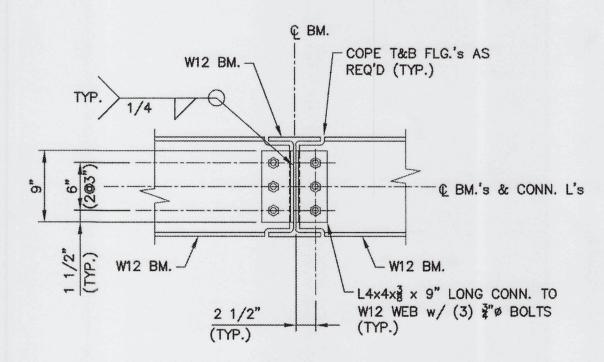


9 - SECTION - W12 BM. / W12 BM. CONN. SCALE: 1" = 1'-0"

### NOTES:

- 1. IN GENERAL THE FLAT E.O. CHANNEL FLG.'s/WEB'S EQUALS THE COLUMN CENTERLINE &
- OFFSET CONNECTION TAB PLATES AS REQUIRED U.N.O..
- 2. SLAB POCKET DEPTH & WIDTH PER REQ.'s OF THE PRECAST BLDG. MFG..
- 3. REFERENCE DWG. SO.00 FOR ADDITIONAL GENERAL NOTES, MATERIAL SPECIFICATIONS & REQUIREMENTS, DESIGN CRITERIA AND LEGEND.

REV.NO.	DESCRIPTION	DATE
a locien explan		EED 2

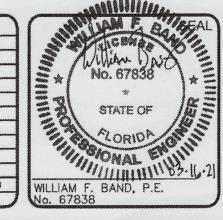







#### LIFT STATION 12A ELECTRICAL PUMP & VFD REHABILITATION

STRUCTURAL

LIFT STA. MODS ADD'L SECTIONS & **DETAILS** 

PROJ. START DA	TE: 2020. JUN	SCALE	
MCE PROJ. #	01024-0181		CAL
DRAWN	DAR/WFB	HORIZONTAL:	91.0
DESIGNED	WFB	AS NOTED	DRAWING NUM
CHECKED	WFB / AEA	VERTICAL:	
PROJ. MGR.	AAH	NA	REVISION

#### FIRE ALARM SYSTEM **ABBREVIATIONS** NOTE: ALL ABBREVIATIONS MAY NOT BE UTILIZED FOR THIS AUDIO/VISUAL ALARM INDICATOR A/V 110 (HORN/STROBE) NUMBER INDICATES NON-AUTOMATIC A, AMP STROBE CANDELLA RATING WHEN OTHER THAN 15 ADJUSTABLE FREQUENCY DRIVE NOT APPLICABLE NORMALLY CLOSE ABOVE FINISHED FLOOR NATIONAL ELECTRIC CODE AFG ABOVE FINISHED GRADE HORN NEUTRAL AIR HANDLING UNIT NORMALLY OPEN AIC AMPERE INTERRUPTING CAPACITY AIT ANALYTICAL INDICATION TRANSMITTER NOT IN CONTRACT MANUAL PULL STATION ALUMINUM NOT TO SCALE ARC-FLASH REDUCTION SYSTEM OFCI OWNER FURNISHED, CONTRACTOR INSTALLED ARMS AUTOMATIC TRANSFER SWITCH ATS OVERLOAD RELAY FACP FIRE ALARM CONTROL PANEL PUBLIC ADDRESS AMERICAN WIRE GAUGE AQD ARC QUENCHING DEVICE PUSH BUTTON ALL ELECTRICAL WORK SHALL COMPLY WITH THE CURRENT NFPA, NEC, NESC AND LOCAL CODES INCLUDING OWNERS STANDARDS AND REQUIREMENTS. BKR BREAKER PULL BOX PUMP CONTROL PANEL BLDG BUILDING BUTTERFLY VALVE POWER FACTOR BELL POWER FACTOR CORRECTION CAPACITORS CONDUIT CAB CABINET PULL FUSE DISCONNECT CIRCUIT BREAKER FAAS FIRE ALARM ANNUNCIATOR STATION CBV CABLE BY VENDOR, INSTALLED BY CONTRACTOR PRESSURE INDICATION TRANSMITTER CCTV CLOSED CIRCUIT TELEVISION PROGRAMMABLE LOGIC CONTROLLER REPRESENTATIVE. CKT CIRCUIT FLOW SWITCH CLG CEILING POWER PANEL, POWER POLE CL2 CHLORINE 2. ELECTRICAL EQUIPMENT: CP CONTROL PANEL PRIMARY CONTROL POWER TRANSFORMER VALVE TAMPER SWITCH PRESSURE SWITCH CONTROL RELAY, CORROSION RESISTANT POTENTIAL TRANSFORMER CS CONTROL STATION PAN-TILT-ZOOM CT CURRENT TRANSFORMER -POLYVINYL CHLORIDE END OF LINE RESISTOR CTRL CONTROL REC RECEPTACLE COPPER REQ'D REQUIRED CV CONTROL VALVE RGS RIGID GALVANIZED STEEL (FD FLAME DETECTOR DB DECIBEL RMC RIGIDREMOTE TELEMETRY UNIT DC DCS DETD DIRECT CURRENT R/S RUN/STOP HAND SWITCH DISTRIBUTED CONTROL SYSTEM REDUCED VOLTAGE SOFT STARTER DUAL ELEMENT TIME DELAY SCCR SHORT CIRCUIT CURRENT RATING SMOKE DETECTOR, MULTISENSOR DISC DISCONNECT SCADA SUPERVISORY CONTROL AND DATA ACQUISITION DN SECONDARY SEC DPDT DOUBLE POLE DOUBLE THROW SPARE DISCONNECT SWITCH **SPECIFICATION** SMOKE DETECTOR IONIZATION DWG DRAWING SURGE PROTECTION DEVICE EMPTY CONDUIT SELECTOR SWITCH EXHAUST FAN SST STAINLESS STEEL EHH ELECTRICAL HANDHOLE SOLENOID VALVE EL, ELEV ELEVATION SWITCH SMOKE DETECTOR PHOTOELECTRIC ELECTRONIC TRIP UNIT SWITCHBOARD **EMER EMERGENCY** SWGR SWITCH GEAR EMH ELECTRICAL MANHOLE TELEPHONE ELECTRICAL METALLIC TUBING DUCT MOUNTED SMOKE DETECTOR **TEMPERATURE** ENCL **ENCLOSURE** TEW THERMOCOUPLE EXTENSION WIRE **EPRF EXPLOSION PROOF** TMTU THERMAL-MAGNETIC TRIP UNIT **EQUIP** EQUIPMENT TEMPERATURE SWITCH EWC ELECTRIC WATER COOLER THERMAL DETECTOR **TYPICAL** ELECTRIC WATER HEATER (FIXED AND RATE OF RISE) **UNDERGROUND EXIST** EXISTING H-HIGH TEMPERATURE UNIT HEATER FA FIRE ALARM UON UNLESS OTHERWISE NOTED FIRE ALARM ANNUNCIATOR PANEL UNINTERRUPTIBLE POWER SUPPLY FIRE ALARM CONTROL PANEL CT SIGNAL INPUT MODULE FDR FEEDER VOLTS ALTERNATING CURRENT FIXT FIXTURE VFD VARIABLE FREQUENCY DRIVE FLA FULL LOAD AMPS WATT-HOUR FLOUR FLUORESCENT CC1 SIGNAL MODULE WEATHERPROOF FMC FLEXIBLE METALLIC CONDUIT 4. CABLES/CONDUCTORS/WIRES: TRANSFORMER FLOW SWITCH **EXPLOSION PROOF** FEET OR FOOT 4.1. GENERAL FUT **FVNR** FULL VOLTAGE NON-REVERSING STARTER FURNISHED WITH EQUIPMENT GROUND GALVANIZED GEC GROUNDING ELECTRODE CONDUCTOR 4.2. POWER/FEEDER GEN GENERATOR GFI GROUND FAULT INTERRUPTER GFIC GROUND FAULT CIRCUIT INTERRUPTER HDG HOT DIPPED GALVANIZED HANDHOLE HAND-OFF-AUTO 4.3. POWER/BRANCH HORSE POWER HIGH POWER FACTOR HIGH PRESSURE SODIUM HEATER 5. HARDWARE AND SUPPORTS: HIGH VOLTAGE HV HERTZ INTERIOR DIAMETER INTERMEDIATE METALLIC CONDUIT (GALVANIZED) INTERMEDIATE METALLIC INCHES INSTRUMENT TERMINAL BOX JUNCTION BOX THOUSAND KA KILOVOLT AMPERE KAIC THOUSAND AMPERES INTERRUPTING CURRENT KCMIL THOUSAND CIRCULAR MILLS 6. RECEPTACLES/SWITCHES: KVA THOUSAND VOLT AMPERES KILOWATTS 6.1. GENERAL KILOWATT-HOURS LIGHTNING ARRESTOR LOCAL CONTROL PANEL LED LIGHT-EMITTING DIODE LFMC LIQUIDTIGHT FLEXIBLE METAL CONDUIT LIQUIDTIGHT FLEXIBLE NONMETALLIC CONDUIT LEVEL INDICATION TRANSMITTER LIGHTING PANEL, LIGHT POLE LEVEL SWITCH LIGHTING LOW VOLTAGE MOTOR MILLIAMPERE MAIN CIRCUIT BREAKER MOTOR CONTROL CENTER MOTOR CIRCUIT PROTECTOR MAIN DISTRIBUTION PANEL MANUFACTURER MANHOLE MINIMUM MAIN LUGS ONLY MSB MAIN SWITCHBOARD MTD MOUNTED/MOUNTING MTG MOUNTING MTS MANUAL TRANSFER SWITCH MEDIUM VOLTAGE DESCRIPTION

#### GENERAL ELECTRICAL NOTES


#### 1. CONTRACTOR RESPONSIBILITIES:


- 1.1. THE CONTRACTOR SHALL READ AND UNDERSTAND THE ENTIRE SET OF CONSTRUCTION DOCUMENTS. THIS INCLUDES BUT IS NOT LIMITED TO THE PLANS AND SPECIFICATIONS FOR ALL DISCIPLINES. THIS WILL ENSURE THAT HE UNDERSTANDS THE FULL SCOPE OF WORK AND IS ABLE TO CONVEY THE REQUIRED MATERIALS AND METHODS OF INSTALLATION TO THE HIS ESTIMATORS, SUPPLIERS AND INSTALLERS.
- THE CONTRACTOR SHALL VISIT THE SITE AND FAMILIARIZE HIMSELF WITH THE EXISTING CONDITIONS.
- 1.3. PROVIDE MEANS TO FURNISH AND INSTALL.
- THESE DRAWINGS ARE DIAGRAMMATIC IN NATURE. DO NOT SCALE FROM THESE DRAWINGS.
- WHERE JOB CONDITIONS REQUIRE CHANGES FROM THE CONTRACT DOCUMENTS THAT DO NOT CHANGE THE SCOPE OF INSTALLATION OR NATURE OF THE WORK REQUIRED, THE CONTRACTOR SHALL MAKE SUCH CHANGES WITHOUT ANY ADDITIONAL COST TO THE OWNER. NO OTHER CHANGES MAY BE MADE WITHOUT WRITTEN CONSENT FROM THE ENGINEER AND OWNER.
- MOUNTING HEIGHTS INDICATED ARE TO THE CENTER OF THE DEVICE U.O.N.
- REFERENCE ALL SPECIFICATIONS, DRAWINGS AND CONTRACT DOCUMENTS FOR ADDITIONAL REQUIREMENTS AND CONTRACT RESPONSIBILITIES PRIOR TO COMMENCING WORK.
- 1.8. THE GENERAL NOTES STATED ON THIS DRAWING ARE APPLICABLE TO ALL DRAWINGS AND SCOPE OF WORK UNDER THIS CONTRACT UNLESS NOTED OTHERWISE.
- CONTRACTOR SHALL COORDINATE WITH THE LOCAL ELECTRICAL UTILITY TO ESTABLISH NEW ELECTRICAL SERVICE(S) AND FINAL CONNECTIONS TO PROVIDE UTILITY POWER AS REQUIRED TO INCLUDE ESTABLISHING TEMPORARY UTILITY ACCOUNT TO PROVIDE ELECTRICAL POWER FOR START-UP AND COMMISSIONING.
- 1.11. THE ELECTRICAL INSTALLATION SHALL EXCEED THE REQUIREMENTS OF ALL APPLICABLE NECA/NEIS STANDARDS.
- 1.12. CONTRACTOR SHALL PLAN AND COORDINATE ELECTRICAL CONSTRUCTION WITH ALL CRAFT/TRADE TO ACHIEVE AN EFFICIENT AND EFFECTIVE ELECTRICAL INSTALLATION.
- THE SCHEDULING AND DURATION OF ANY PROCESS OR FACILITY SHUTDOWN TO REMOVE AND/OR INSTALL EQUIPMENT SHALL BE COORDINATED IN ADVANCE WITH FACILITY MANAGEMENT, ENGINEER, OWNER OR OWNER
- 2.1. 600V RATED ELECTRICAL EQUIPMENT SHALL HAVE AN AMPERE INTERRUPTING CAPACITY (AIC) RATINGS AS SHOWN ON THE CONTRACT DRAWINGS.
- 2.2. EQUIPMENT SHALL BE ARRANGED AND INSTALLED TO COMPLY WITH ALL CODE-REQUIRED, MANUFACTURER-RECOMMENDED AND HEAT-DISSIPATION CLEARANCES.
- 2.3. EQUIPMENT INSTALLATIONS AND PLACEMENTS SHALL COMPLY WITH NEC ARTICLE 110 FOR ALL CLEARANCE REQUIREMENTS.
- 2.4. EQUIPMENT SHALL FIT INTO THOSE SPACES AS SHOWN ON THE CONTRACT DRAWINGS. CONTRACTOR IS RESPONSIBLE TO PROVIDE EQUIPMENT WHICH MEETS THE SPACE REQUIREMENTS.
- 2.5. CONTRACTOR SHALL PROVIDE ALL NECESSARY COMPONENTS REQUIRED FOR MAKING FINAL CONNECTIONS FOR ALL EQUIPMENT INSTALLED AND/OR MODIFIED UNDER CONTRACT.

#### 3. POWER AND CONTROL SYSTEM RACEWAYS:

- 3.1. EXPOSED CONDUIT SHALL BE RIGID ALUMINUM CONDUIT (RAC), GRS, IMC AND EMT ARE NOT ACCEPTABLE.
- 3.2. CONCEALED CONDUIT EMBEDDED IN CONCRETE SHALL BE SCH-40 PVC
- 3.4. DIRECT-BURIED CONDUIT SHALL BE DIRECT-BURIED SCH-80 PVC
- TRANSITIONS THROUGH FINISHED GRADE AND/OR CONCRETE SHALL BE PVC-COATED RAC CONDUIT.
- DRAWINGS DEPICT MAJOR DUCTBANK. CABLE-TRAY. BUS-DUCT. WIRE-WAY, TRENCH/FLOOR DUCTS, RACEWAY, CONDUIT, ETC., TO INCLUDE CABLE, CONDUCTOR AND WIRING IN SCHEMATIC AND/OR DIAGRAMMATIC FORMATS. THE CONTRACTOR SHALL REFERENCE ALL EQUIPMENT SPECIFICATIONS AND MANUFACTURER INSTRUCTIONS FOR ADDITIONAL INSTALLATION REQUIREMENTS.
- RACEWAY INSTALLATION AND/OR ARRANGEMENT LAYOUTS ARE NOT TYPICALLY SHOWN ON THE DRAWINGS. CONTRACTOR SHALL DEVELOP LOGICAL GROUPINGS, ROUTING AND MARSHALLING OF DUCTBANK, CABLE-TRAY, BUS-DUCT, WIRE-WAY, TRENCH/FLOOR DUCT, RACEWAY, CONDUIT, ETC., THESE SHALL NOT BE ROUTED THROUGH OR INTERFERE WITH ANY STRUCTURAL ELEMENTS. CONTRACTOR SHALL SUBMIT THESE RACEWAY INSTALLATION AND/OR ARRANGEMENT LAYOUTS PER THE SPECIFICATIONS FOR ENGINEER REVIEW PRIOR TO INSTALLATION.
- 3.8. RACEWAY ROUTINGS SHALL BE ORGANIZED AND GROUPED IN A PRACTICAL MANNER TO MINIMIZE CROSS-OVERS AND SADDLES. RACEWAY INSTALLATIONS SHALL BE ARRANGED TO ENTER EQUIPMENT FOR DIRECT
- RACEWAYS SHALL BE INSTALLED CONCEALED UNLESS OTHERWISE NOTED OR SHOWN. THESE SHALL RUN PARALLEL TO LANDSCAPE AND STRUCTURAL FEATURES WHILE THE BENDS AND TURNS SHALL BE MADE BY MEANS OF LARGE RADII FITTINGS.
- 3.10. PROVIDE FLEXIBLE RACEWAY CONNECTIONS TO ALL EQUIPMENT SUBJECT TO MOVEMENT AND/OR VIBRATION. CONTRACTOR SHALL MAKE RACEWAY CONNECTIONS COMPLETE AND IN ACCORDANCE WITH THE
- 3.11. CONTRACTOR SHALL PROVIDE ALL REQUIRED PULL BOXES, TERMINAL BOXES AND JUNCTION BOXES FOR INSTALLATION FOR THE WIRING SYSTEMS IN ACCORDANCE WITH THE SPECIFICATIONS THOUGH ALL BOXES MAY NOT BE INDICATED ON THE DRAWINGS.
- 3.12. SPARE CONDUITS SHALL BE CAPPED OR PLUGGED WITH A PVC FITTING AND INCLUDE 200# TEST POLYPROPYLENE PULL STRING.

- 4.1.1. QUANTITY AND SIZING OF CONDUCTORS, CABLING, WIRING AND RESPECTIVE RACEWAYS DEPICTED ON THE DRAWINGS ARE BASED UPON SELECTED STANDARD ELECTRICAL COMPONENTS OR EQUIPMENT WITH DIRECT ROUTED CONNECTIONS. CONTRACTOR MAY SUBMIT FOR REVIEW BY ENGINEER AND PRIOR TO INSTALLATION, LOGICAL CONDUCTOR AND RACEWAY GROUPINGS IN COMPLIANCE WITH APPLICABLE CODES, STANDARDS AND SPECIFICATIONS WITHOUT ADDITIONAL COST TO OWNER.
- 4.1.2. CONTRACTOR SHALL PROVIDE A CIRCUIT IDENTIFICATION LABEL AT EACH END OF EACH POWER, BRANCH, CONTROL AND INSTRUMENTATION CIRCUIT CABLE ASSEMBLY, CONDUCTOR OR WIRE.
- 4.2.1. CONTRACTOR SHALL NOT EXCEED CABLE MANUFACTURER SPECIFICATIONS FOR SIDE-WALL AND TENSION LIMITS WHEN DRAWING POWER CABLES INTO RACEWAYS.
- 4.2.2. CONTRACTOR SHALL DRAW POWER CABLES AND CONDUCTORS WITHIN RACEWAYS UTILIZING POLYWATER LUBRICANT J OR APPROVED EQUAL.
- 4.2.3. NO SPLICES TO POWER CONDUCTORS AND/OR CABLING SHALL BE MADE WITHOUT ENGINEER APPROVAL. NO JUNCTIONS SHALL BE MADE BELOW GRADE WITHOUT APPROVAL OF ENGINEER.
- 4.3.1. RACEWAY AND WIRING FOR LIGHTING, RECEPTACLES AND BRANCH CIRCUITS ARE NOT TYPICALLY SHOWN ON THE CONTRACT DRAWINGS BUT SHALL BE PROVIDED AS REQUIRED UNDER THIS CONTRACT
- 5.1. ALL FASTENERS AND HARDWARE SHALL BE STAINLESS-STEEL 316L.
- 5.2. STRUT-CHANNEL SHALL NOT BE BENT, DRILLED, CUT OR OTHERWISE MODIFIED TO PRODUCE FITTINGS, BRACES OR BRACKETS FOR CONDUIT AND EQUIPMENT SUPPORTS.
- 5.3. MANUFACTURED STRUT-CHANNEL BRACES, BRACKETS, FITTINGS OR POST BASES SHALL BE PROVIDED AND INSTALLED WITH ASSOCIATED HARDWARE AND FASTENERS FOR CONDUIT AND EQUIPMENT SUPPORTS.
- 5.4. CONTRACTOR SHALL PROVIDE ALL SUPPORTS AND FASTENING HARDWARE FOR SWITCHBOARDS, PANELBOARDS, TRANSFORMERS, CONTROL PANELS, ETC., AS REQUIRED IN THE SPECIFICATIONS.
- 5.5. CONTRACTOR SHALL PROVIDE AND INSTALL CONCRETE EMBEDDED LEVELING CHANNEL SUPPORTS FOR FLOOR MOUNTED EQUIPMENT SPANNING DISTANCES 48" AND GREATER IN LENGTH OR 36" AND GREATER IN DEPTH. 5.6. STRUCTURAL MEMBERS SHALL NOT BE DRILLED, CUT, WELDED TO, OR OTHERWISE MODIFIED WITHOUT PRIOR APPROVAL OF THE ENGINEER OF RECORD.
- 6.2.0.2. INDOORS OR NON PROCESS AREAS SHALL BE INSTALLED CONCEALED AND FLUSH WITH STAINLESS-STEEL DEVICE COVER PLATES.
- 6.2.0.3. OUTDOORS OR IN PROCESS AREAS SHALL BE INSTALLED WITHIN WEATHER-PROOF, CORROSION RESISTANT DEVICE BOXES WITH METALLIC IN-USE AND/OR WATER-TIGHT DEVICE COVER PLATES.
- 6.3. RECEPTACLES/GROUND FAULT CURRENT INTERRUPTING (GFCI)
- 6.3.1. SHALL BE INDIVIDUAL GFCI RECEPTACLE DEVICES RATED FOR 20A/120V WITH LED POWER INDICATOR.
- 6.3.2. GFCI RECEPTACLE DEVICES SHALL NOT SHARE NEUTRAL CONDUCTORS ON THREE-PHASE SYSTEMS

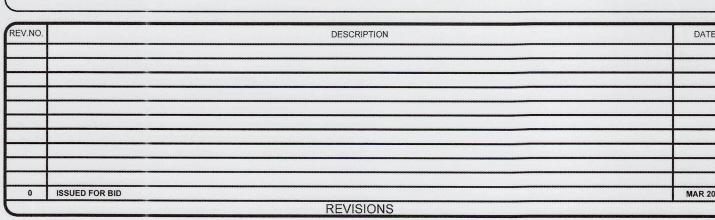

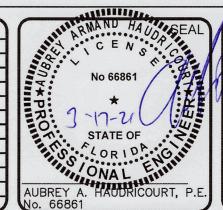





Phone: (727) 442-7196, Fax: (727) 461-3827

CA Lic. No. 29588 www.mckimcreed.com



#### **LIFT STATION 12A ELECTRICAL PUMP &** VFD REHABILITATION

ELECTRICAL


SYMBOLS, ABBRIVIATIONS AND NOTES

PROJ. START DATE: 2020. JUN 01024-018 MCE PROJ. # DRAWN DESIGNED MAC CHECKED AAH PROJ. MGR.

SCALE HORIZONTAL VERTICAL:


1 LIGH	HTING SYMBOLS							2 AUXILIARY	/ SYSTEM
1-3	FLUORESCENT LIGHTING FIXTURE - SURFACE OR PENDANT MOUNTED. FIRST NUMERAL DENOTES LIGHTING PANEL (LP1),		LIGHTING, APPLIANCE OR INSTRUMENT PANELBOARD	050	SWITCH - TEMPERATURE	S	MOTOR STARTER CONTACTOR COIL	DC DC	OR CONTACT
a	SECOND NUMBER DENOTES BRANCH CIRCUIT NUMBER. LOWER CASE LETTER DENOTES SWITCHED CIRCUIT.		POWER PANELBOARD	٦	NORMALLY CLOSED. OPENS ON RISING TEMPERATURE	3	COIL DESIGNATION: S-SLOW	GD GL	ASS-BREAK DETECTOR
	FLUORESCENT LIGHTING FIXTURE WITH BATTERY PACK	СР	CP - CONTROL PANEL	200	SWITCH — TEMPERATURE NORMALLY OPEN. CLOSES ON RISING	FT	MOTOR STARTER CONTACTOR COIL		TION SENSOR
EM	SURFACE OR PENDANT.	MCC	MOTOR CONTROL CENTER		TEMPERATURE		COIL DESIGNATION: FT-FAST		ARD READER
	PENDANT OR CEILING MOUNTED LIGHTING FIXTURE.	T	THERMOSTAT	oLo	SWITCH — FLOW NORMALLY CLOSED	F	MOTOR STARTER CONTACTOR COIL COIL DESIGNATION:		ARD READER
	WALL MOUNTED LIGHTING FIXTURE.	(MD)	MOTORIZED DAMPER	00	SWITCH — FLOW NORMALLY OPEN		F-FOREWARD MOTOR STARTER	IACP IN	RUSION ALARM CONTROL PANEL
7	POLE OR STANCHION MOUNTED LIGHTING FIXTURE.	(LM)	LOUVER MOTOR			R	CONTACTOR COIL COIL DESIGNATION:	ACP AL	ARM CONTROL PANEL
320		$\Box$	MOTOR, UNIT HEATER-NUMERAL DENOTES LIGHTING PANEL AND BRANCH CIRCUIT NUMBER. MOTOR SYMBOL SHOWN	00	SWITCH - LIMIT NORMALLY OPEN		R-REVERSE	FOPP FIE	ER OPTIC PATCH PANEL
Ø OF	TWO (2) POLE OR STANCHION MOUNTED LIGHTING FIXTURES	(M) (M) (UH) OR [ 1-24 1-24 1-24	DASHED DENOTES FOLIDMENT LOCATED ON BOOK	0—10	SWITCH - LIMIT NORMALLY CLOSED	(15)	MOTOR STARTER CONTACTOR COIL COIL DESIGNATION:	OR CCTV CA	MERA
GF CO	POLE MOUNTED FIXTURE WITH GF RECEPTACLE		INDICATES NEW EQUIPMENT/EXPOSED CONDUIT	00	SWITCH — LIMIT HELD CLOSED		1S-REDUCED VOLTAGE CONTACTOR COIL #1		
□ EM	2 LAMP SELF CONTAINED DC EMERGENCY LIGHTING UNIT. LETTER DENOTES FIXTURE TYPE.		CONDUIT TURNING DOWN	000	SWITCH - LIMIT	<b>2</b> S	MOTOR STARTER CONTACTOR COIL		ARM BEACON FTER INDICATES COLOR
፟	EXIT SIGN WALL MOUNTED (SINGLE FACE WITH INDICATING ARROWS) WITH BATTERY PACK ARROW INDICATES DIRECTION	o 	CONDUIT TURNING UP		HELD OPEN		COIL DESIGNATION: 2S—REDUCED VOLTAGE	X SP	EAKER\HORN = HORN
\ \\ \\ \\ \\ \\ \\ \\ \\ \\ \\ \\ \\ \	OF EXIT DOOR		INDICATES EXISTING EQUIPMENT/CONDUIT	9	SWITCH - LIQUID LEVEL	RUN	CONTACTOR COIL #2  MOTOR STARTER		= HORN S = PAGING SPEAKER
181	EXIT SIGN PENDANT MOUNTED (DOUBLE FACE WITH INDICATING ARROWS) WITH BATTERY PACK ARROWS INDICATE DIRECTION OF EXIT DOOR		INDICATES CONDUIT UNDERGROUND OR CONCEALED		NORMALLY OPEN. CLOSES ON RISING LEVEL SWITCH -		CONTACTOR COIL COIL DESIGNATION: R-RUN		
	FIXTURE DESIGNATION SYMBOL. SEE LIGHTING FIXTURE SCHEDULE	<del>//////</del>	IN CEILING, WALLS, BELOW OR IN FLOOR SLAB  DEMOLITION	ofo	LIQUID LEVEL  NORMALLY CLOSED. OPENS ON RISING LEVEL	CR	CONTROL RELAY COIL DESIGNATION:	© °	EILING MOUNTED SPEAKER
10'-0" AFF	FOR DESCRIPTION AND TYPE. ALL FIXTURES SHOWN IN A ROOM WITH THIS SYMBOL SHALL BE OF TYPE INDICATED BY LETTER; NUMBER IN SYMBOL INDICATES LAMP WATTAGE AND NUMBER OF	ЕМН	ELECTRICAL MANHOLE				CR-CONTROL RELAY MX-AUXILIARY RELAY		EXISTING EXTENSION NUMBER
10-0 AFF	LAMPS WHERE MORE THAN ONE (UNLESS OTHERWISE NOTED). NUMBER BELOW SYMBOL INDICATES MOUNTING HEIGHT ABOVE	EHH	ELECTRICAL HANDHOLE	oTo	SWITCH — PRESSURE NORMALLY CLOSED. OPENS ON RISING PRESSURE		TR-TIMING RELAY AR-ALARM RELAY RR-READY RELAY		MMUNICATION/TELEPHONE  = DESK HANDSET AND SYSTEM OUTLET JACK
	FINISHED FLOOR OR AS NOTED.	тмн	TELEPHONE MANHOLE	0 0		H A		W	= WALL HANDSET AND SYSTEM OUTLET JACK
I-2	DUPLEX CONVENIENCE RECEPTACLE, 2 POLE, 3 WIRE, 120 VOLTS A.C. 20 AMP RECEPTACLE DESIGNATIONS, FIRST NUMBER DENOTES PANEL, SECOND NUMBER DENOTES CIRCUIT NUMBER. GF—DENOTES	ТНН	TELEPHONE HANDHOLE	20	SWITCH — PRESSURE NORMALLY OPEN. CLOSES ON RISING PRESSURE	o o (X,0)	SELECTOR SWITCH, 2 POSITION MAINTAINED CONTACT	W	X = EXPLOSION PROOF P = WEATHERPROOF
GF/SS	GROUND FAULT TYPE. SS-DENOTES SURGE SUPPRESSION TYPE WP-DENOTES WEATHERPROOF ENCLOSURE	IMH	INSTRUMENTATION MANHOLE	$- \phi $	VALVE LIMIT SWITCH (OPEN)	○ ○ (0,X)	CONFIGURATION A INDICATES CONTACT		() = KEYSET ) = INTERCOM
0	SINGLE CONVENIENCE RECEPTACLE, 2 POLE, 3 WIRE; 120 VOLTS AC. 20 AMP UNLESS NOTED OTHERWISE ON DRAWINGS.	□ ІНН	INSTRUMENTATION HANDHOLE		VALVE LIMIT CHITCH (CLOCED)	H O A	CLOSED, O DENOTES CONTACT OPEN.		TA OUTLET  OOR MOUNTED DATA OUTLET
•	POWER RECEPTACLE, 2 POLE, 3 WIRE 250 VOLTS A.C. 20 AMP	CRAC	COMPUTER ROOM AIR CONDITIONER	-0-8-	VALVE LIMIT SWITCH (CLOSED)  TORQUE SWITCH, OPENS ON RISING TORQUE			[ <del>_</del>	JND POWERED TELEPHONE
	UNLESS NOTED OTHERWISE ON DRAWINGS.	EIS	EMERGENCY INVERTER SYSTEM	-0_0	TORQUE SWITCH, CLOSES ON RISING TORQUE	0 0	SELECTOR SWITCH, 3 POSITION MAINTAINED CONTACT	FL/	AT CABLE TRANSITION BOX
PU	PAGING UNIT	ATS	AUTOMATIC TRANSFER SWITCH	CRI		0 0			EPHONE PUNCH DOWN BLOCK
LS	PAGING UNIT SPEAKER	(A)	GROUND TEST POINT		NORMALLY OPEN CONTACT, NUMBER INDICATES RELAY.		MAINTAINED CONTACT PUSH BUTTON		VATE BRANCH EXCHANGE
Sª	SINGLE POLE SWITCH — LOWER CASE LETTER DENOTES SWITCHING.		GROUND ROD	*	NORMALLY CLOSED CONTACT	<del>-</del> To J	W/MECHANICAL INTERLOCK		TERNAL PORT NODE
S <sub>2</sub>	TWO POLE SWITCH	• -	GROUND GRID CABLE CONNECTION	OL	THERMALLY ACTUATED MOTOR OVERLOAD RELAY,		ELECTRIC SPACE	F/C FIE	ER CONVERTER
S <sub>3</sub>	THREE-WAY SWITCH		GROUND GROUND	OI.	LATCHES CLOSED ON OVERLOAD		HEATER ELEMENT	LE LIN	E EXTENDER
S <sub>4</sub>	FOUR-WAY SWITCH		#4/0 GROUND CABLE BURIED 2'-6" BELOW GRADE		THERMALLY ACTUATED MOTOR OVERLOAD RELAY, LATCHES OPEN ON OVERLOAD	ETM	ELAPSED TIME METER	PCC PA	GING CONTROL CABINET
ST	24V DC MOMENTARY CONTACT SWITCH - LOWER CASE DENOTES SWITCHING		UNLESS OTHERWISE NOTED			LIN	ELAPSED TIME METER		LTIPLEXOR
	DIMMINO CHITCH I OWED OACE DENOTED CHITCHING		CLASS I COPPER LIGHTNING CONDUCTOR UNLESS OTHERWISE NOTED	90	NORMALLY OPENED CONTACT - TIMED			XCR TR	ANSCEIVER
Sp	DIMMING SWITCH - LOWER CASE DENOTES SWITCHING	PC	PHOTOCELL	NOTC \	CLOSED TIME DELAY AFTER COIL ENERGIZED			MC MC	NITOR
S <sub>M2</sub>	MANUAL MOTOR STARTER — NUMBER DENOTES NUMBER OF POLES WHEN MORE THAN ONE.	•	DEVICE LOCATED IN FIELD AT OR NEAR MOTOR DEVICE LOCATED IN CONTROL PANEL	970	NORMALLY CLOSED CONTACT— TIMED OPEN TIME DELAY AFTER COIL ENERGIZED			Δ <sub>T</sub> T1	DEMARCATION
Sv	VARIABLE SPEED FAN SWITCH	<b>-</b>	INDICATING LIGHT, PT-DENOTES PUSH TO	NCTO ∕				UPS UN	INTERRUPTIBLE POWER SUPPLY
LP1-2	BRANCH CIRCUIT HOME RUN TO PANELBOARD LETTERS AND NUMERALS INDICATE PANEL AND CIRCUIT NUMBER. AS A MINIMUM,		TEST TYPE LETTER INDICATES LENS COLOR  W-WHITE G-GREEN A-AMBER	NOTO	NORMALLY OPEN CONTACT— TIMED OPEN TIME DELAY AFTER COIL DE—ENERGIZED				
	ALL WIRING SHALL BE 3#12 AWG IN 3/4" CONDUIT. #10 AWG WIRE SHALL BE USED FOR RUNS BETWEEN PANEL AND FIRST LIGHTING FIXTURE OR RECEPTACLE EXCEEDING 50 FEET, UNLESS OTHERWISE	PT	R-RED B-BLUE C-CLEAR	0_0				3 TYPICAL D	EVICE MOUNTING HEIGHTS
104 0	NOTED ON DRAWING.	00	SWITCH - TOGGLE OPEN	NCTC	NORMALLY CLOSED CONTACT— TIMED CLOSED TIME DELAY AFTER COIL DE—ENERGIZED			RECEPTACLES (INTERIOR PRO	
J //// -	LETTERS AND NUMBERS INDICATE PANEL AND CIRCUIT NUMBER (LP1-2). CROSS LINES INDICATE NUMBER OF CONDUCTORS. HALF HASH MARKS INDICATES NEUTRAL. NUMBER (10) DENOTES WIRE		MOMENTARY CONTACT	0/0	SOLENOID VALVE			RECEPTACLES (EXTERIOR PRO	48" AFF
	HASH MARKS INDICATES NEUTRAL. NUMBER (10) DENOTES WIRE SIZE WHEN NOT #12 AWG. CONTINUE CONDUIT AND WIRE RUN FROM BOX TO DEVICE IN ROOM OR AREA AS NOTED BY BRANCH CIRCUIT NUMBER. #10 AWG WIRING SHALL BE USED FOR RUNS BETWEEN	0 0	PUSH BUTTON NORMALLY OPEN		MOTOR STARTER			PHONE OUTLETS (WALL MOUN	
	PANEL AND FIRST LIGHTING FIXTURE OR RECEPTACLE EXCEEDING 50 FEET, UNLESS OTHERWISE NOTED ON DRAWING.	010	MOMENTARY CONTACT PUSH BUTTON	M	CONTACTOR COIL COIL DESIGNATION: M-COIL			DATA OUTLETS ————————————————————————————————————	16" AFF 16" ABOVE DOOR
<u> </u>	INDICATES GROUND CONDUCTOR	LO STOP	NORMALLY CLOSED		M-COIL			EMERGENCY LIGHTS (WALL M	그리고 있는 사람들이 있는 것이 그렇게 그렇게 그렇게 되었다. 그리고 있는 것이 없는 것이다.
Z <sub>C12</sub>	INDICATES HOMERUN AND CONDUIT TAG		MOMENTARY LOCKOUT STOP PUSHBUTTON					NOTES: DIMENSIONS ARE TO DEVICE E	OTTOM UNLESS NOTED OTHERWISE. IN
								CONCRETE BLOCK OR BRICK	WALL CONSTRUCTION, CONTRACTOR DX INSTALLATION WITH MORTAR AND
REV.NO.	DESCRIPTION DATE	RIMAND HAMILEEAL							
		C E N S C E N	SMCKIM&(	CREED	July .		LIFT STATION 12A EL		HORIZONTAL:
			1365 Hamlet Avenue Clearwater, Florida 33756		Manate	e	VFD REHABI	LITATION	DESIGNED SS N/A CHECKED MAC VERTICAL:
		STATE OF CORIDERS CONTROL	Clearwater, Florida 33756 Phone: (727) 442-7196, Fax: (727)	7) 461-3827	County County		ELECTRI		PROJ. MGR. AAH TBD
0 ISSUED FOR BID		ONA L MAINT	CA Lic. No. 29588		FLORIDA		SYMBO	JL3	STATUS:

CA Lic. No. 29588 www.mckimcreed.com

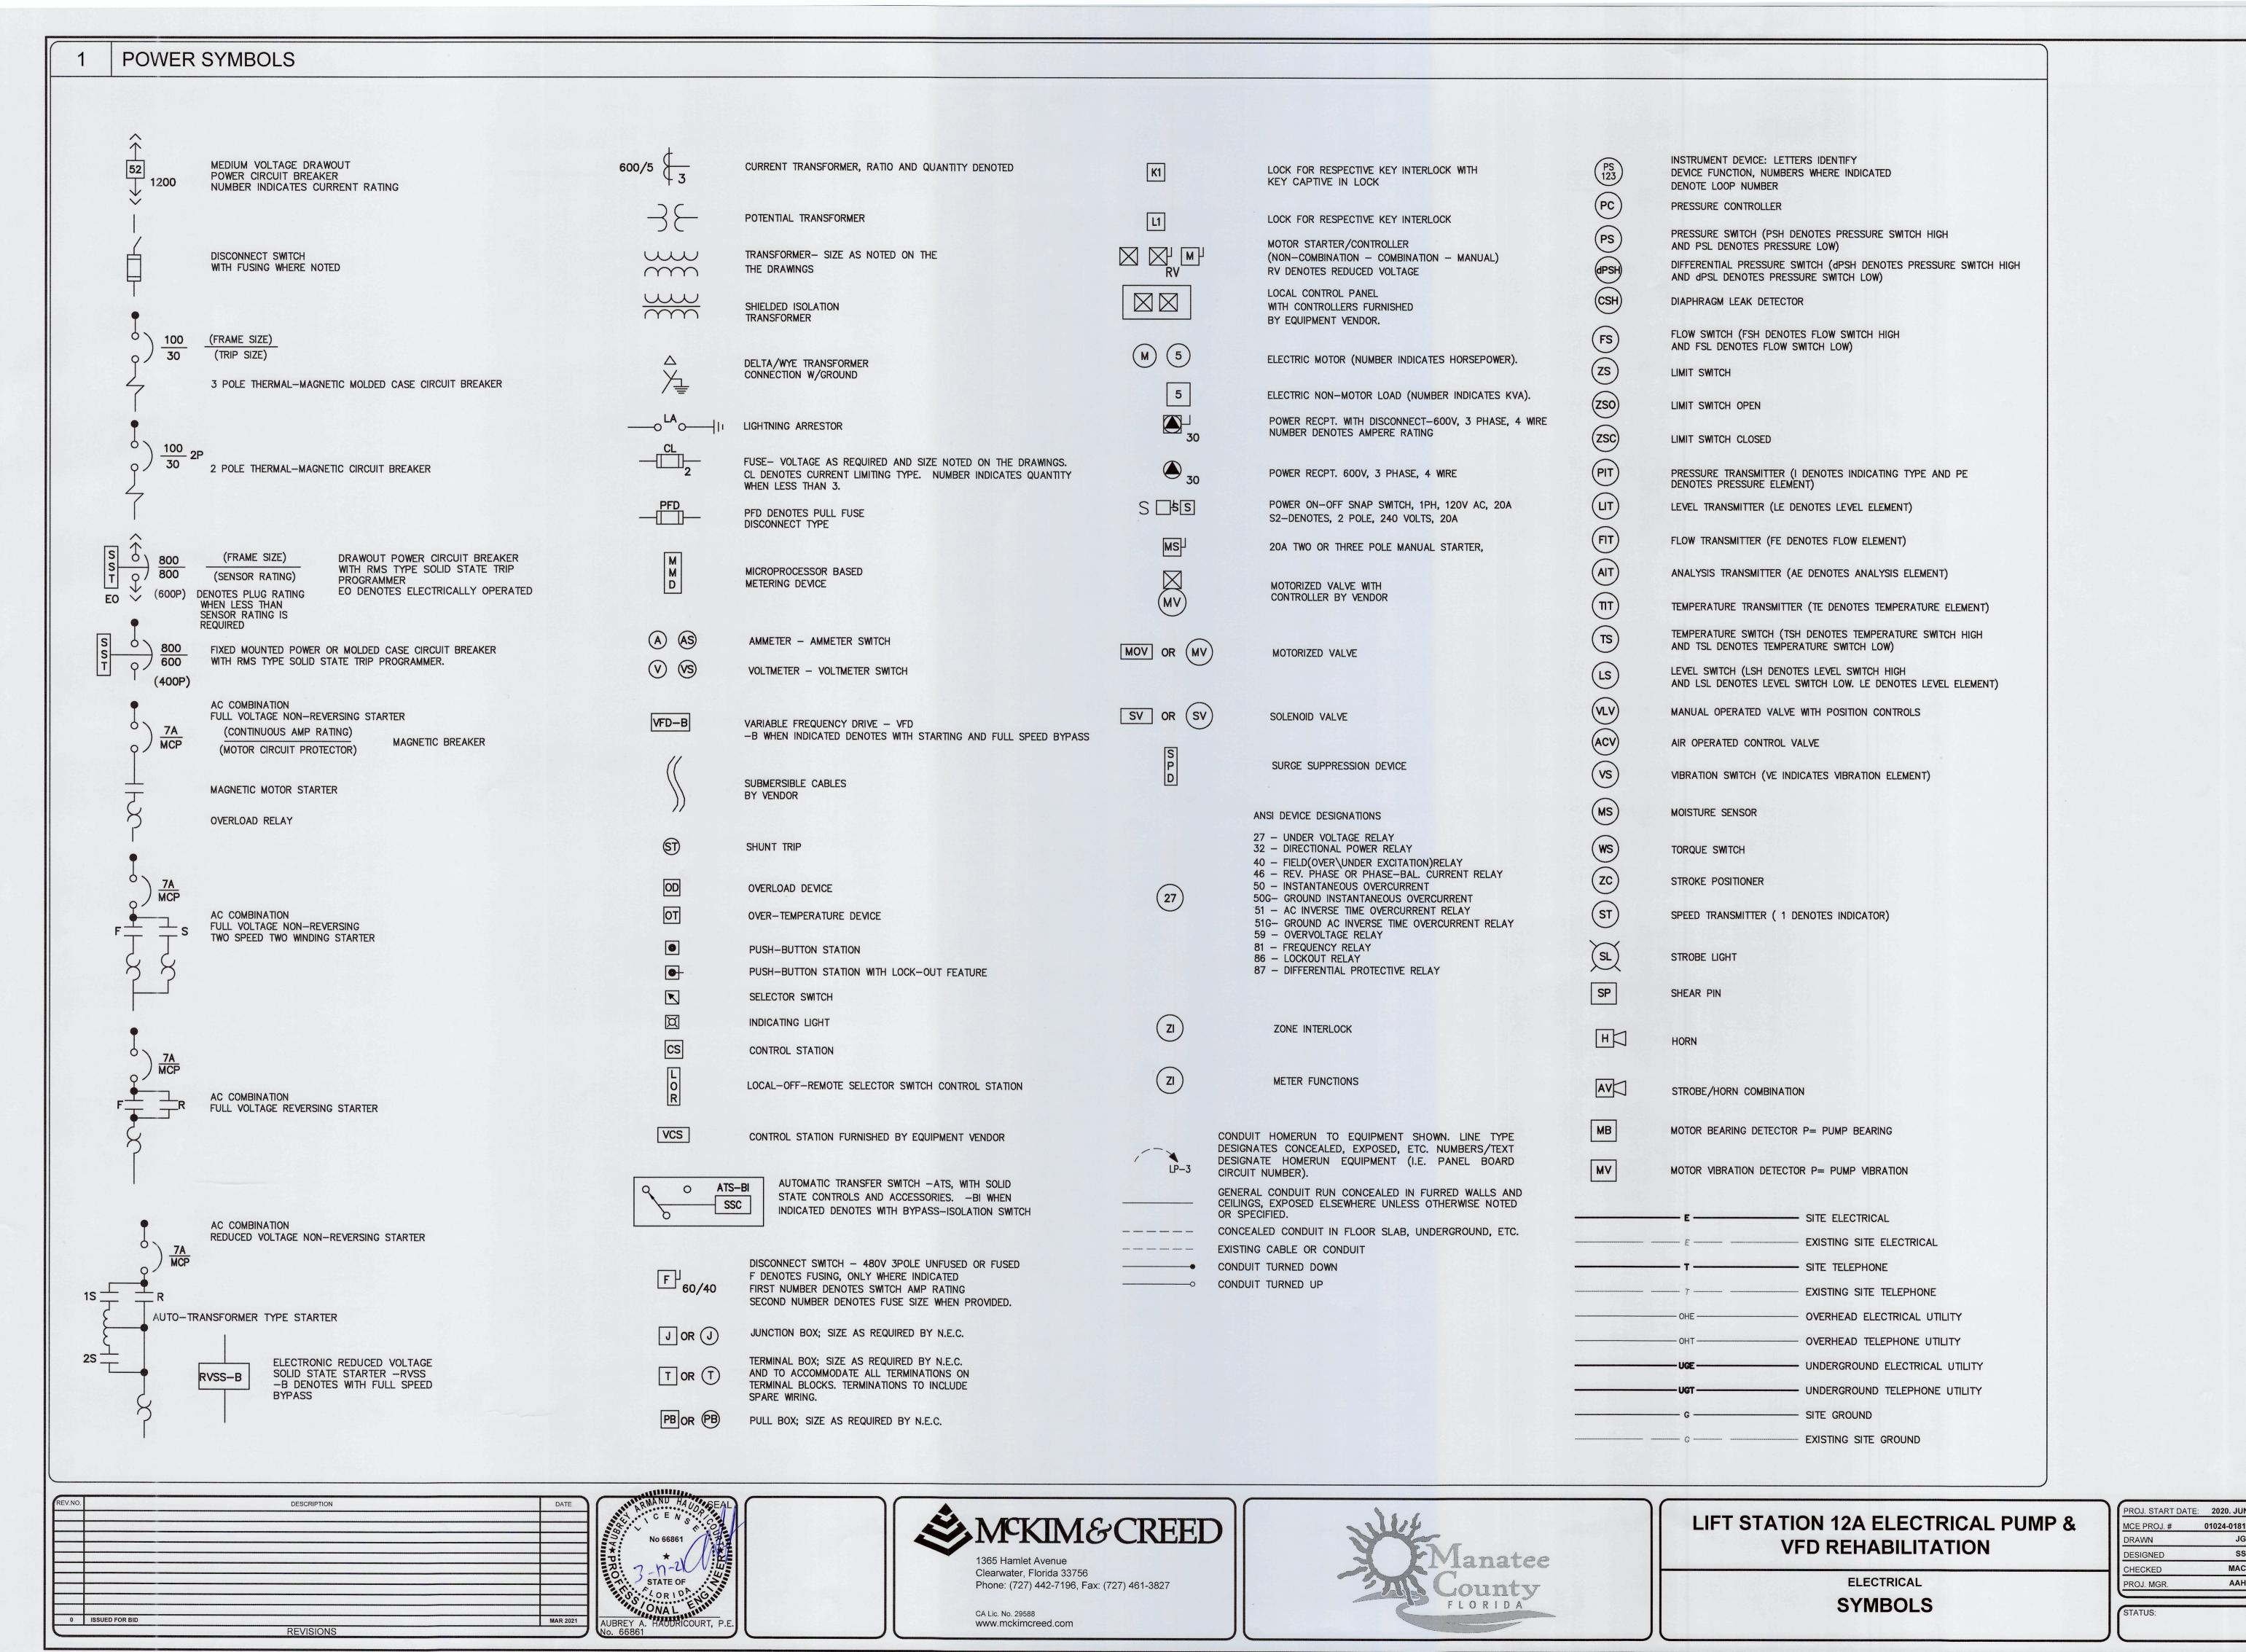

01024-0181

HORIZONTAL

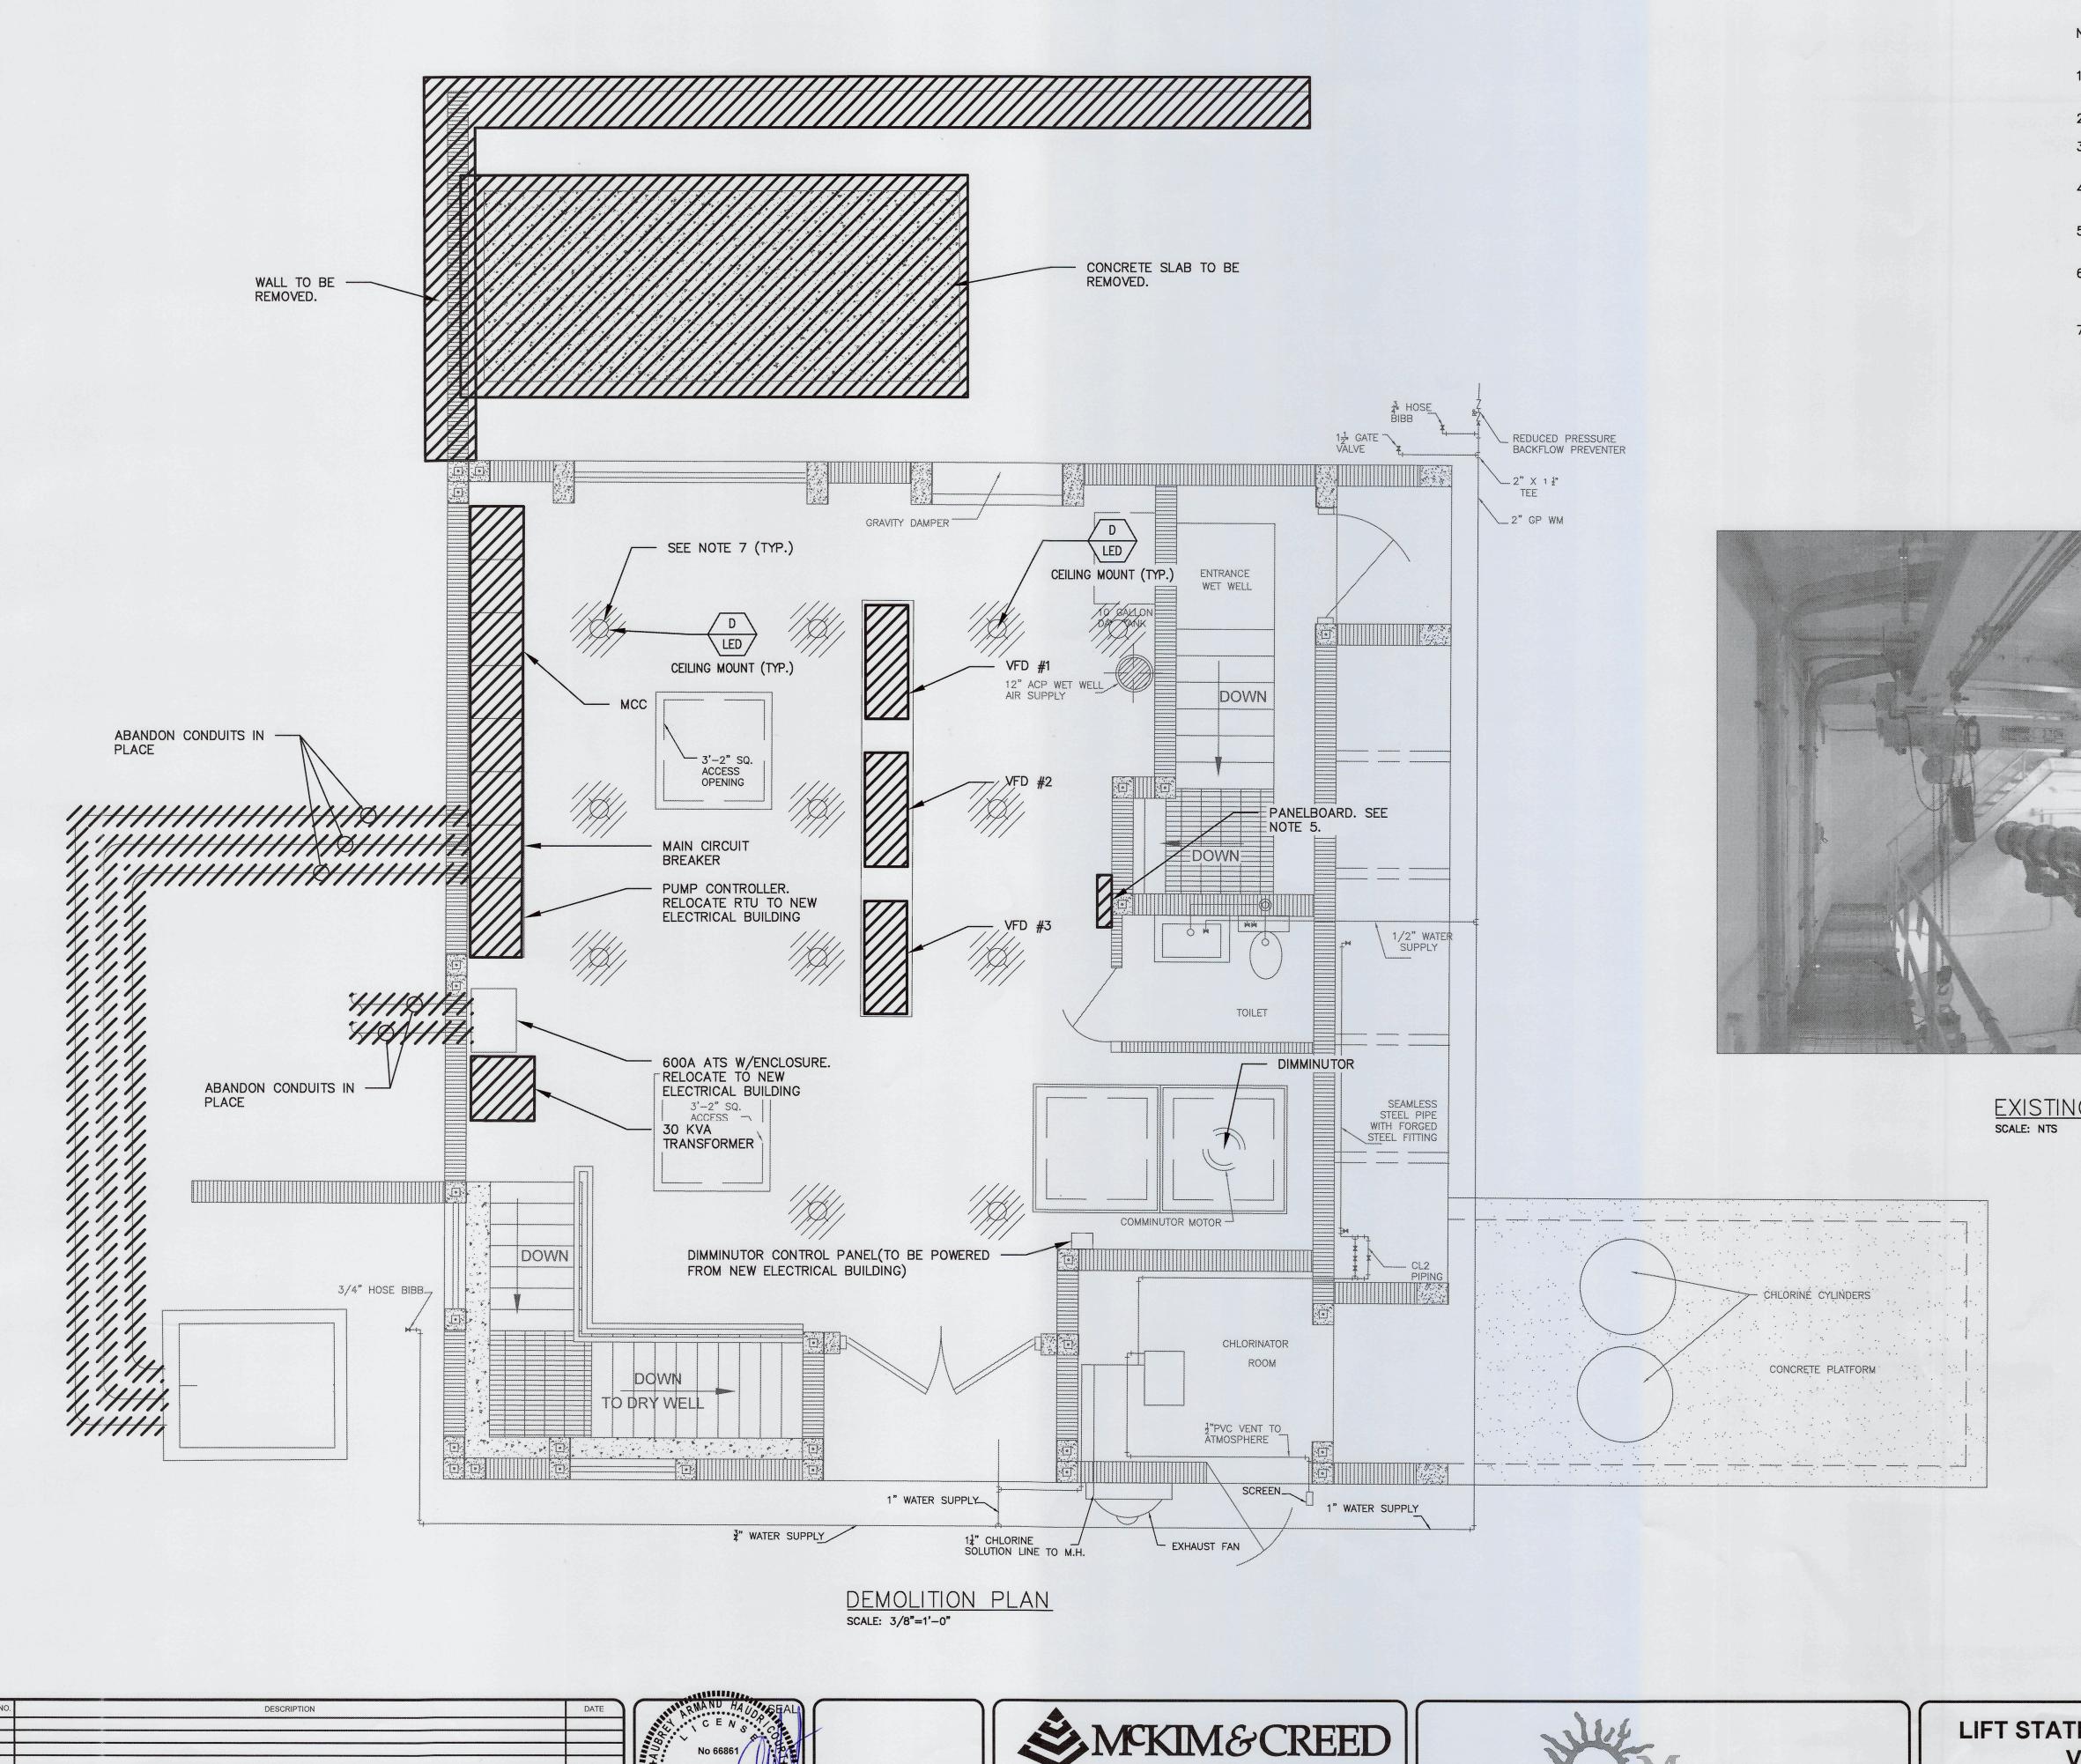

Clearwater, Florida 33756

www.mckimcreed.com

CA Lic. No. 29588

0 ISSUED FOR BID

Phone: (727) 442-7196, Fax: (727) 461-3827

#### NOTES:


- 1. PROVIDE TEMPORARY POWER FOR CONSTRUCTION. REFER TO BYPASS PUMP SPECIFICATIONS.
- 2. EXISTING ATS SHALL BE RELOCATED TO NEW ELECTRICAL BUILDING.
- 3. REMOVE ALL EXPOSED CONDUIT AND WIRE NOT USED PER EQUIPMENT DEMOLITION.
- 4. REMOVE ALL WIRING IN UNDERGROUND CONDUIT THAT IS TO BE ABANDONED. CAP ALL ABANDONED CONDUIT.
- 5. INTERCEPT EXISTING CONDUIT BY INSTALLING NEMA 4X SS 42 CKT PANELBOARD. REPULL ALL NEW WIRE.
- 6. REMOVE EQUIPMENT PADS UNDERNEATH EQUIPMENT BEING DEMOLISHED. INSTALL NEW PADS UNDER NEW EQUIPMENT, SUCH AS NEW VFD JUNCTION BOXES. REFER TO STRUCTURAL DRAWINGS.
- 7. REPLACE EXISTING FLUORESCENT BULBS WITH LED. IN THE EVENT THE GUARD AND GLOBE CAN NOT BE REMOVED, WITHOUT DAMAGE, A NEW REPLACEMENT LED FIXTURE SHALL BE INSTALLED.



- EQUIPMENT TO BE DEMOLISHED OR RELOCATED.

NORTH

SCALE: 3/8" = 1'-0"

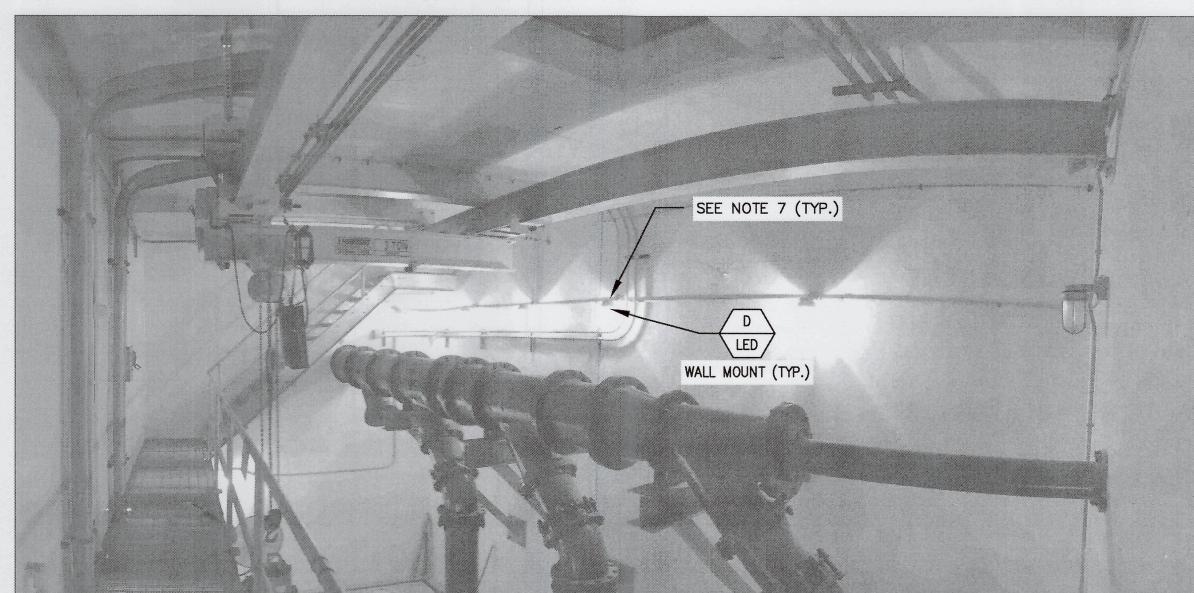

EXISTING BUILDING DRY WELL LIGHTING

LIFT STATION 12A ELECTRICAL PUMP & **VFD REHABILITATION** 

lanatee


FLORIDA


ELECTRICAL


**DEMOLITION PLAN** 


01024-0181 PROJ. MGR.


3/8"=1'-0" VERTICAL:

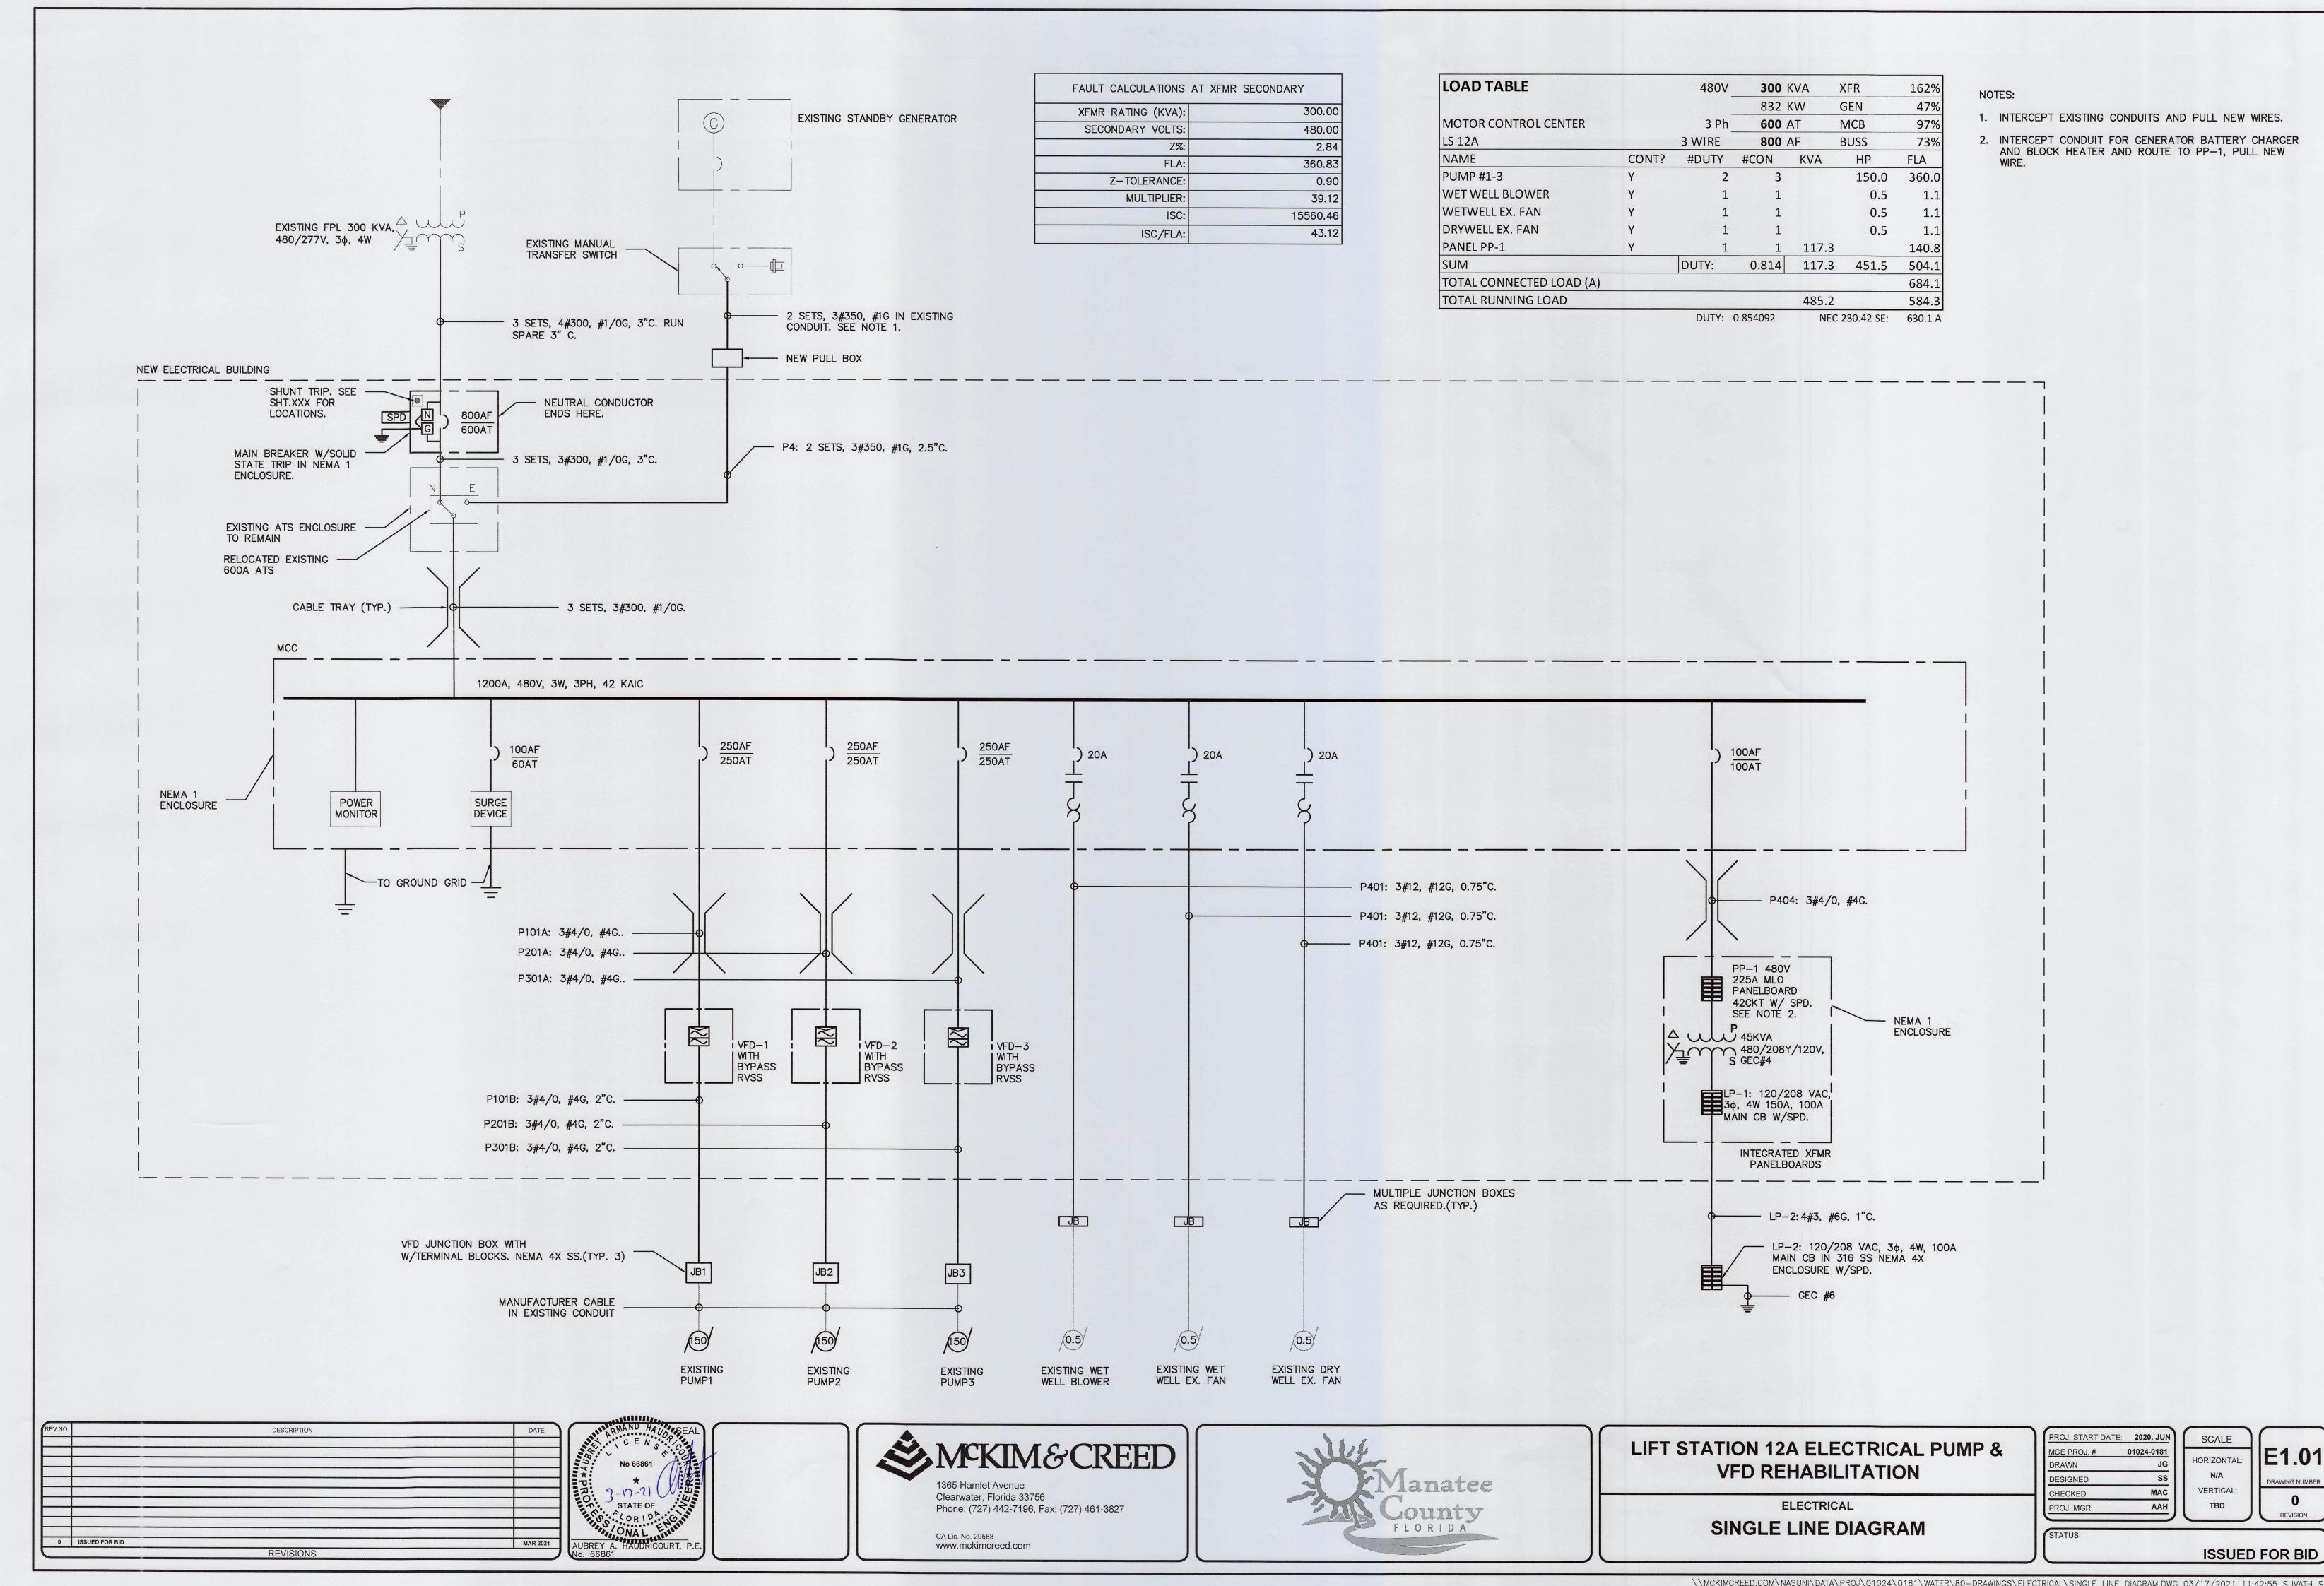


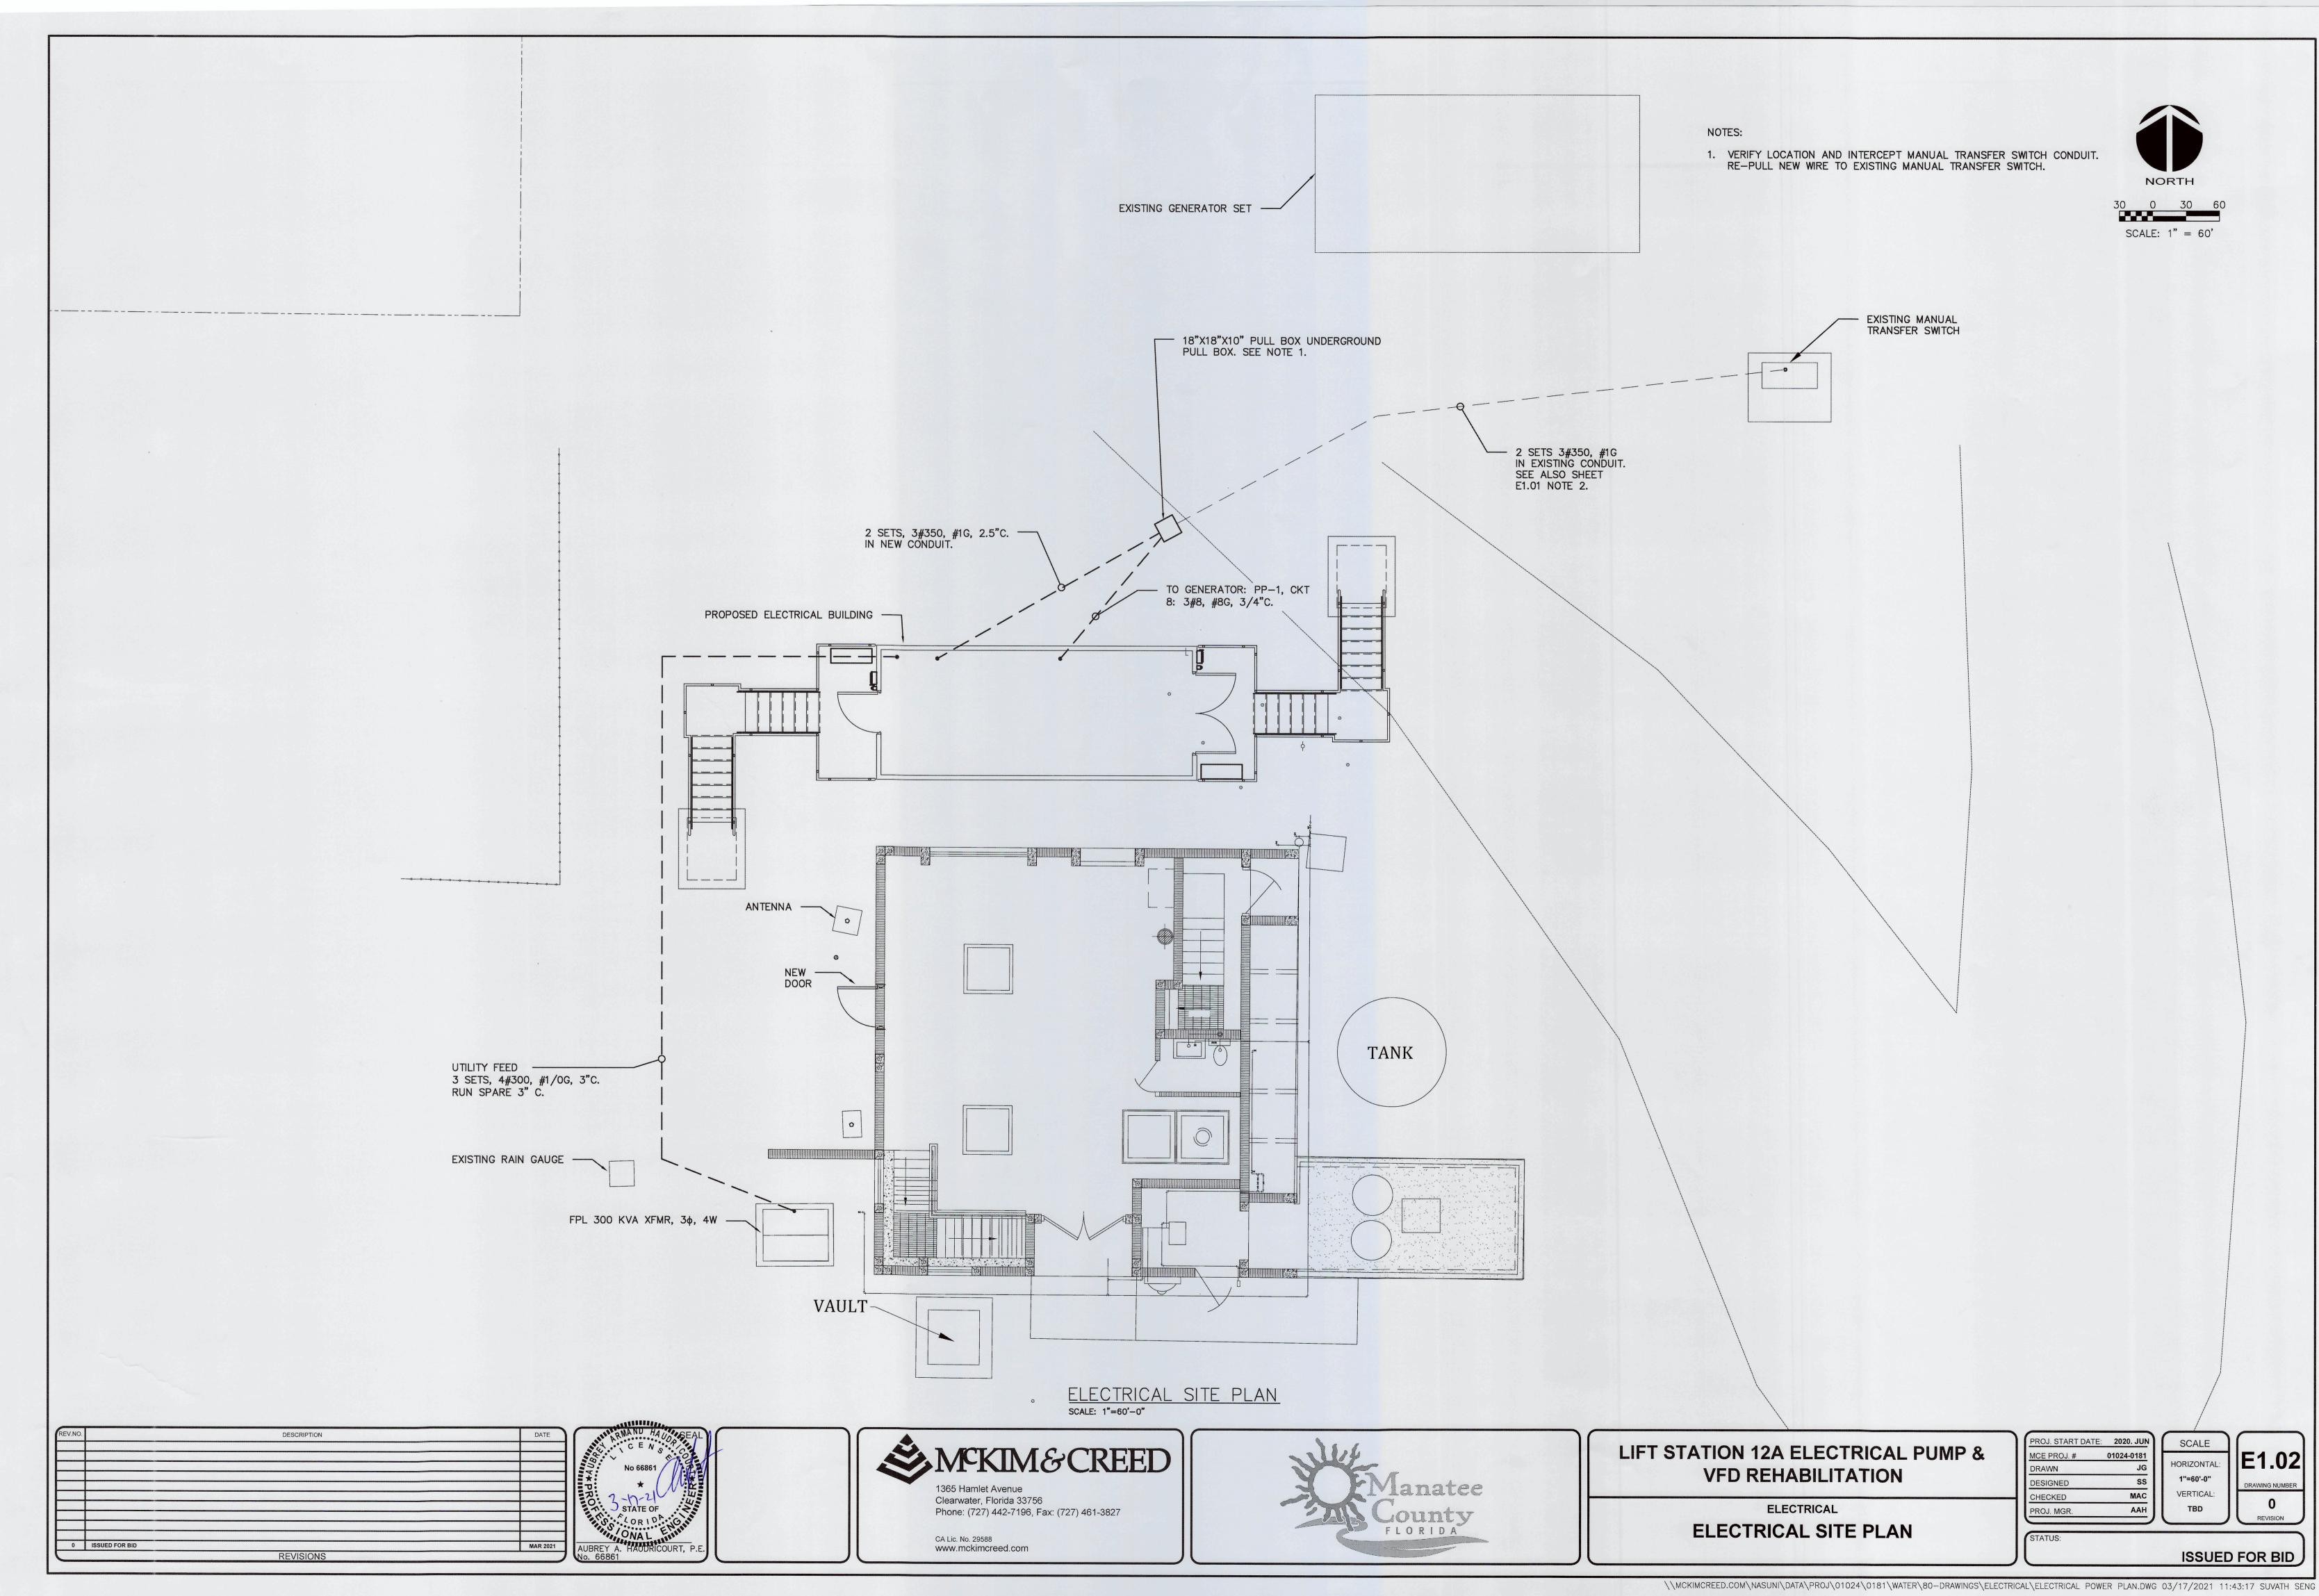


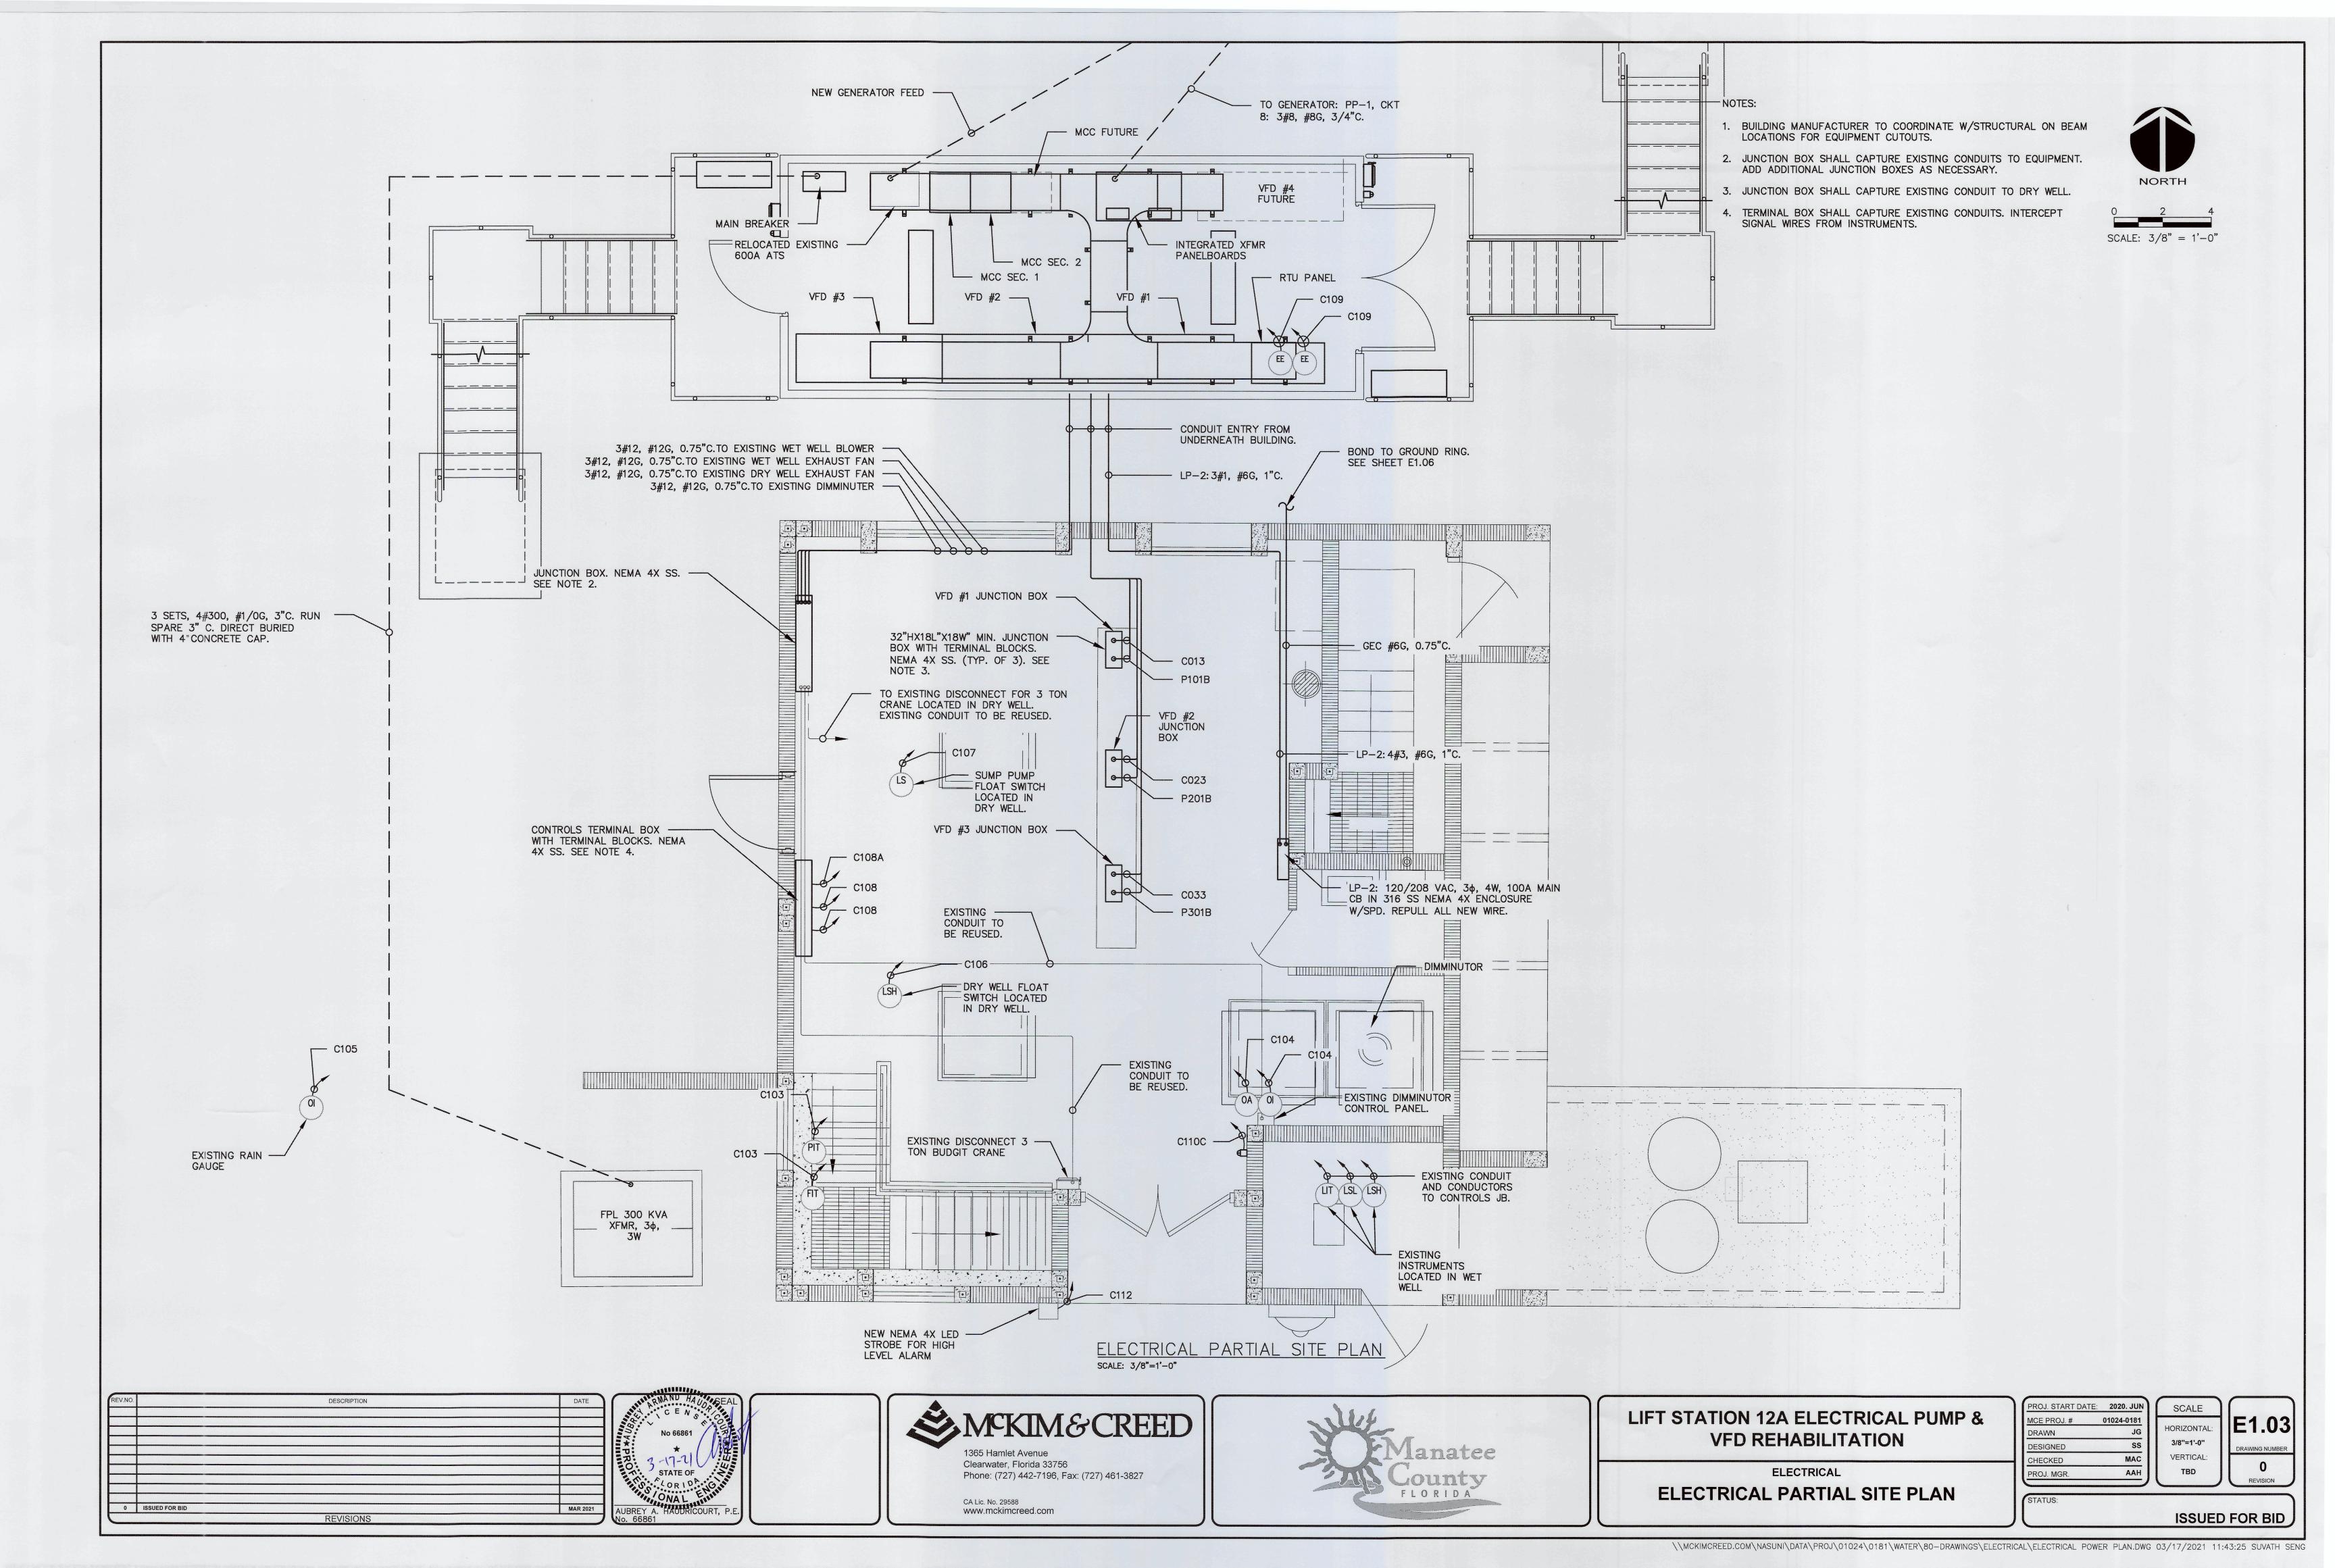


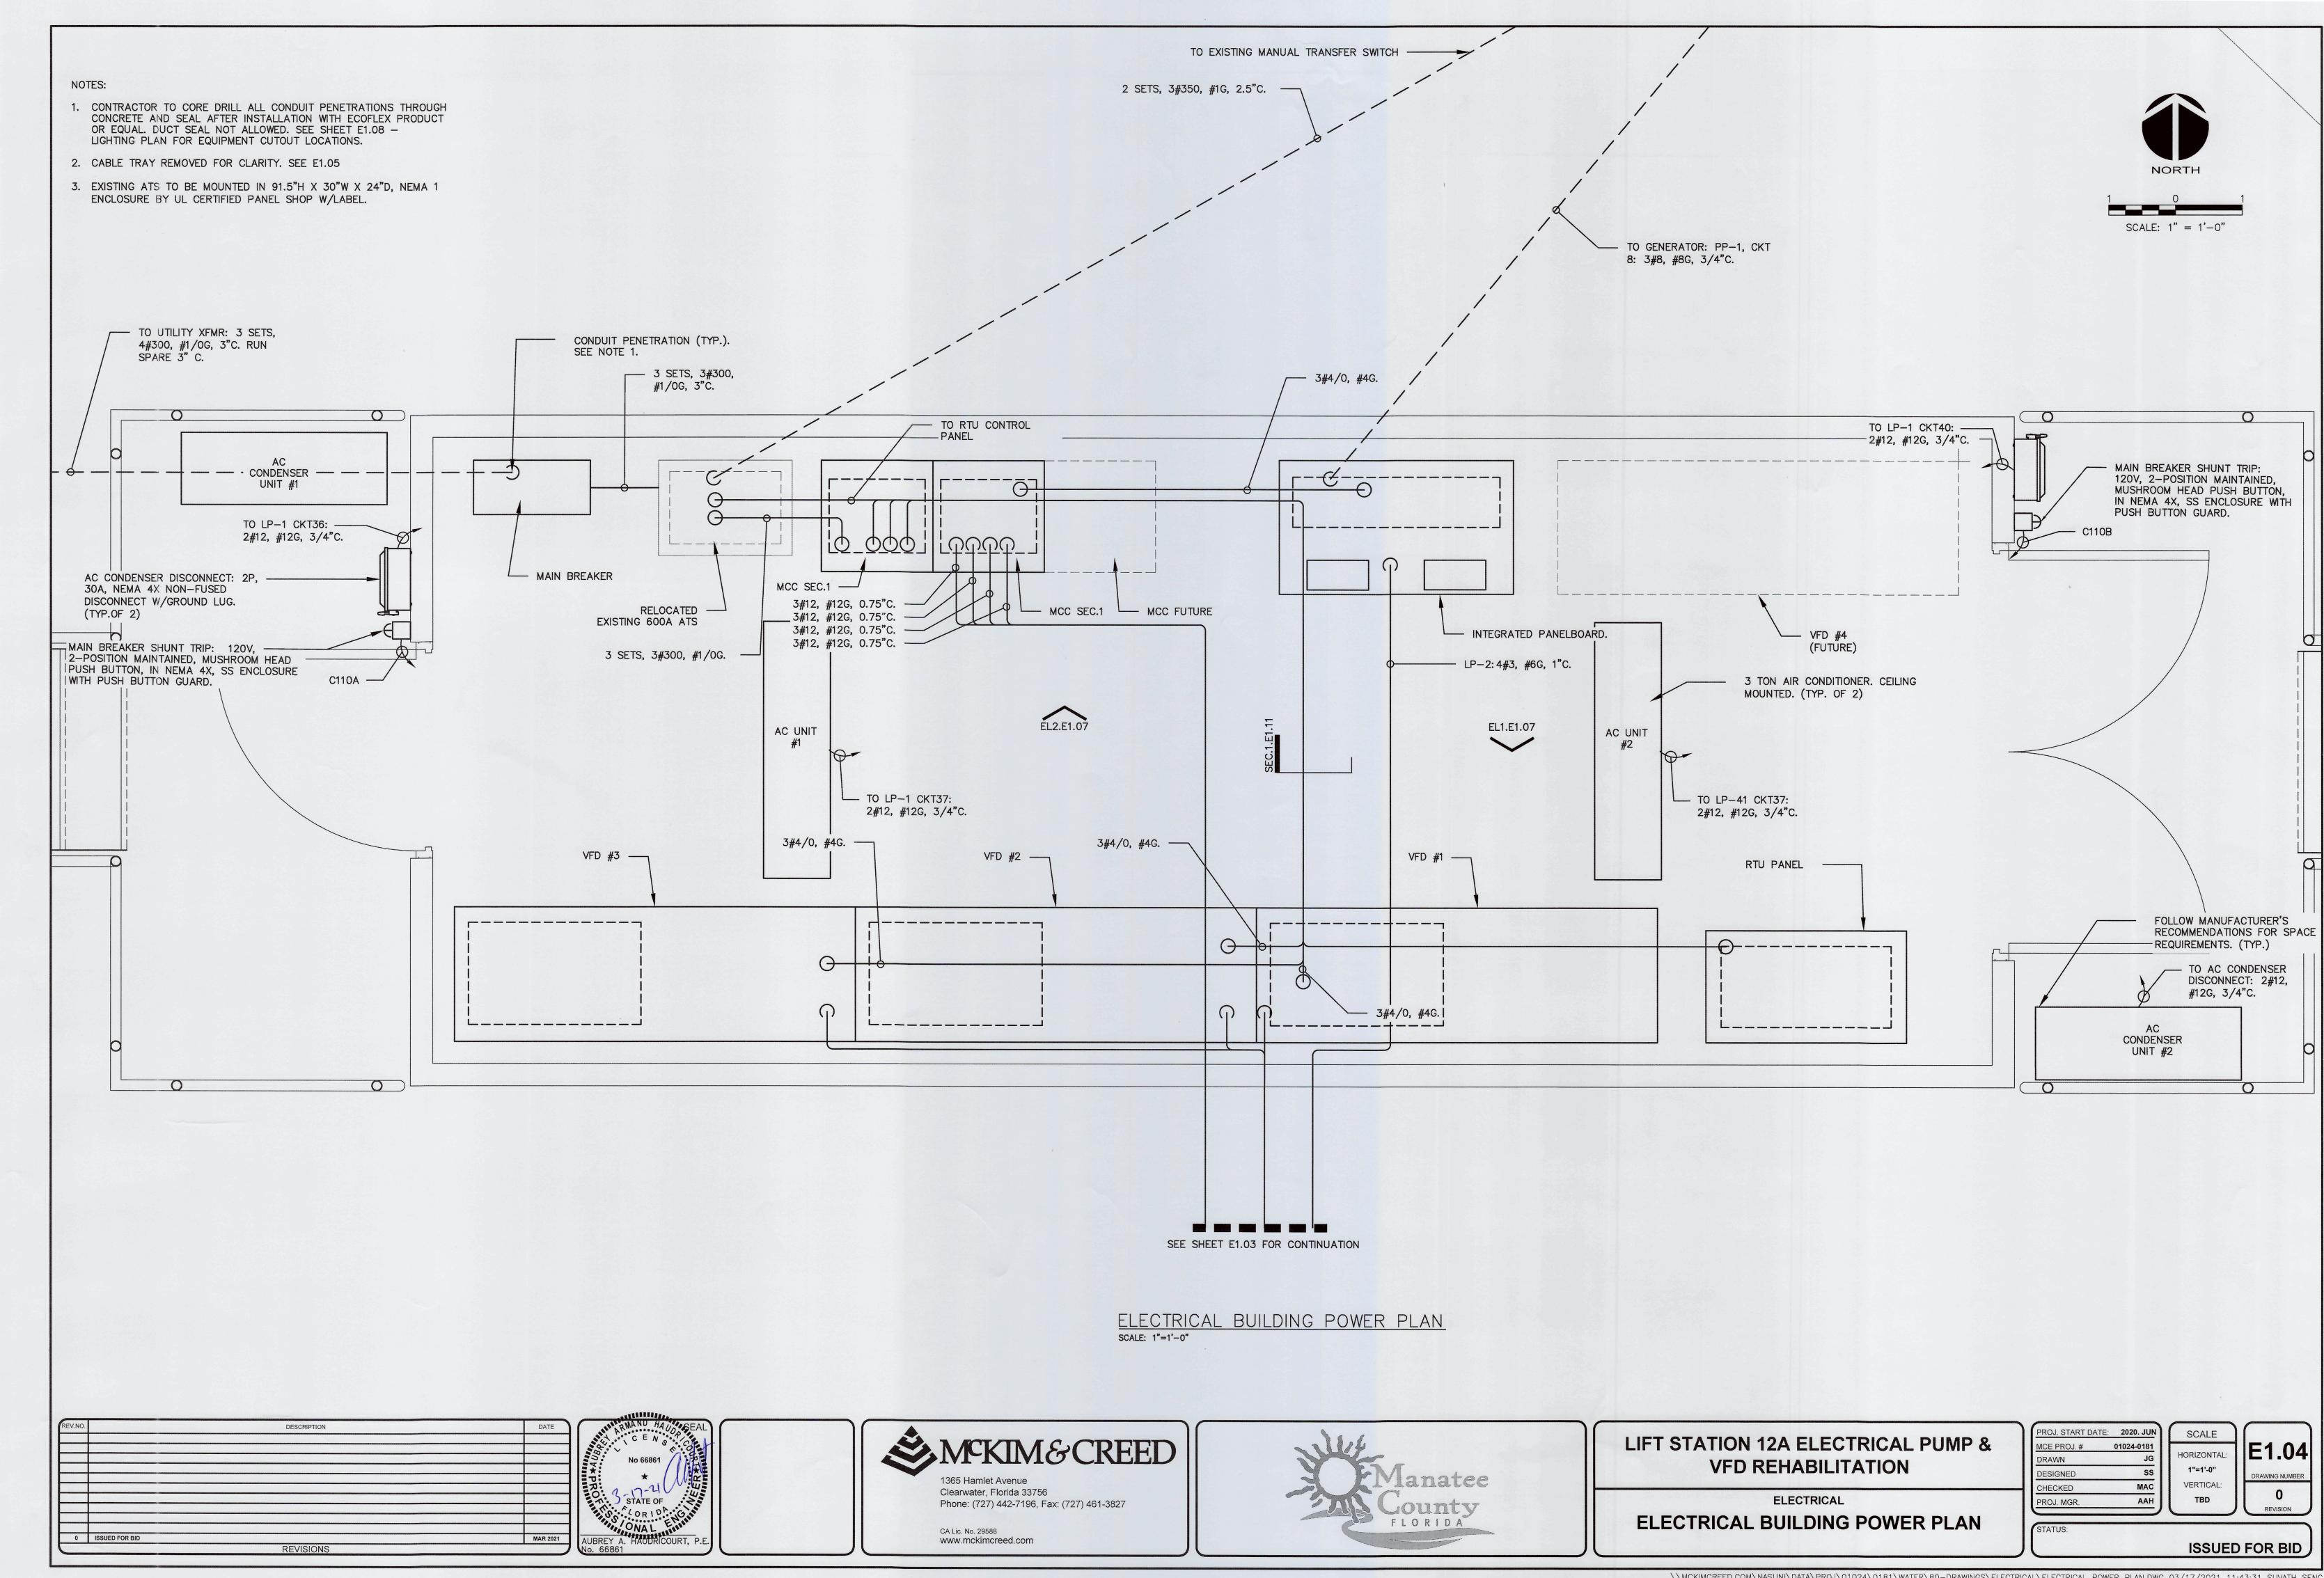

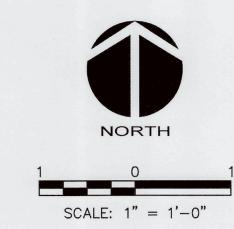

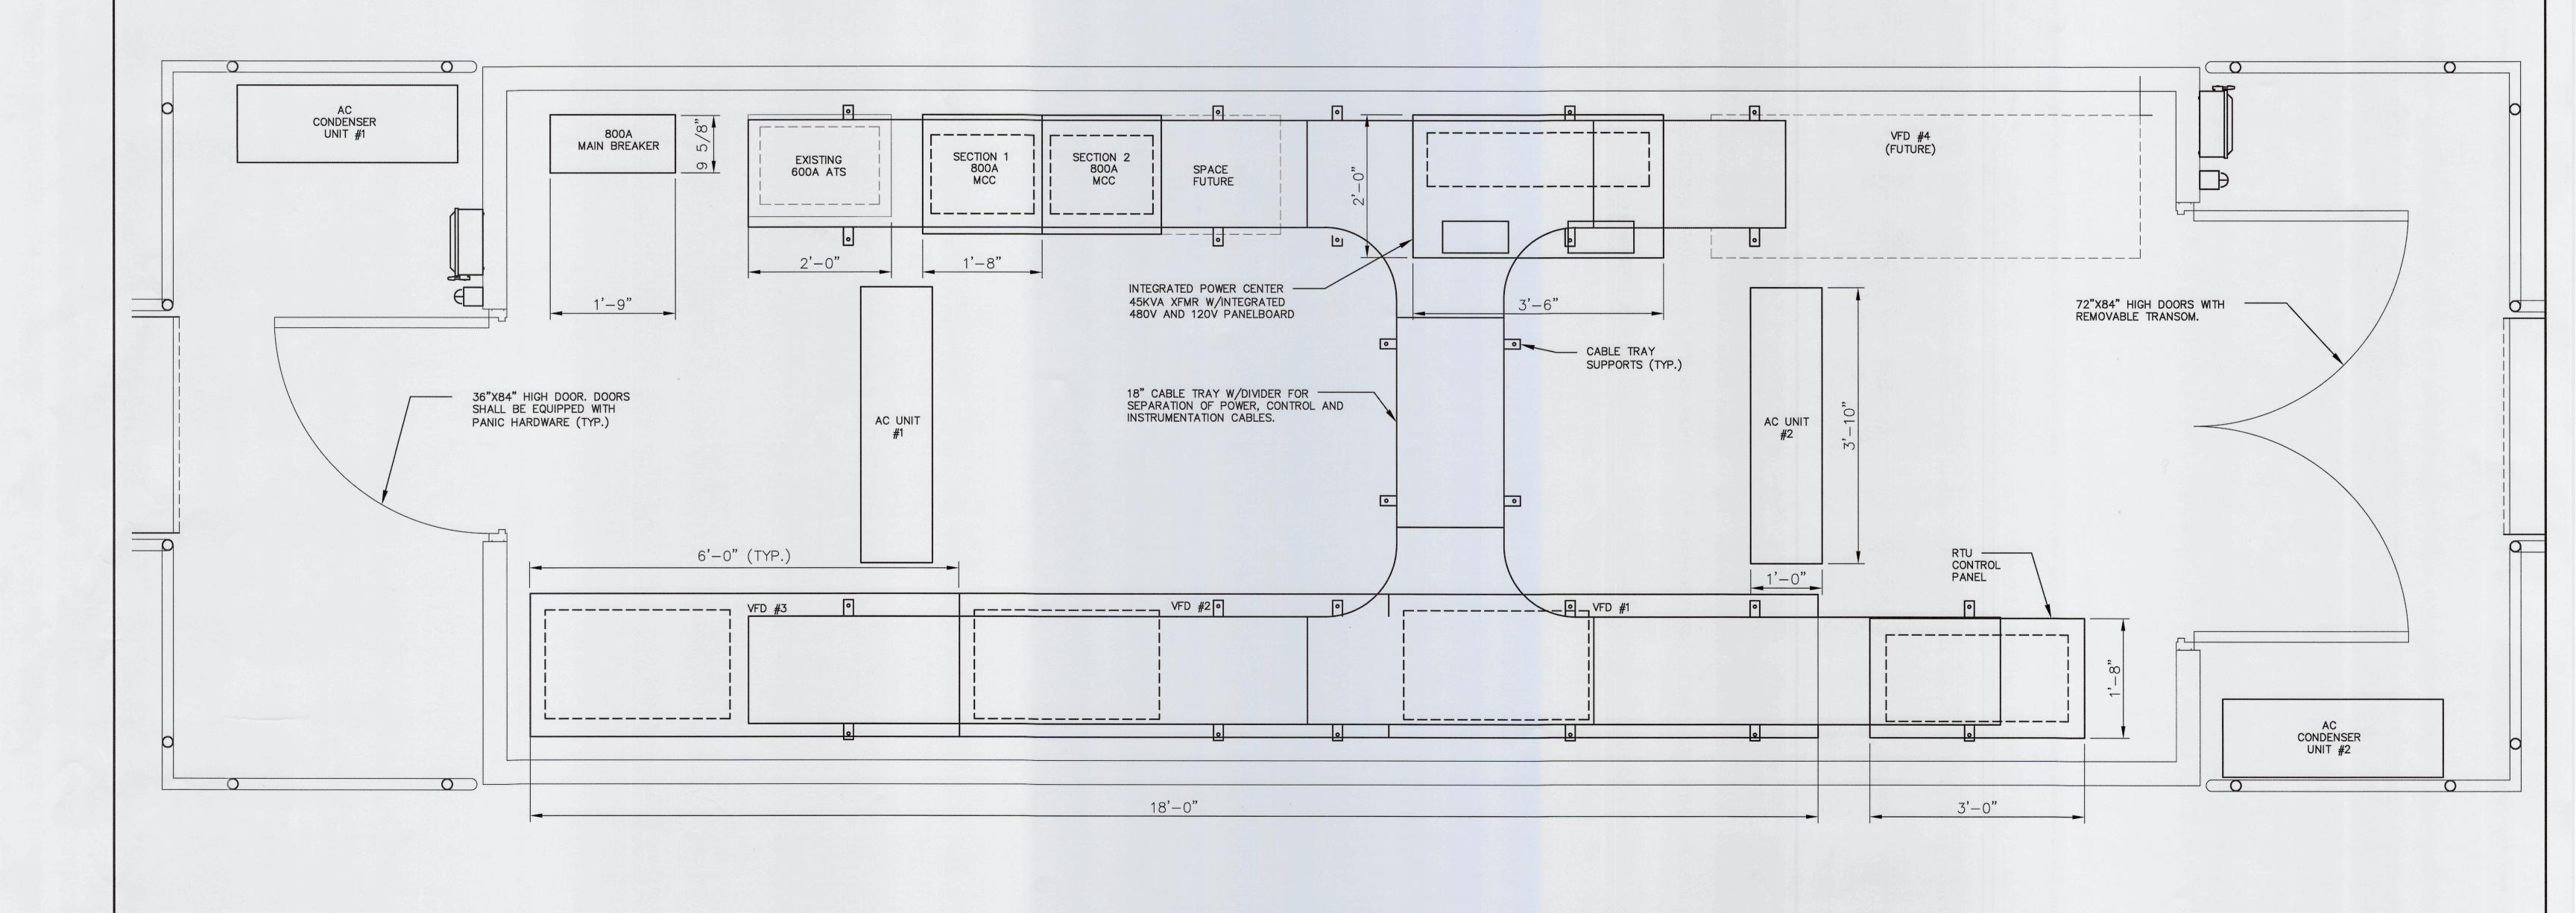

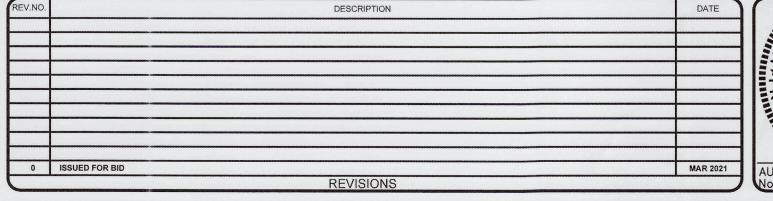

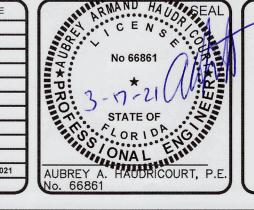








LIFT STATION 12A ELECTRICAL PUMP & VFD REHABILITATION


ELECTRICAL BUILDING LAYOUT


OJ. START DATE	2020. JUN	SCALE	
E PROJ. #	01024-0181		E1.05
AWN	JG	HORIZONTAL:	E1.03
SIGNED	SS	1"=1'-0"	DRAWING NUMBER
ECKED	MAC	VERTICAL:	
OJ. MGR.	AAH	TBD	U
			REVISION
ATUS:			

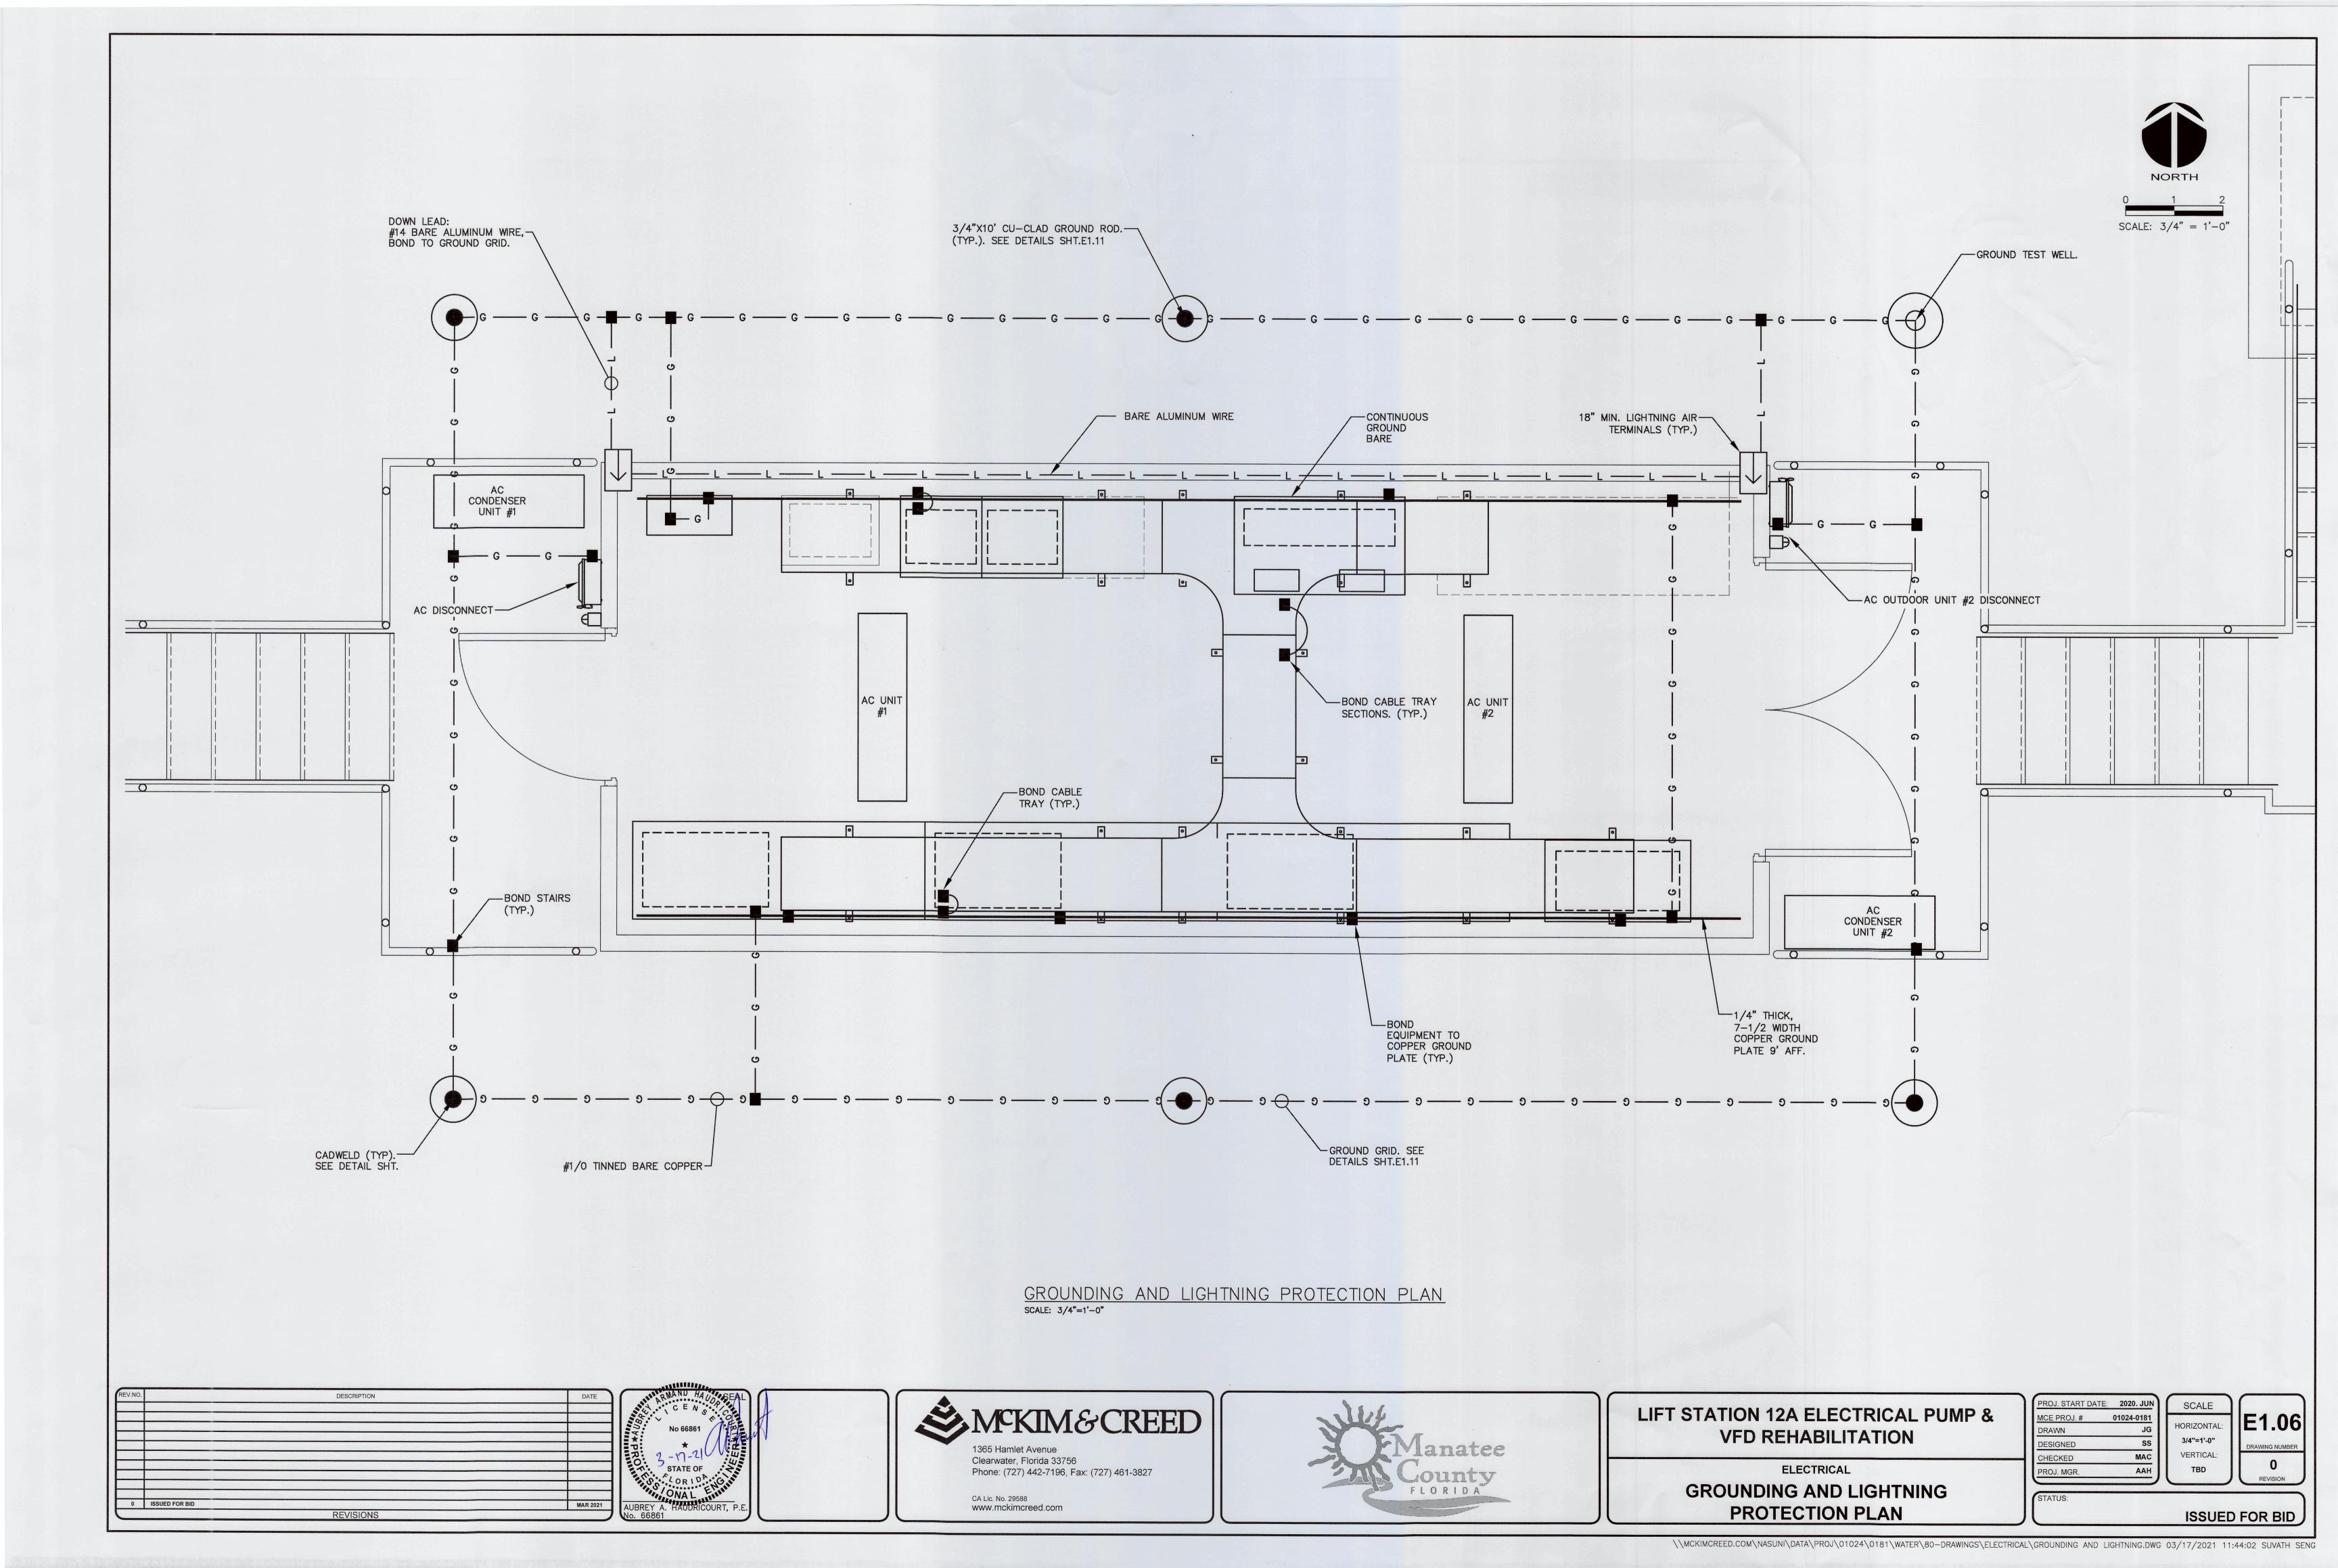


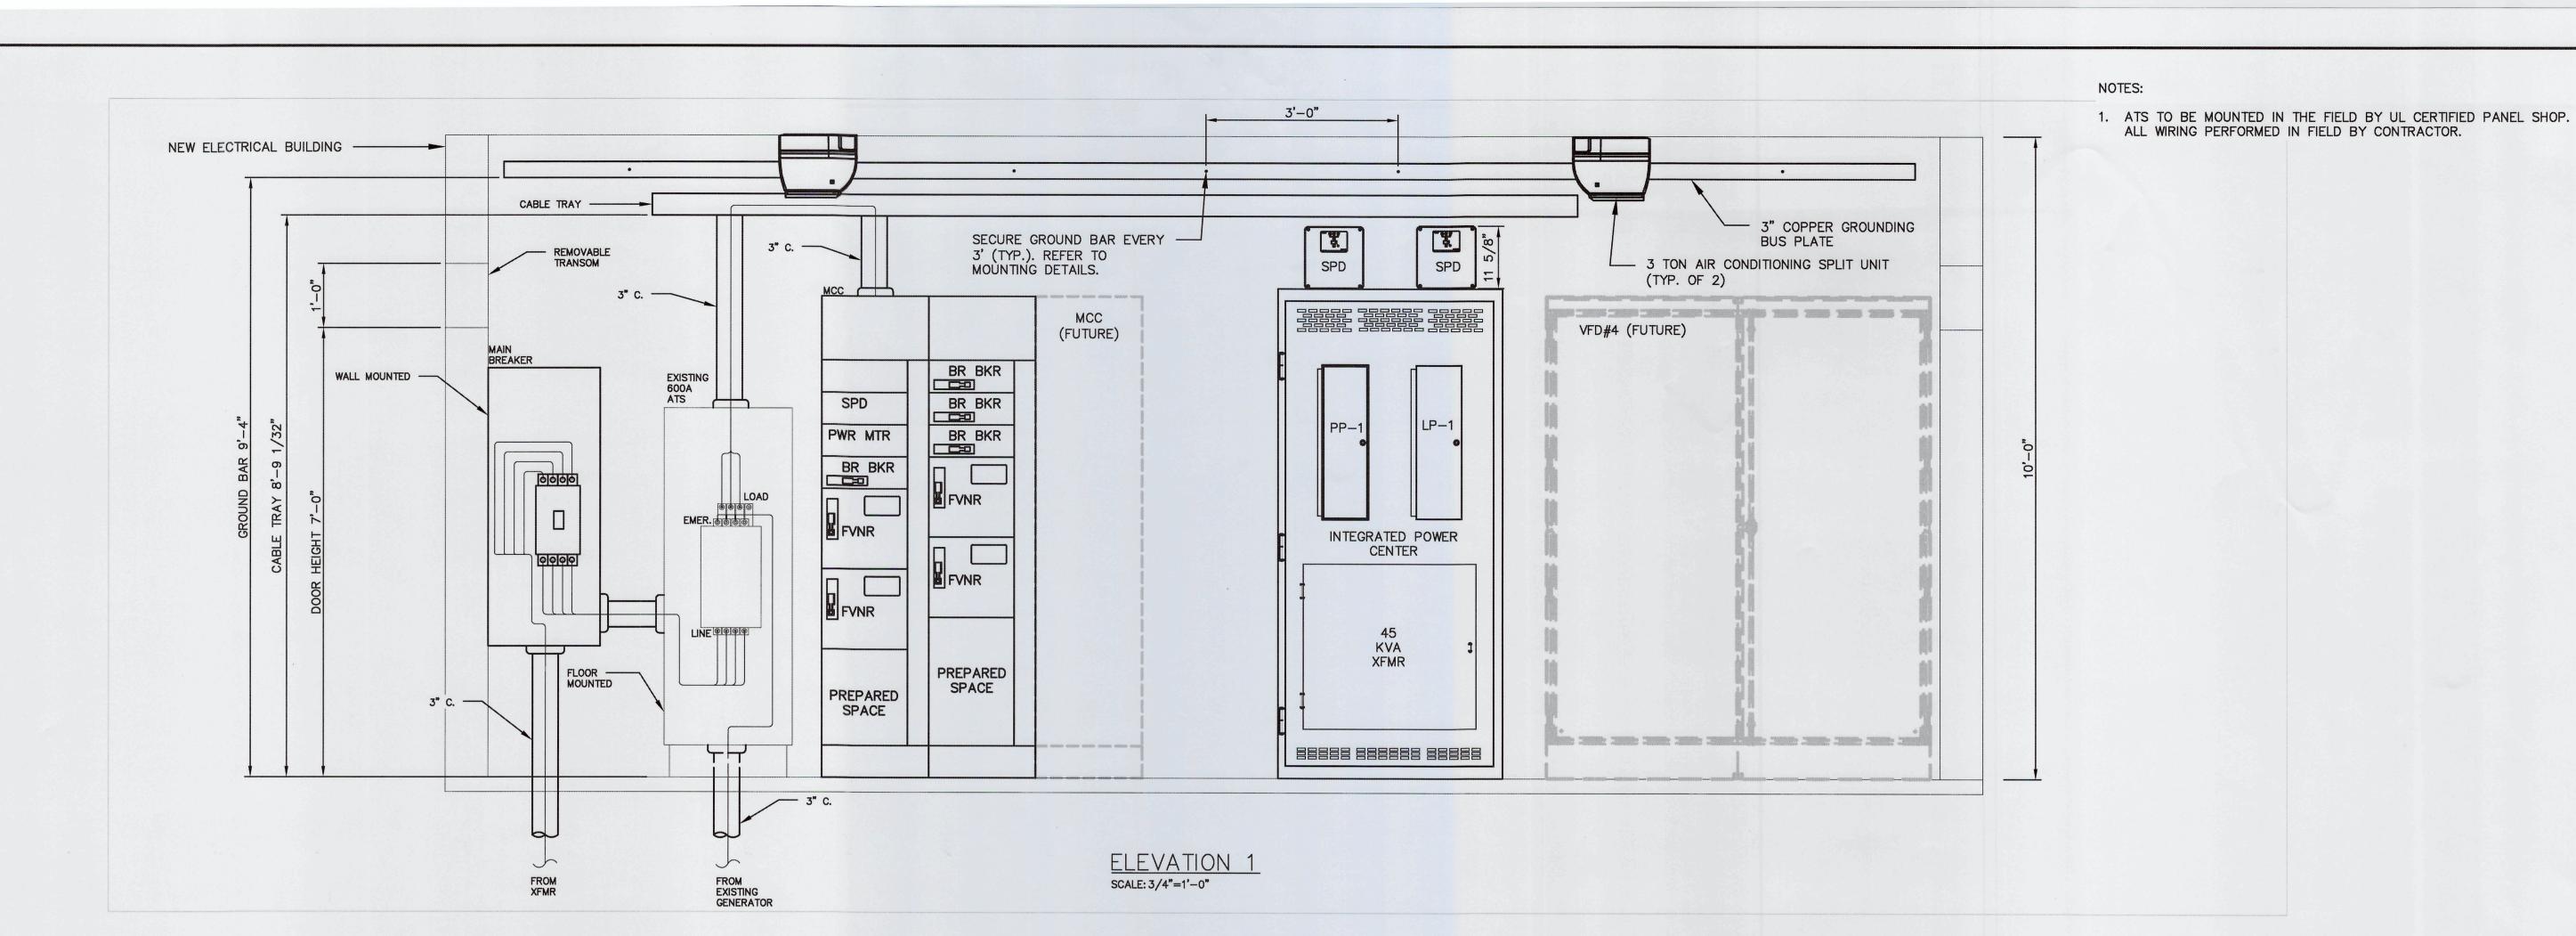


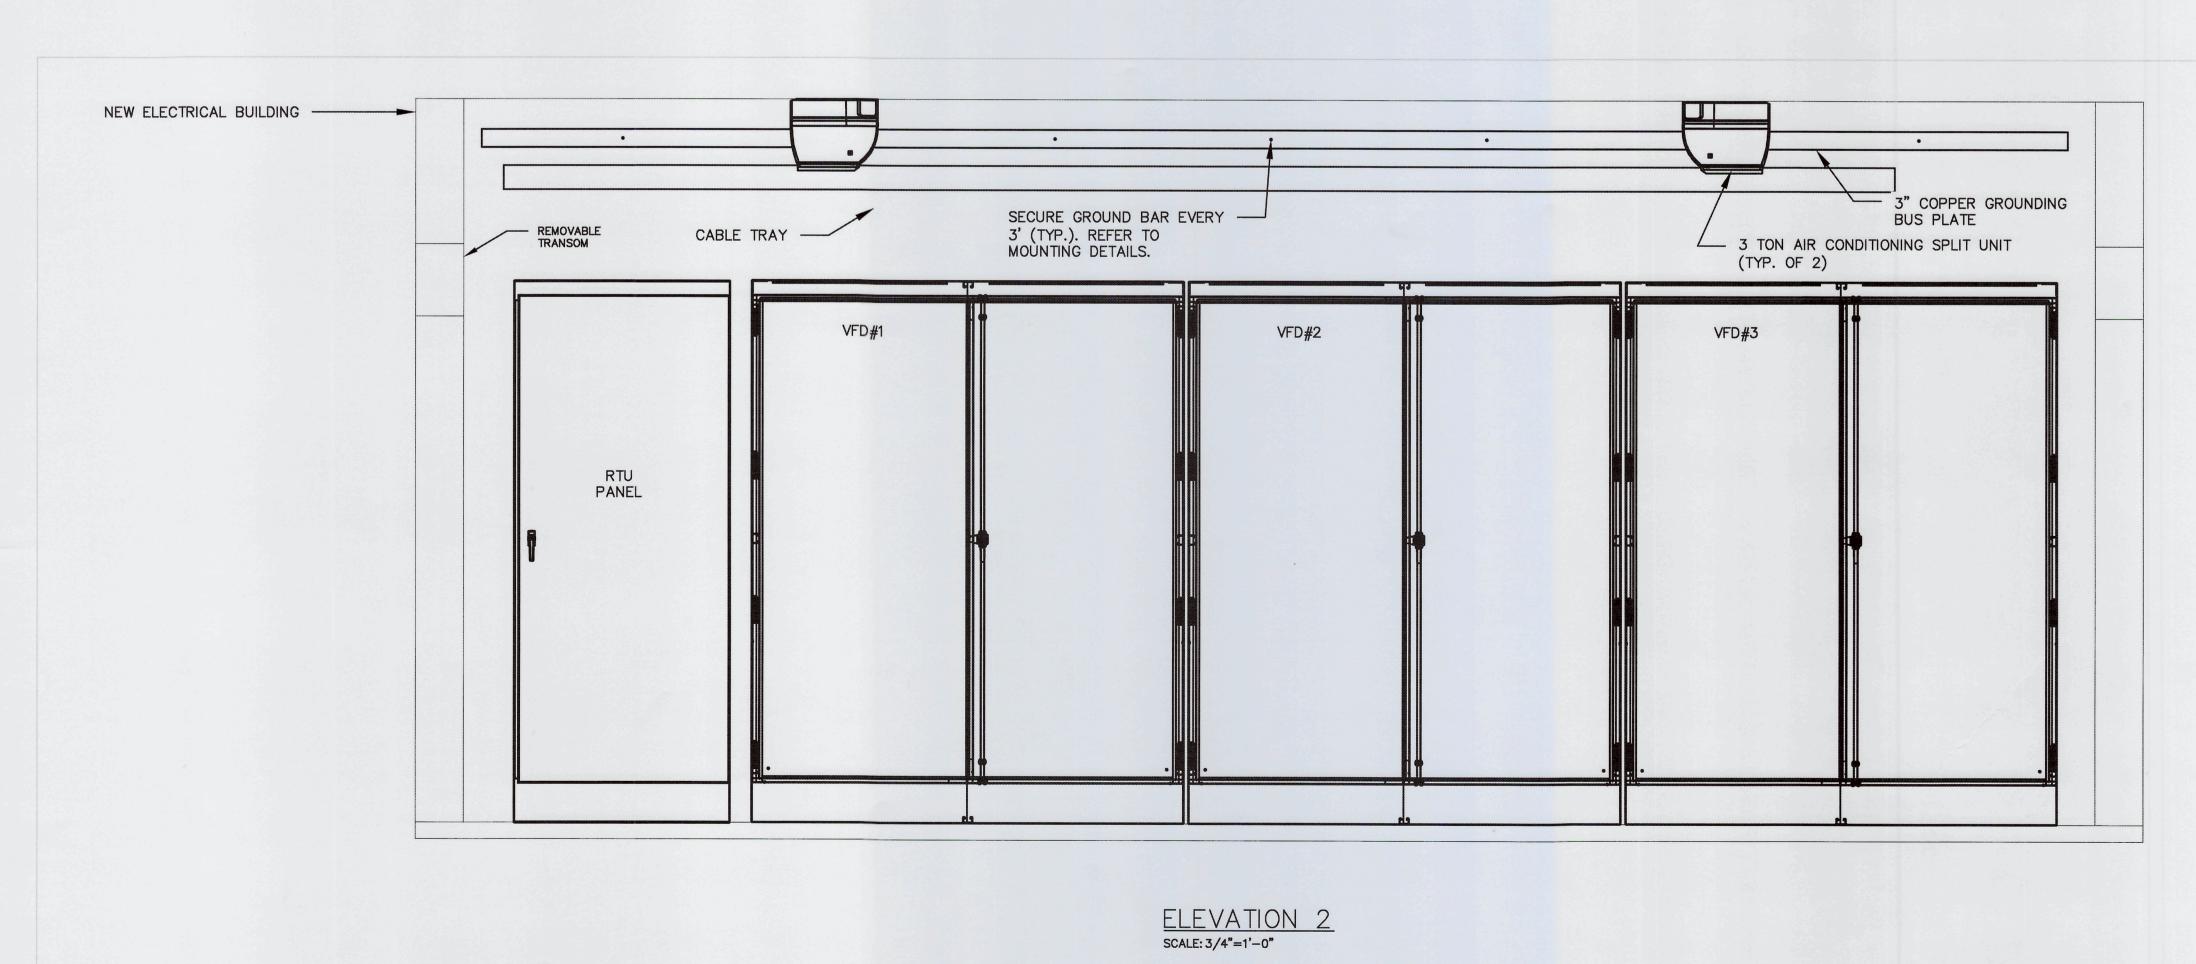

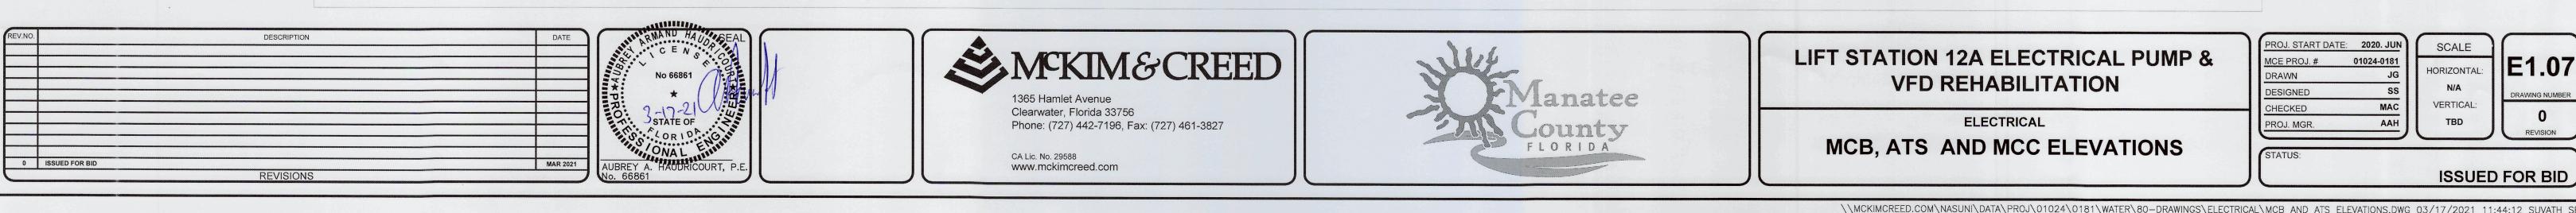

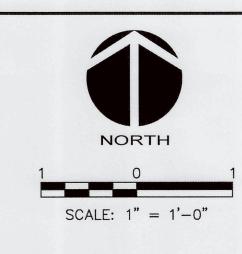

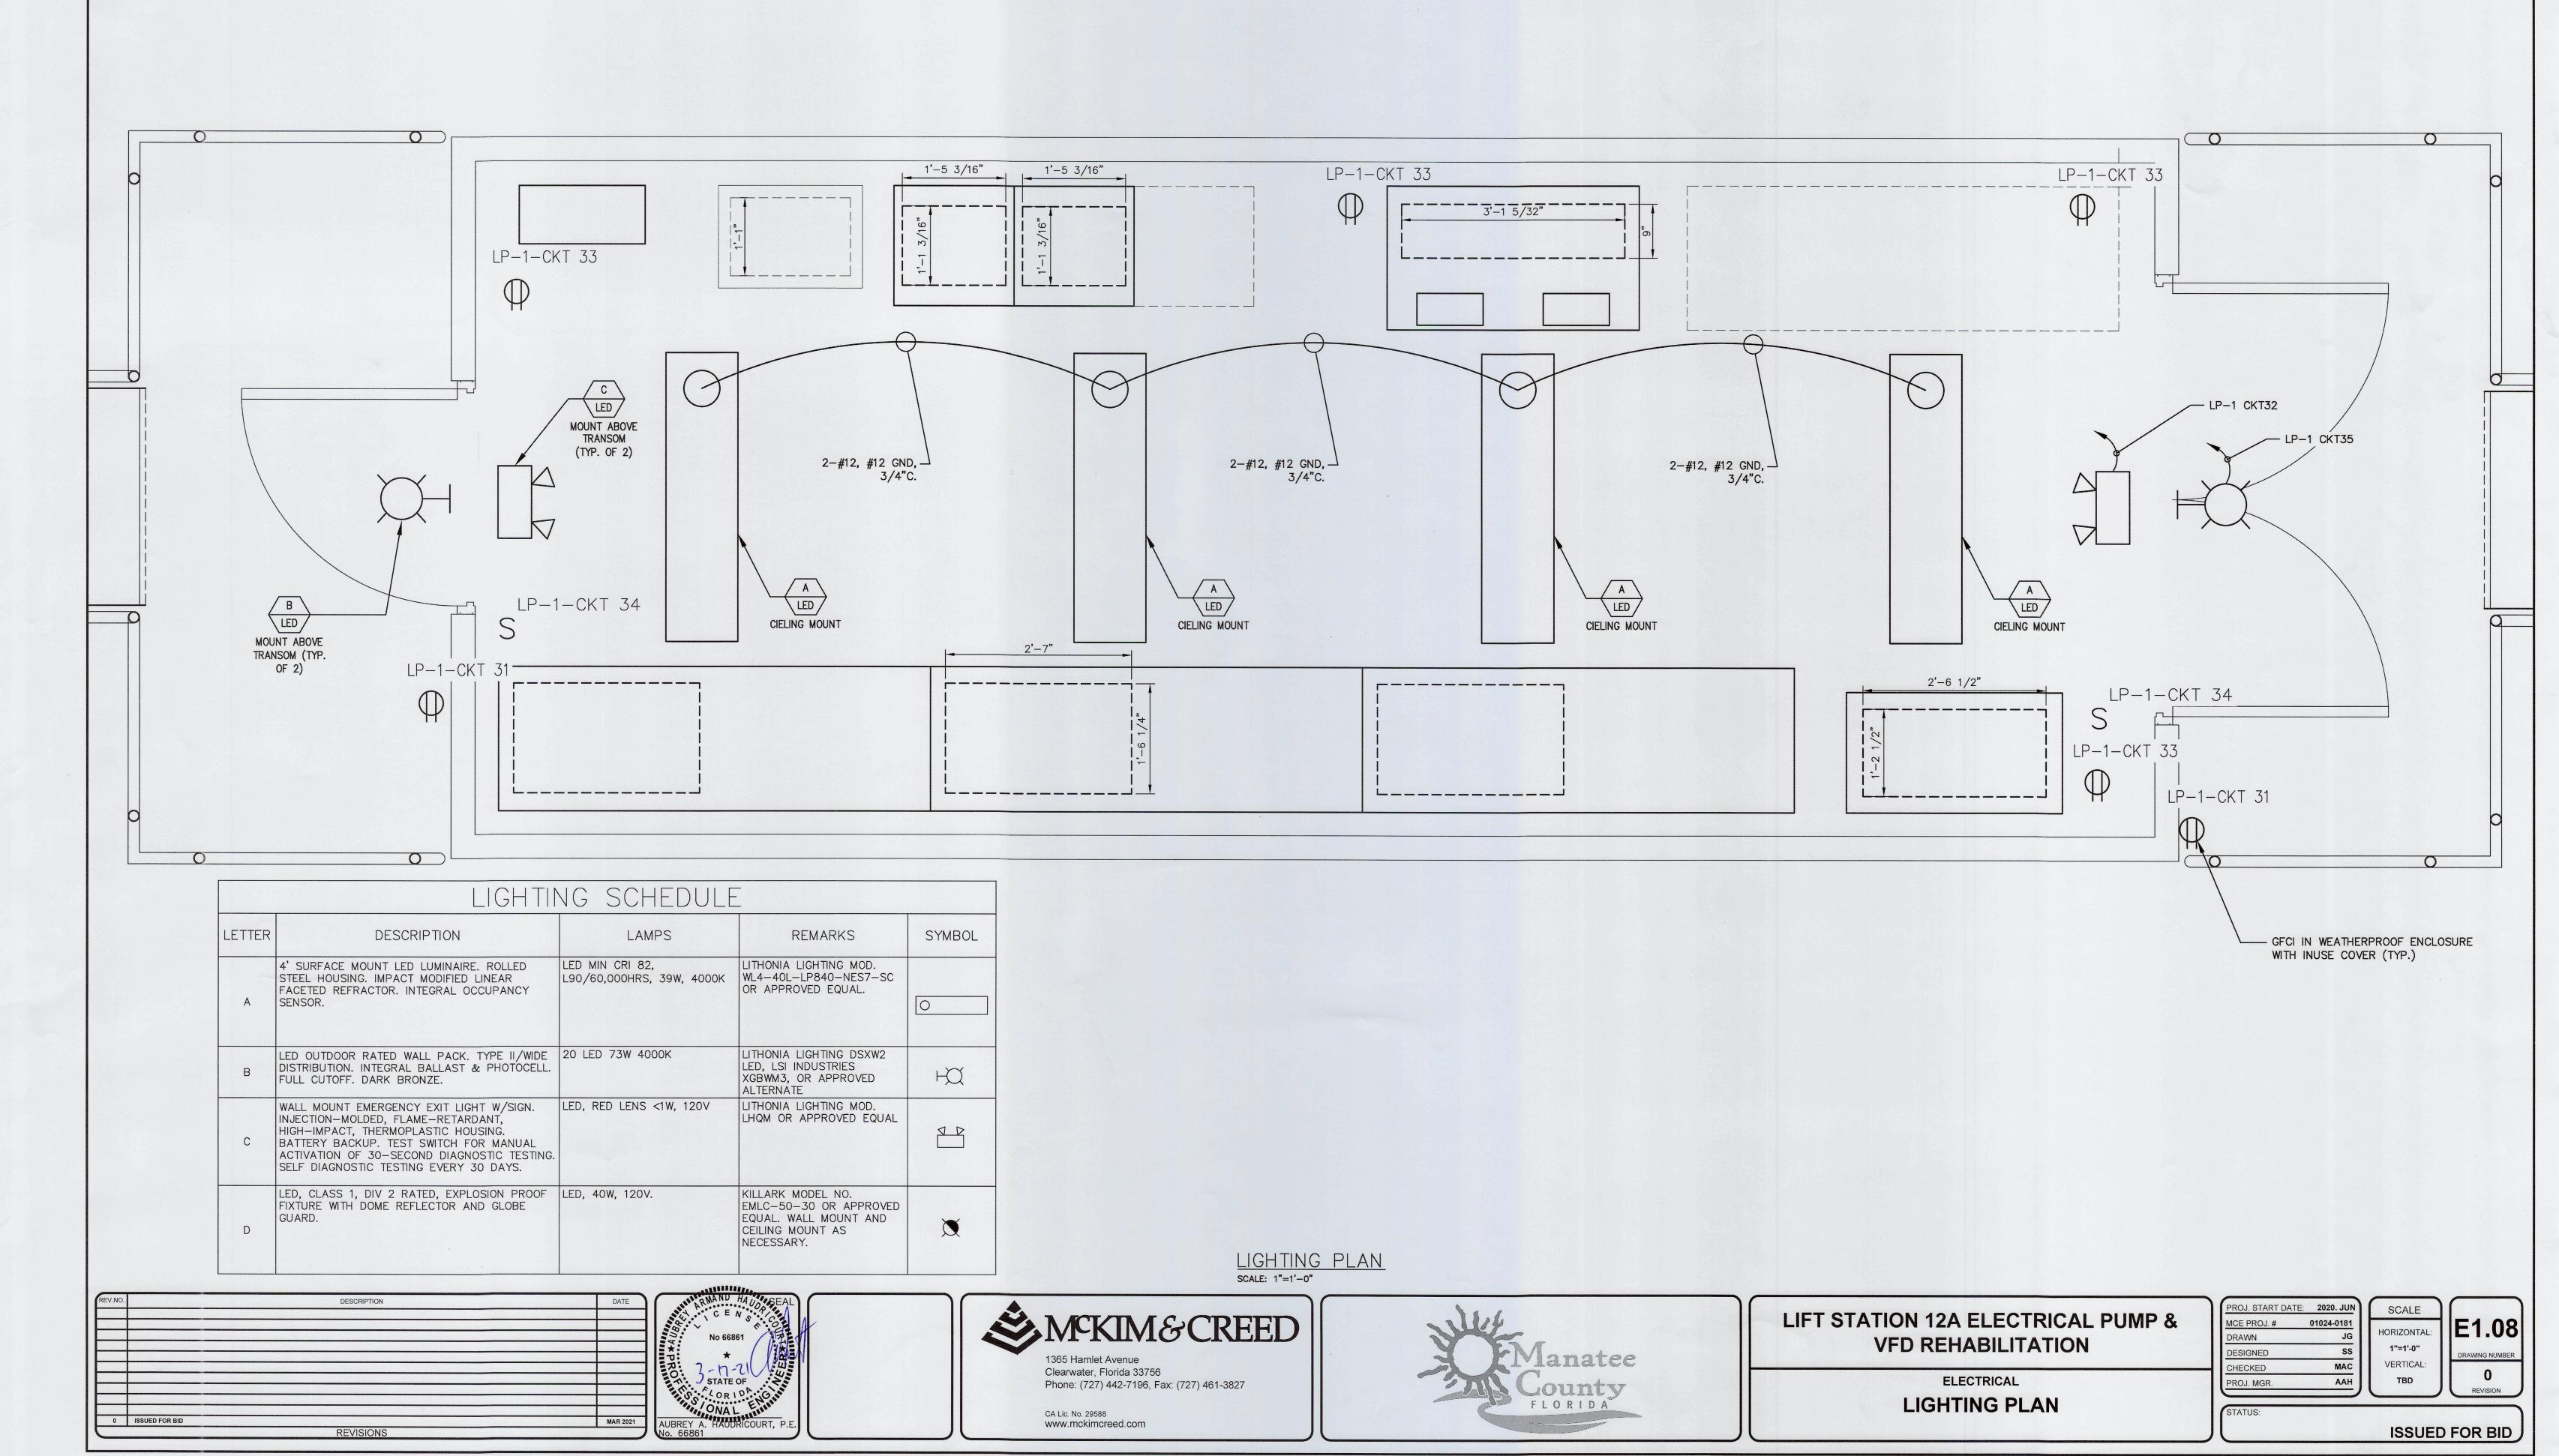

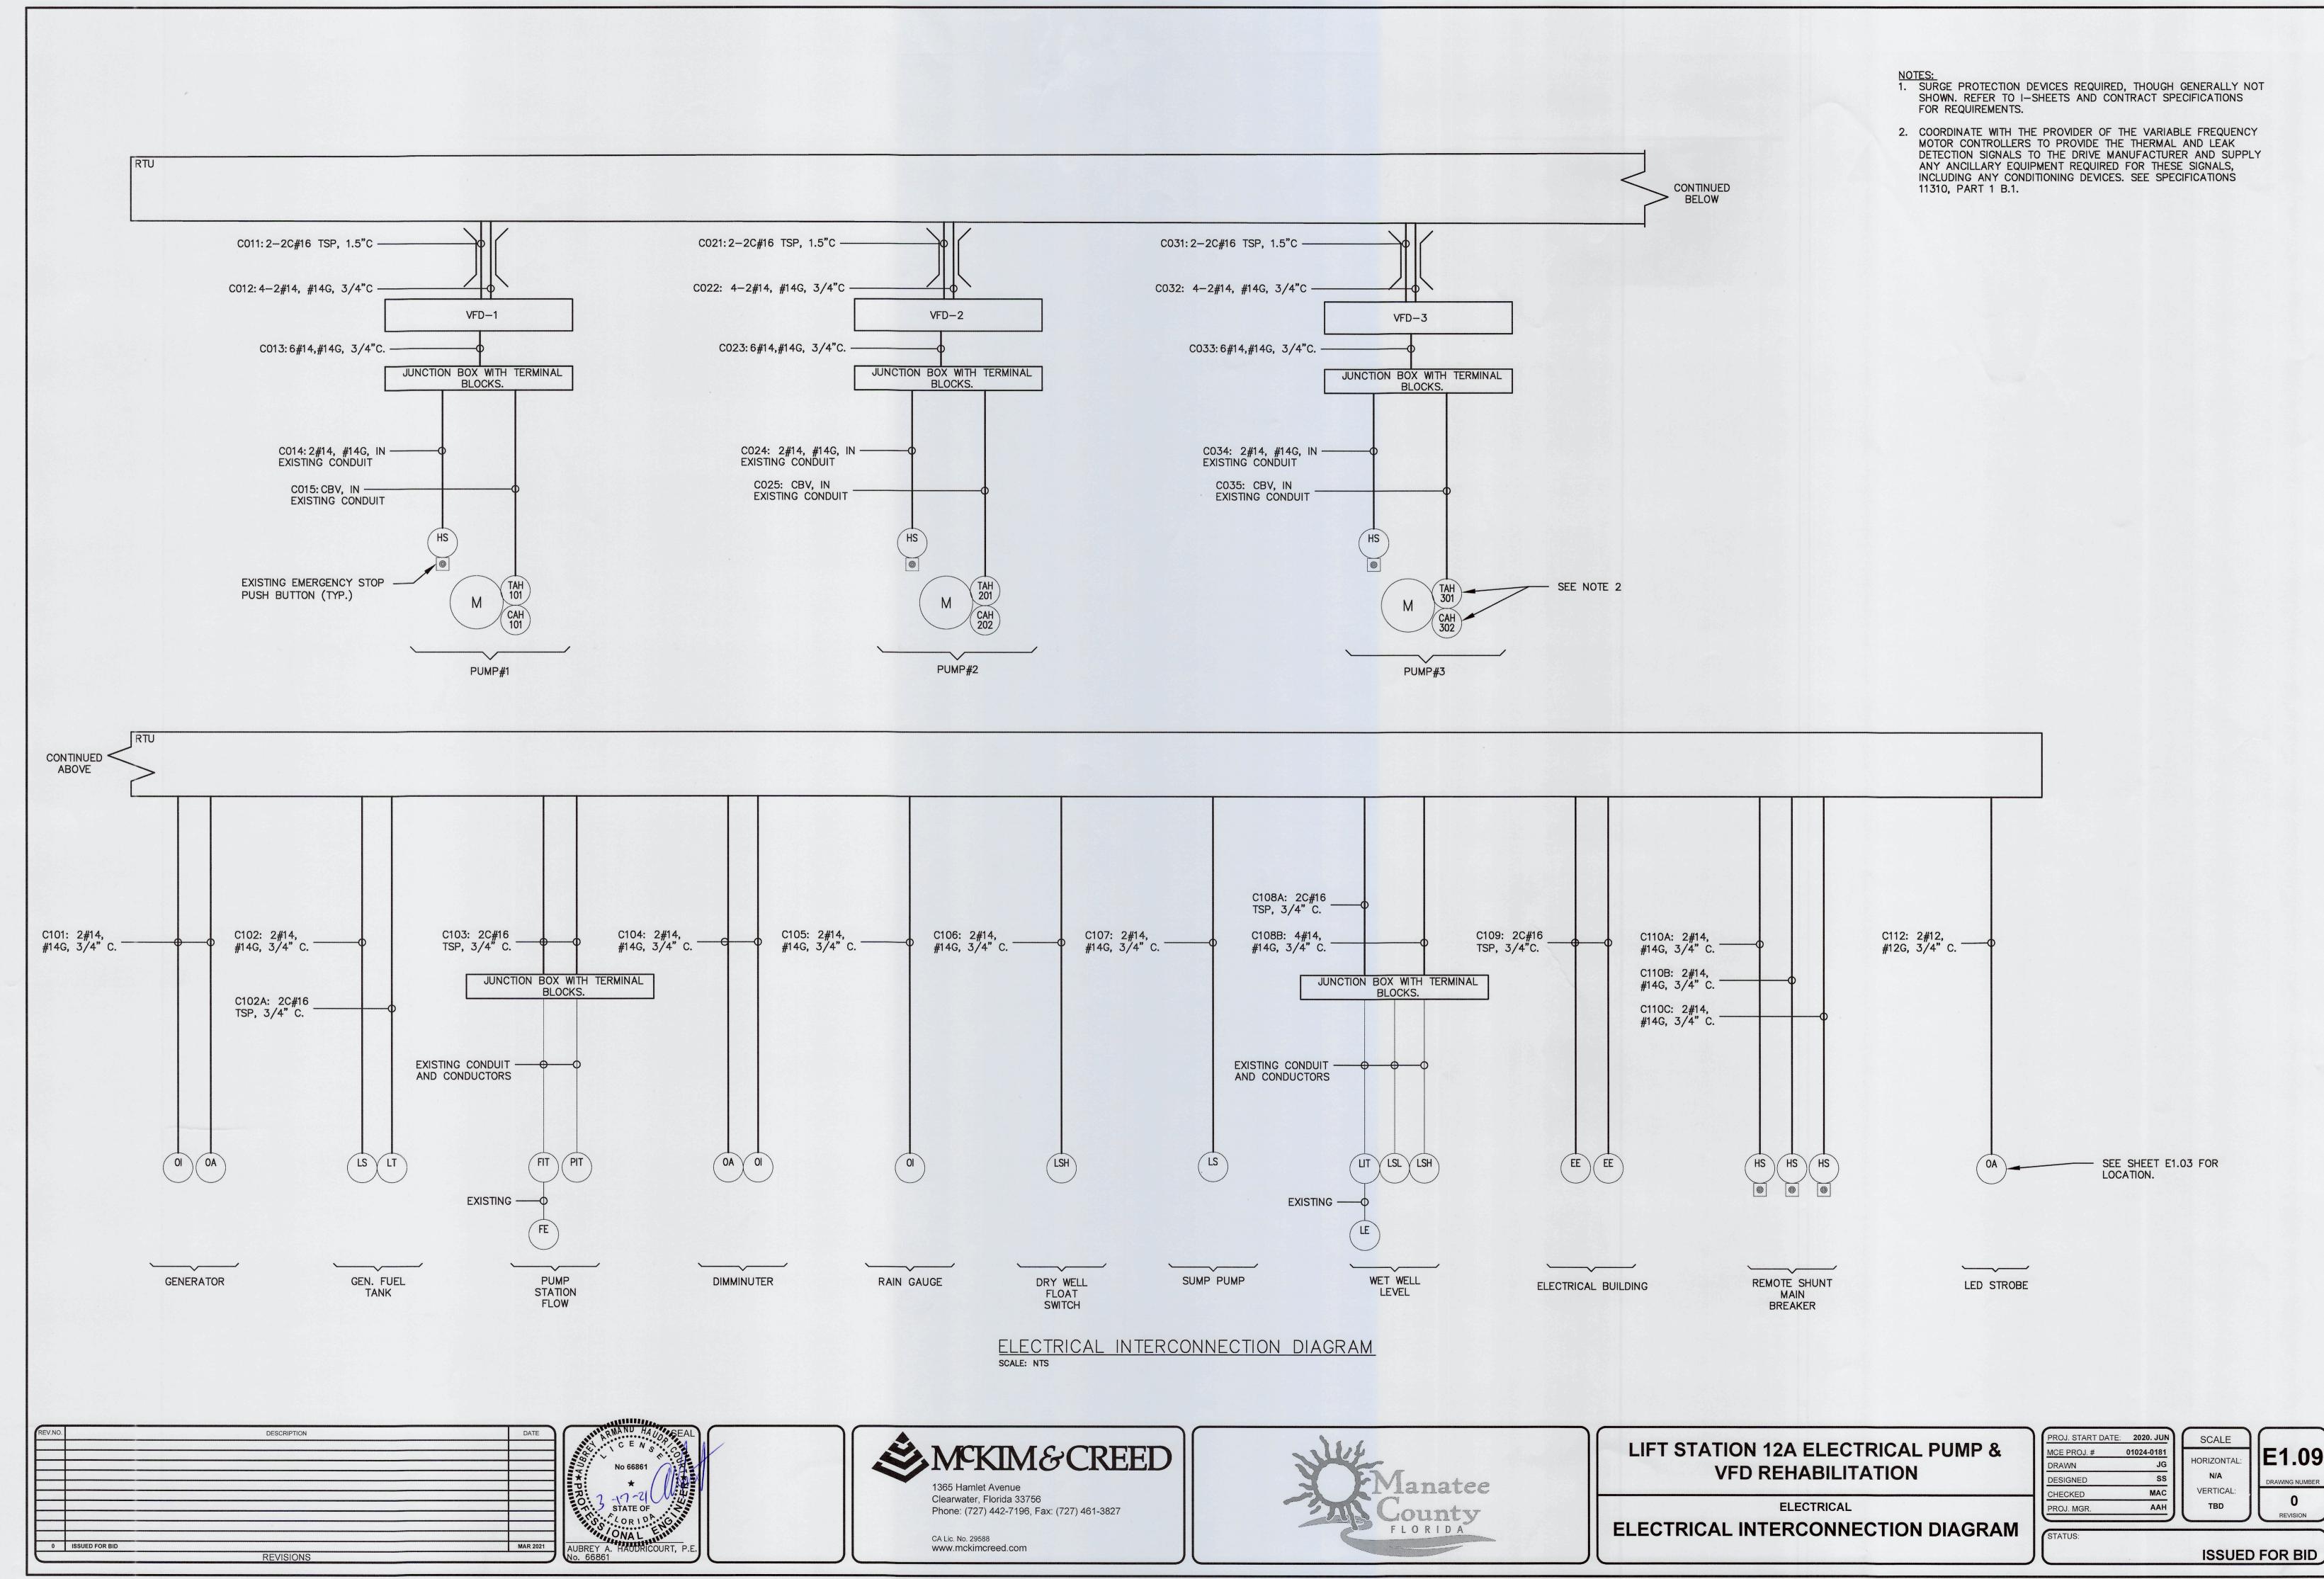

CKT NO.	TRIP	DESCRIPTION OF LOAD	LOAD KVA	AMPS	POLES	А	KVA PER PHASE B	С	POLES	AMPS	LOAD KVA	DESCRIPTION OF LOAD	TRIP	CKT NO.
1	30	DRYWELL CRANE	5.5	22.9	2	6.8		-	3	4.7	1.3	ODOR CONTROL	20	2
			5.5				6.8	and the second s			1.3			
5	30	OPERATION FLOOR CRANE	5.5	22.9	2			6.8			1.3			
			5.5			15.5			3	36.1	10	30KVA EXISITNG GENERATOR	50	8
9	30	BUDGIT CRANE	5.5	22.9	2		15.5				10	TRANSFORMER		
			5.5					15.5			10			
13	20	DIMMINUTER	0.4667	1.7	3	0.5			3			SPARE	20	14
			0.4667		000000000000000000000000000000000000000		0.5							
			0.4667					0.5						
19	20	SPARE			3	15.0			3	54.1	15	45KVA TRANSFORMER	70	20
							15.0				15			
								15.0			15			
25	30	SPARE			3	0.0			3			SURGE PROTECTION DEVICE	20	26
							0.0							
								0.0						
31	30	SPARE			3	0.0			2			SPARE	30	32
							0.0							
								0.0	2			SPARE	30	36
37		SPACE				0.0								
39							0.0		2			SPACE		40
41								0.0						
			то	TAL KVA		37.8	37.8	37.8				SERVICE CHARACTERISTICS		
	PANEL	. PP-1								VOLTS:		-	225	_ A MLO
		MANATEE COUNTY	GRANI	O CONNECT	ED TO	TAL KVA	113.	3		PHASE:			0	_ A MCB
		E ELECTRICAL BUILDING  : INTEGRATED PANELBOARD							J	WIRE: 10K	***************************************	SYMM, FULLY RATED ASSEMBLY		

PANEL SCHEDULE PP-1
scale: NTS


	P S				ES	ŀ	(VA PER PHAS	E	ES				P So	
CKT NO.	TRIP	DESCRIPTION OF LOAD	LOAD KVA	AMPS	POLES	Α	В	С	POLES	AMPS	LOAD KVA	DESCRIPTION OF LOAD	TRIP	CKT NO
1	20	ELEC. BUILDING RECEPTACLES OUTSIDE	0.36	3.0	1	0.5			1	1.5	0.18	ELEC. BUILDING EMERG. EXIT LIGHT	20	2
3	20	ELEC. BUILDING RECEPTACLES INSIDE	0.72	6.0	1		1.5		1	6.7	0.8	ELEC. BUILDING LIGHTING INSIDE	20	4
5	20	ELEC. BUILDING OUTSIDE WALL PACKS	0.5	4.2	1			2.1	2	15.4	1.6	ELEC. BUILDING AC OUTDOOR UNIT #1	25	6
7	15	ELEC. BUILDING AC INDOOR UNIT #1	0.1	1.0	2	1.7					1.6			
			0.1				1.7		2	15.4	1.6	ELEC. BUILDING AC OUTDOOR UNIT #2	25	10
11	15	ELEC. BUILDING AC INDOOR UNIT #2	0.1	1.0	2			1.7			1.6			
			0.1			7.5			3	61.7	7.4	PANEL LP-2	100	14
15	20	SURGE PROTECTION DEVICE			3		7.4				7.4			
								7.4			7.4			
						0.0			1			SPARE	20	20
21	20	SPARE			1		0.0		1			SPARE	20	22
23	20	SPARE			1			0.0	1			SPARE	20	24
25	20	SPARE			1	0.0			1			SPARE	20	26
27	20	SPARE			1		0.0		1			SPARE	20	28
29	20	SPARE			1			0.0	1			SPARE	20	30
31	20	SPARE			1	0.0			1			SPARE	20	32
33	20	SPARE			1		0.0		1			SPARE	20	34
35	20	SPARE			1			0.0	1			SPARE	20	36
37	20	SPARE			1	0.0			1			SPARE	20	38
39	20	SPARE			1		0.0		1			SPARE	20	40
41	20	SPARE			1			0.0	1					42
	PANEL	LP-1	то	TAL KVA		9.8	10.6	11.2		VOLTS:	208Y/120	SERVICE CHARACTERISTICS		A MLO
		MANATEE COUNTY NEW ELECTRICAL BUILDING	GRANI	CONNEC.	TED TO	TAL KVA	33	1.6		PHASE: WIRE:			150	_ A MCB
	NOTES	: INTEGRATED PANELBOARD										YMM, FULLY RATED ASSEMBLY		

PANEL SCHEDULE LP-1 scale: NTS

	P				ES		KVA PER PHASE		ES				P S	
CKT NO.	TRIP	DESCRIPTION OF LOAD	LOAD KVA	AMPS	POLES	А	В	С	POLES	AMPS	LOAD KVA	DESCRIPTION OF LOAD	TRIP	CKT NO.
1	30	UNKNOWN	0.18	1.5	1	0.4			1	1.5	0.18	UNKNOWN	15	2
3	15	BATTERY CHARGER	0.06	0.5	1		1.2		1	9.2	1.1	#1 PUMP SPEED CONTROLLER	15	4
5	30	#2 PUMP SPEED CONTROLLER	1.1	9.2	1			2.2	1	9.2	1.1	#4 PUMP SPEED CONTROLLER	15	6
7	20	SUMP PUMP	0.07	0.6	1	1.6	a de servicios e de		1	12.5	1.5	WET WELL LIGHTS	20	8
9	20	OPER FLOOR LIGHTS	1.2	10.0	1		2.4	- 4884 (F. 1888)	1	10.0	1.2	OPER FLOOR LIGHTS	20	10
11	20	OUTDOOR FLOODLIGHTS	1.2	10.0	1	0.000		2.2	1	8.3	1	OUTDOOR FLOODLIGHTS	20	12
13	20	CHLOR STORAGE LIGHTS			1	0.1			1	0.7	0.08	OPER FLOOR RECEPTACLES	20	14
15	20	OPER FLOOR RECEPTACLES	1	8.3	1		2.4		1	11.7	1.4	DRY WELL LIGHTS	20	16
17	20	DRY WELL LIGHTS	1.4	11.7	1			1.4	1	0.1	0.01	TOILET LIGHTS	20	18
19	20	CHLORINATOR HEATER	0.05	0.4	1	0.1	- 10-28-08-03-08-09-		2			SPARE	20	20
21	20	SURGE PROTECTION DEVICE	0.1	0.8	3		0.1							
			0.1					0.1	3			SPARE	30	24
			0.1			0.1								
27					1		0.0							
29	20	SPARE			1			0.0	1			SPARE	20	30
31	20	SPARE			1	0.0			1			SPARE	20	32
33	20	SPARE			1		0.0		1			SPARE	20	34
35	20	SPARE			1			0.0	1			SPARE	25	36
37	20	SPARE			1	0.0			1	1. 1. T. C		SPARE	20	38
39	20	SPARE			1		0.0		1			SPARE	20	40
41	20	SPARE			1			0.0	1			SPARE	20	42
			то	TAL KVA		2.2	6.1	5.9			**	SERVICE CHARACTERISTICS		
		LP-2								VOLTS:	208Y/120			A MLO
		MANATEE COUNTY  OLD PUMP BUILDLING	GRANI	D CONNECT	TED TO	OTAL KVA	14.	1		PHASE:			100	_ A MCB
	NOTES								J	WIRE:		SYMM, FULLY RATED ASSEMBLY		
	NOTES.									IUN	IVIII AIC C	STIVIIVI, FOLLT RATED ASSEMBLT		

PANEL SCHEDULE LP-2 scale: NTS

REV.NO.	DESCRIPTION	DATE
0	ISSUED FOR BID	MAR 2021
8	DEVICIONS	

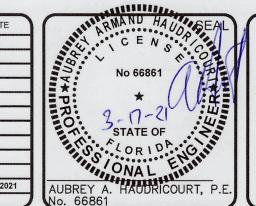





# LIFT STATION 12A ELECTRICAL PUMP & VFD REHABILITATION


PANEL BOARD SCHEDULES

2020. JUN	SCALE
01024-0181	
JG	HORIZONTAL:
SS	N/A
MAC	VERTICAL:
AAH	TBD
	01024-0181 JG SS MAC


ISSUED FOR BID

\MCKIMCREED.COM\NASUNI\DATA\PROJ\01024\0181\WATER\80-DRAWINGS\ELECTRICAL\SCHEDULES AND TABLES.DWG 03/17/2021 11:44:47 SUVATH SENG

#### 11"x18" POLYMER CONCRETE BOX WITH OPEN BOTTOM AND TRAFFIC RATED COVER WITH 3" LETTERING "GROUND TEST WELL" FINISHED GRADE MECHANICAL CONNECTION COARSE SAND OR PEA GRAVEL #57 CRUSHED STONE BARE COPPER GROUND CU-CLAD GROUND GROUND ROD TEST WELL SCALE: NTS

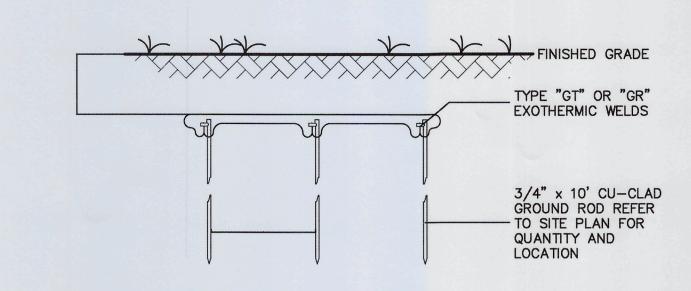

 BELOW GRADE GROUND ROD/CABLE CONNECTION DETAIL



FINISHED

GRADE

- HILTI HDI-P DROP

IN ANCHOR (TYP.)

- WASHER & 1/2"

BOLT SS.

- 3" COPPER

PLATE

GROUND BUS

EXPOSED CONDUIT AS INDICATED ON POWER PLANS

RIGID METALLIC CONDUIT

WITH PROTECTIVE COATING

1. MINIMUM WIRE SIZE FOR ALL POWER CIRCUITS IS #12AWG CU UNLESS OTHERWISE NOTED.

4. FOR LOW VOLTAGE DUCTBANKS MINIMUM SEPARATION BETWEEN CONDUITS SHALL BE 2".

3. SWAB CLEAN EXISTING CONDUITS PRIOR TO PULLING NEW CIRCUITS.


NOTES:

2. MINIMUM CONDUIT SIZE IS 3/4" TRADE SIZE.

1" HILTI HDI-P -

DROP IN ANCHOR


(TYP.)

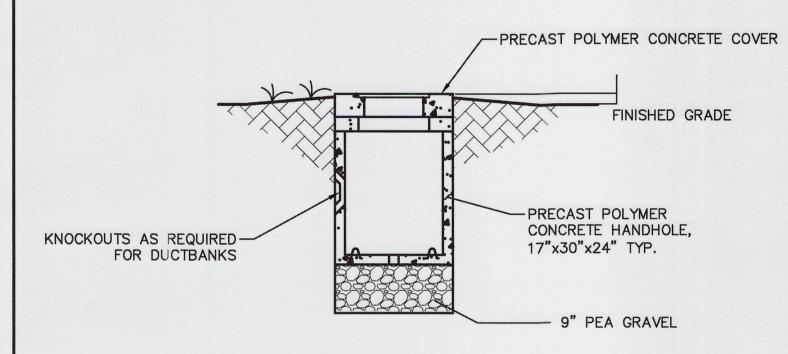


SMALL HANDHOLE NOTES:

- 1. PROVIDE PRODUCTS OF ONE OF THE FOLLOWING:
- A. STRONGWELL QUAZITE
- B. OLD CASTLE
- C. OR APPROVED EQUAL
- 2. MATERIAL: PRECAST POLYMER CONCRETE. 3. DUCT ENTRANCES SIZED AND LOCATED TO SUIT
- DUCTBANKS. 4. ENCLOSURES AND COVERS SHALL BE UL-LISTED. 5. ENCLOSURES, BOXES, AND COVERS SHALL COMPLY WITH TEST PROVISIONS OF ANSI/SCTE 77 FOR TIER 15 & 22
- 6. COVERS SHALL HAVE COEFFICIENT OF FRICTION OF NOT LESS THAN 0.50, IN ACCORDANCE WITH ASTM C1028.


SMALL HANDHOLE DETAIL SCALE: N.T.S.

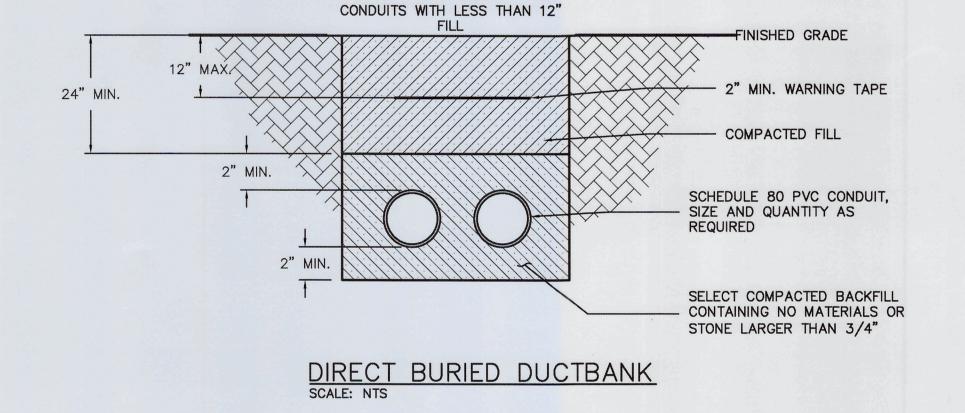


DO NOT TAMP DIRECTLY OVER

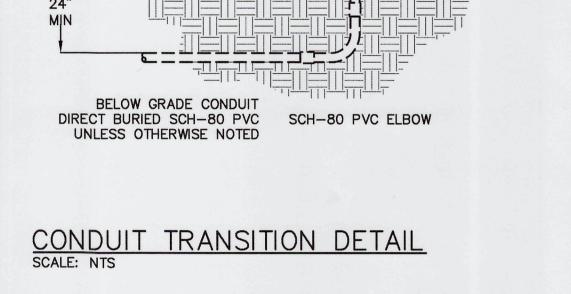


6" MIN

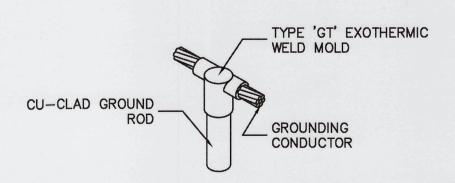



EXOTHERMIC WELD 'GT' CONNECTION SCALE: NTS

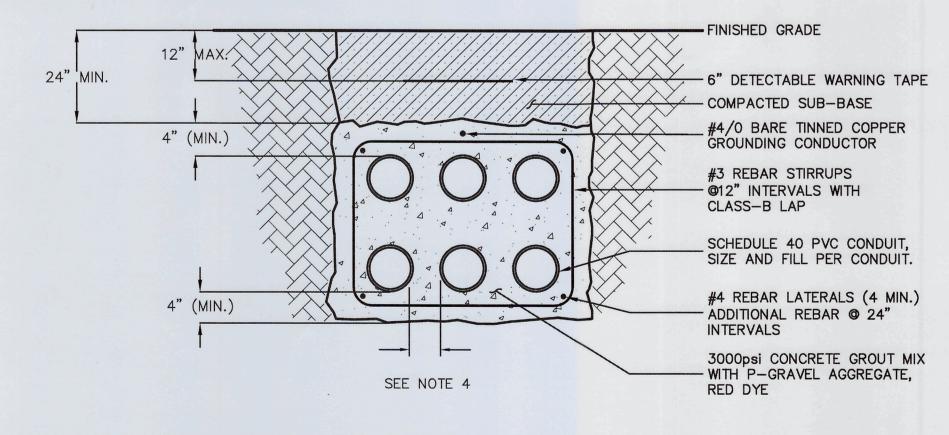


REINFORCED CONCRETE DUCTBANK SCALE: NTS

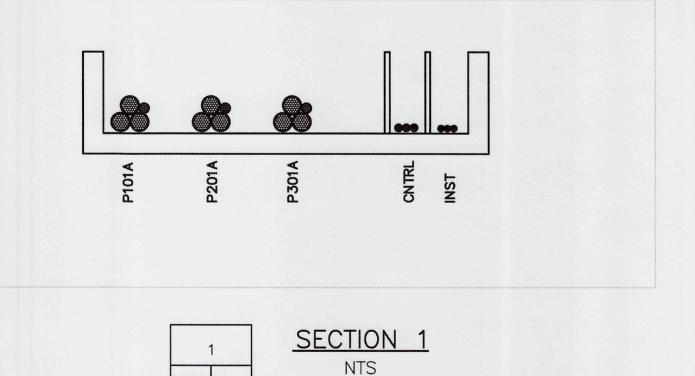

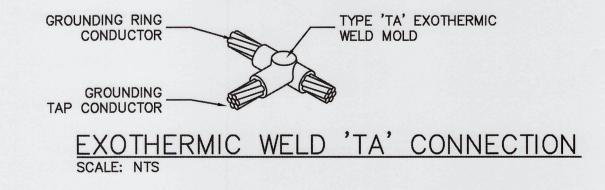

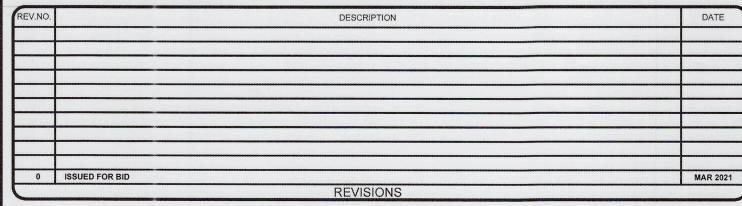

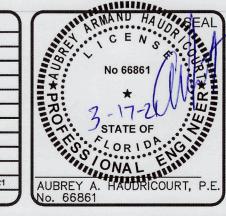



CA Lic. No. 29588

www.mckimcreed.com




#### LIFT STATION 12A ELECTRICAL PUMP & **VFD REHABILITATION**


ELECTRICAL **DETAILS** 

PROJ. START DATE:	2020. JUN	SCALE	
MCE PROJ. #	01024-0181		E1.1
DRAWN	JG	HORIZONTAL:	LI
DESIGNED	SS	N/A	DRAWING NUM
CHECKED	MAC	VERTICAL:	0
PROJ. MGR.	AAH	TBD	REVISION

**ISSUED FOR BID** 

\\MCKIMCREED.COM\\NASUNI\DATA\PROJ\01024\0181\\WATER\80-DRAWINGS\ELECTRICAL\\DETAILS.DWG\03/17/2021\11:45:01\SUVATH\SENG

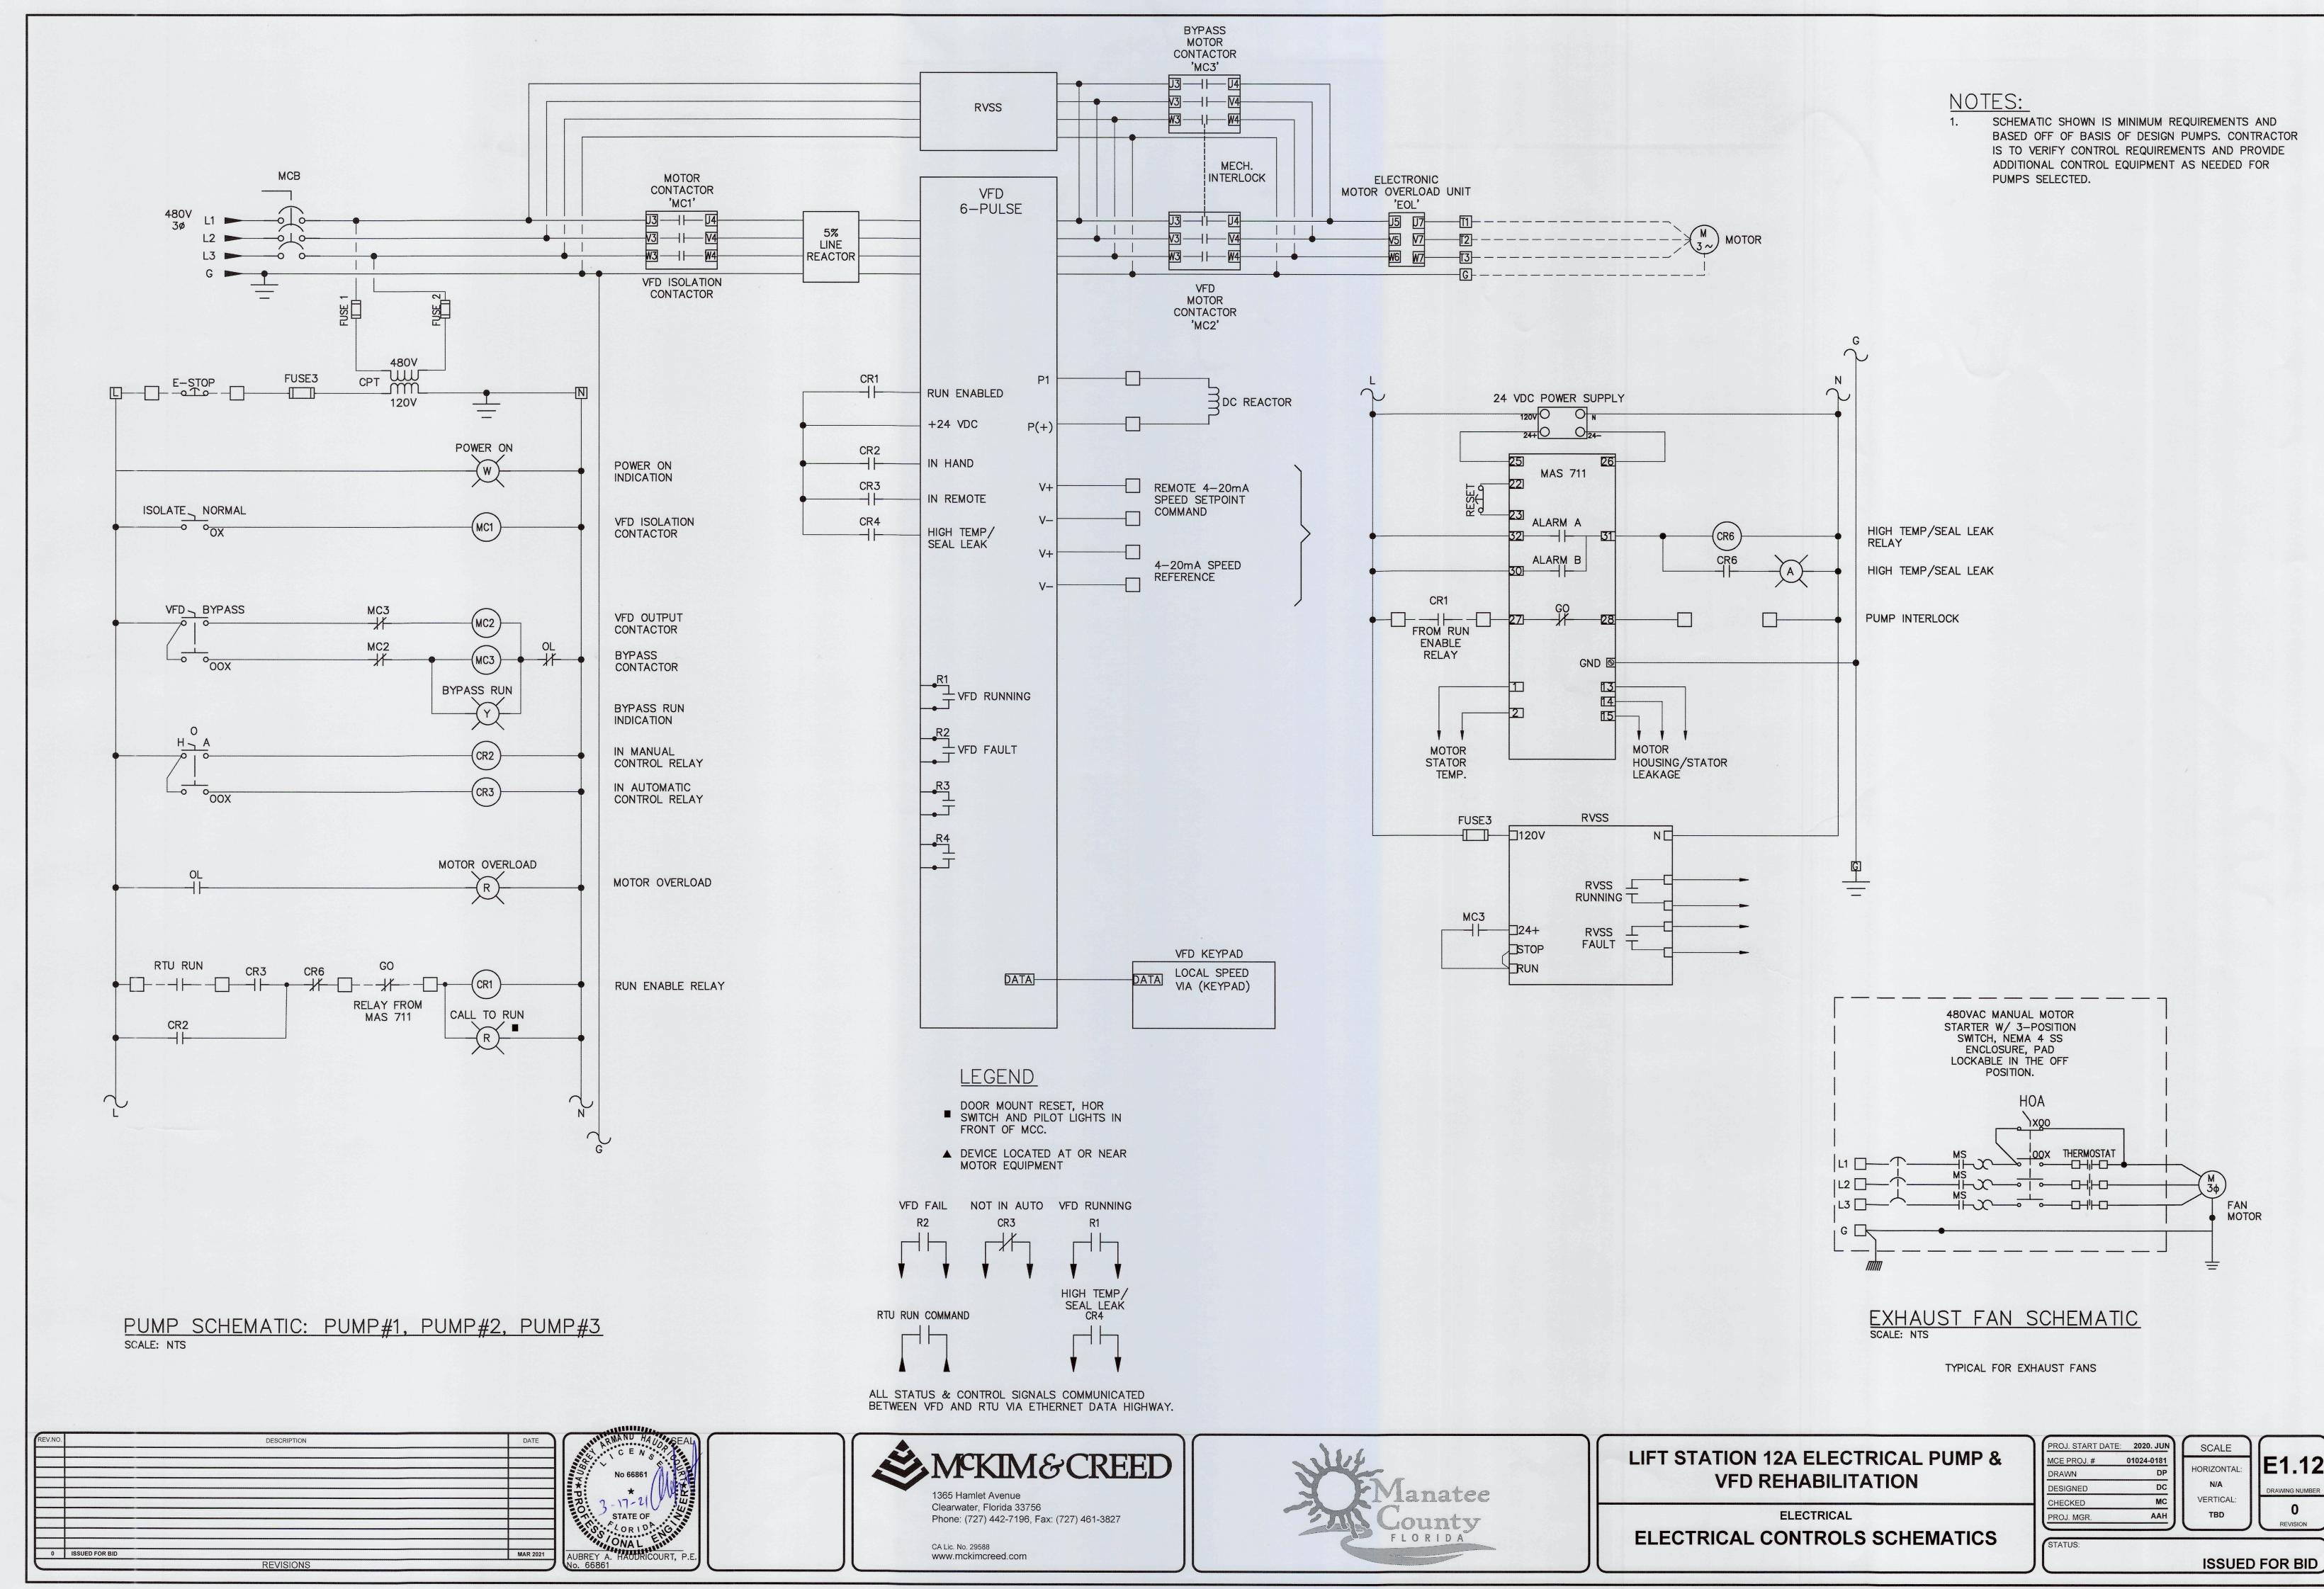

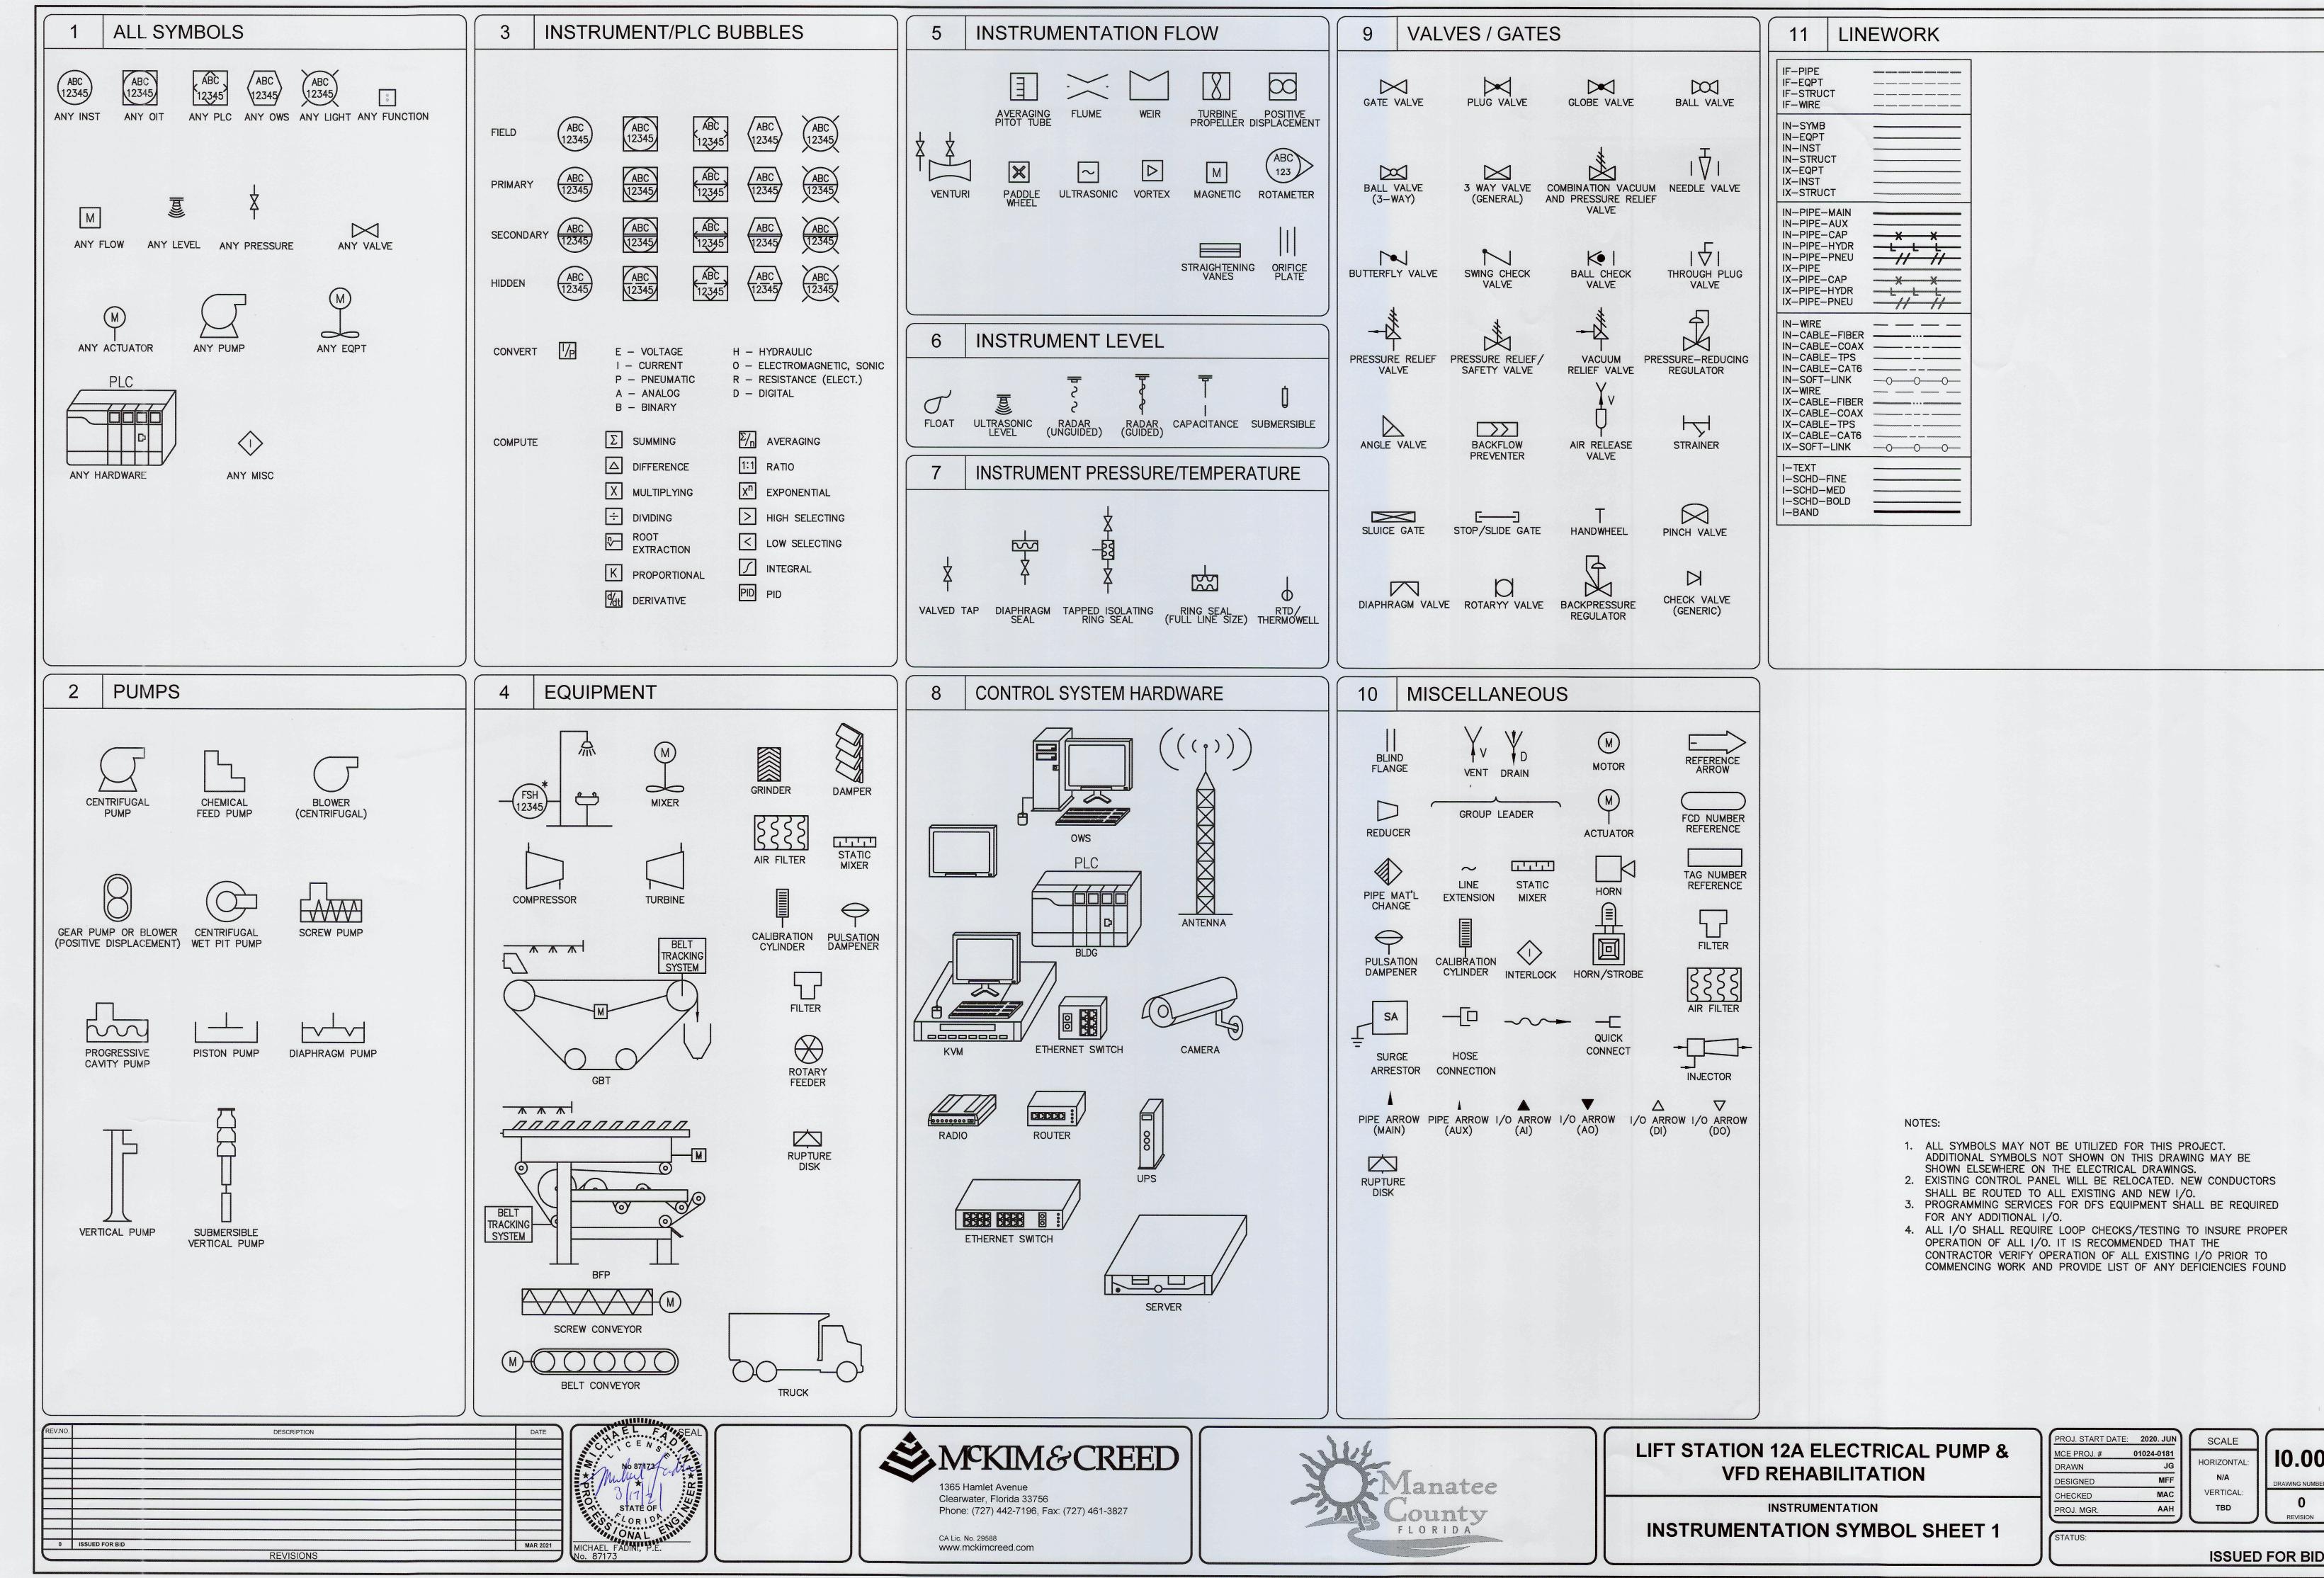

### 1 PID FUNCTION SYMBOLS

	FIRST LET	TER		SUCCEEDING-LETTER	rs .
	MEASURED OR		READOUT OR	ОИТРИТ	
	INITIATING VARIABLE	MODIFIER	PASSIVE FUNCTION	FUNCTION	MODIFIER
Α	Analysis		Alarm		
В	Burner, Combustion		Programmer		
С	Conductivity			Control	Closed
	(Electrical)				
D	Density or	Differential			
	Specific Gravity				
E	Voltage		Sensor (Primary	Eduction	
			Element)		
F	Flow Rate	Ratio (Fraction)			
G	Gaging		Glass,		
			Viewing Device		
Н	Hand				High
_	Current (Electrical)		Indicate		
J	Power	Scan			
K	Time, Time Schedule			Control Station	
L	Level		Light (Pilot)		Low
М	Motor				Middle,
					Intermediate
N	Vibration				
0	Operation	Offset	Orifice, Restriction		Open
Р	Pressure, Vacuum		Point (Test)		
			Connection		
Q	Quantity, Event	Integrate, Totalize	Integrate		
R	Radiation		Record, Print	Regulate	
S	Speed, Frequency	Safety		Switch	
Т	Temperature			Transmit	
U	Multivariable	Trend	Multifunction	Multifunction	Multifunction
V	Viscosity	Vacuum		Valve, Damper,	
				Louver, Gate	
W	Weight, Force,		Well		
	Torque				
X	Unclassified		Unclassified	Unclassified	Unclassified
Y				Relay, Compute,	
				Convert	
Z	Position			Final	Drive, Actuator,
				Control	Unclassified
				Element	Final Control
					Element

/.NO.	DESCRIPTION	DATE
0 ISSUED FOR BID		MAR 202







# LIFT STATION 12A ELECTRICAL PUMP & VFD REHABILITATION

INSTRUMENTATION

**INSTRUMENTATION SYMBOL SHEET 2** 

1	PROJ. START DATE:	2020. JUN	s
	MCE PROJ. #	01024-0181	
	DRAWN	JG	HOF
	DESIGNED	MFF	
	CHECKED	MAC	VE
	PRO LMGR	AAH	

HORIZONTAL:


N/A

VERTICAL:

TBD


ISSUED FOR BID


\\MCKIMCREED.COM\NASUNI\DATA\PROJ\01024\0181\WATER\80-DRAWINGS\INSTRUMENTATION\LEAD SHEET.DWG 03/17/2021 11:45:23 SUVATH SENG

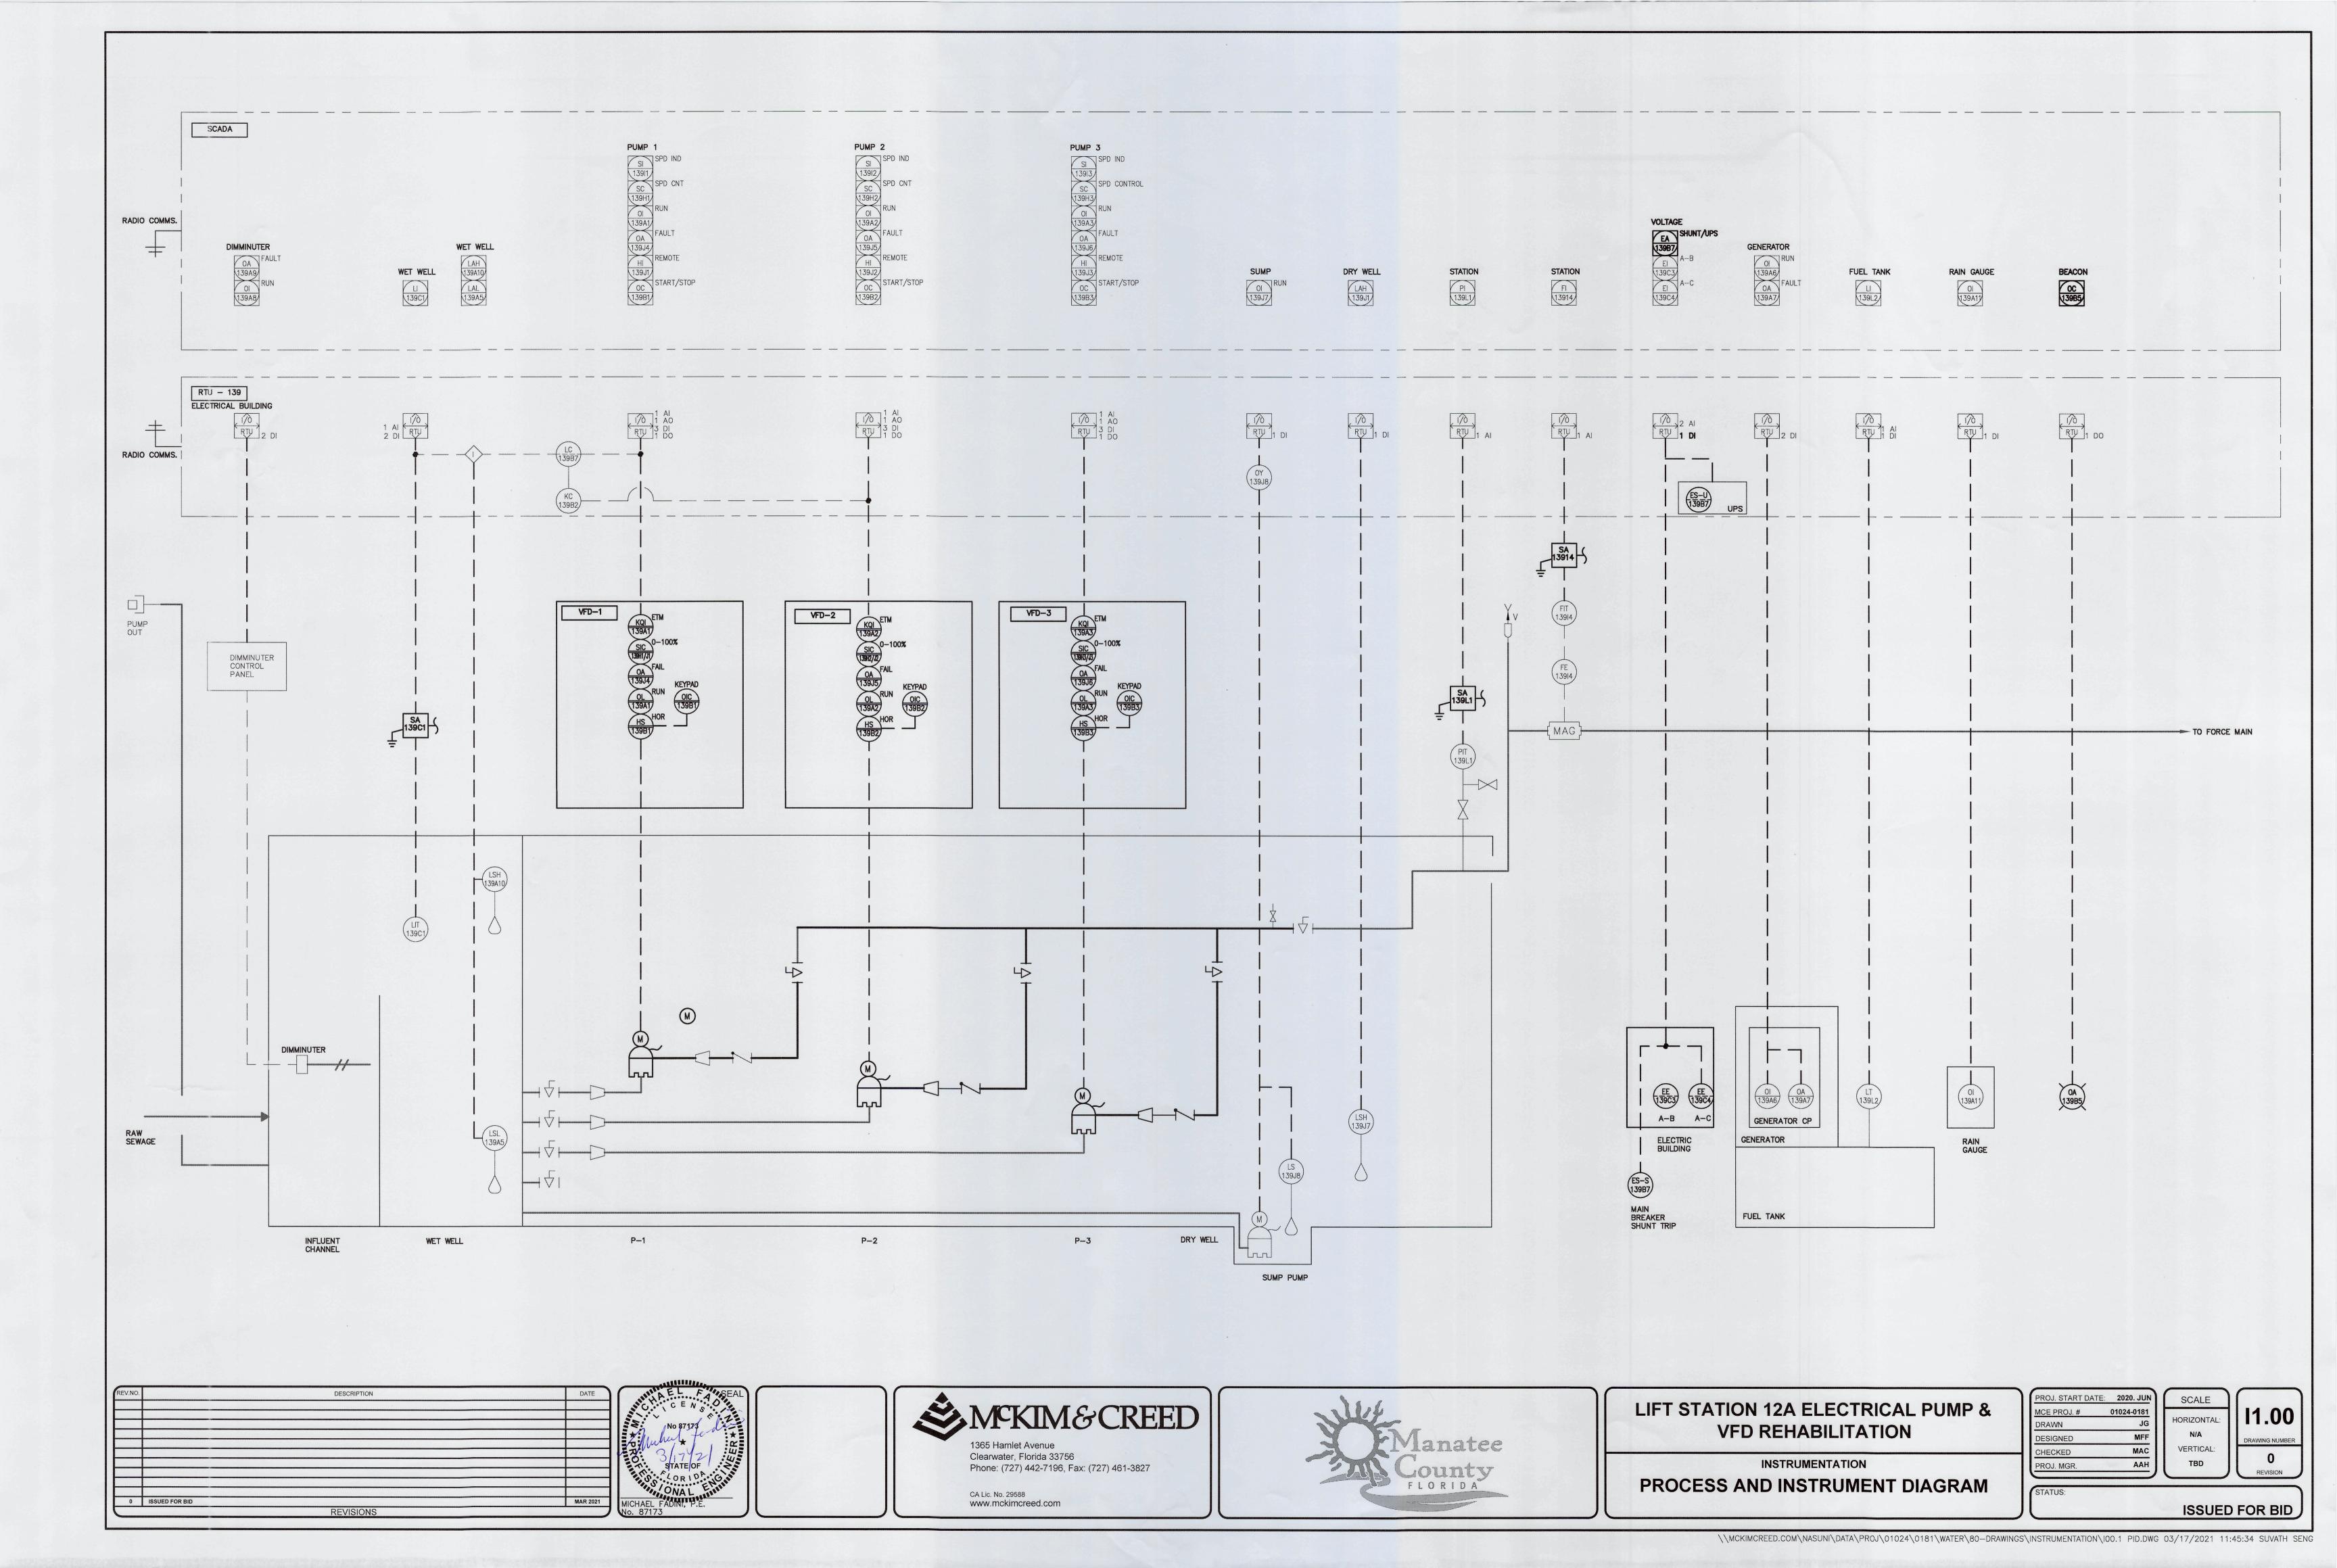


#### NOTES:

- 1. LOCATE WINDOW IN POSITION WHICH ALLOWS DFS-RTU TO BE VISIBLE WITHOUT OPENING THE PANEL DOOR
- 2. SUBPANEL LAYOUT AND SCHEMATIC ARE DIAGRAMATTIC TO CONVEY MINIMUM REQUIREMENTS FOR FABRICATION AND INSTALLATION.
- 3. NEW SHUNT AND UPS COMMON ALARM SHALL BE WIRED TO SPARE INPUT B7. B7 IS NORMALLY CONFIGURED FOR ALARM IS SILENCED INDICATION AND SHALL BE CHANGED IN DFS SOFTWARE.

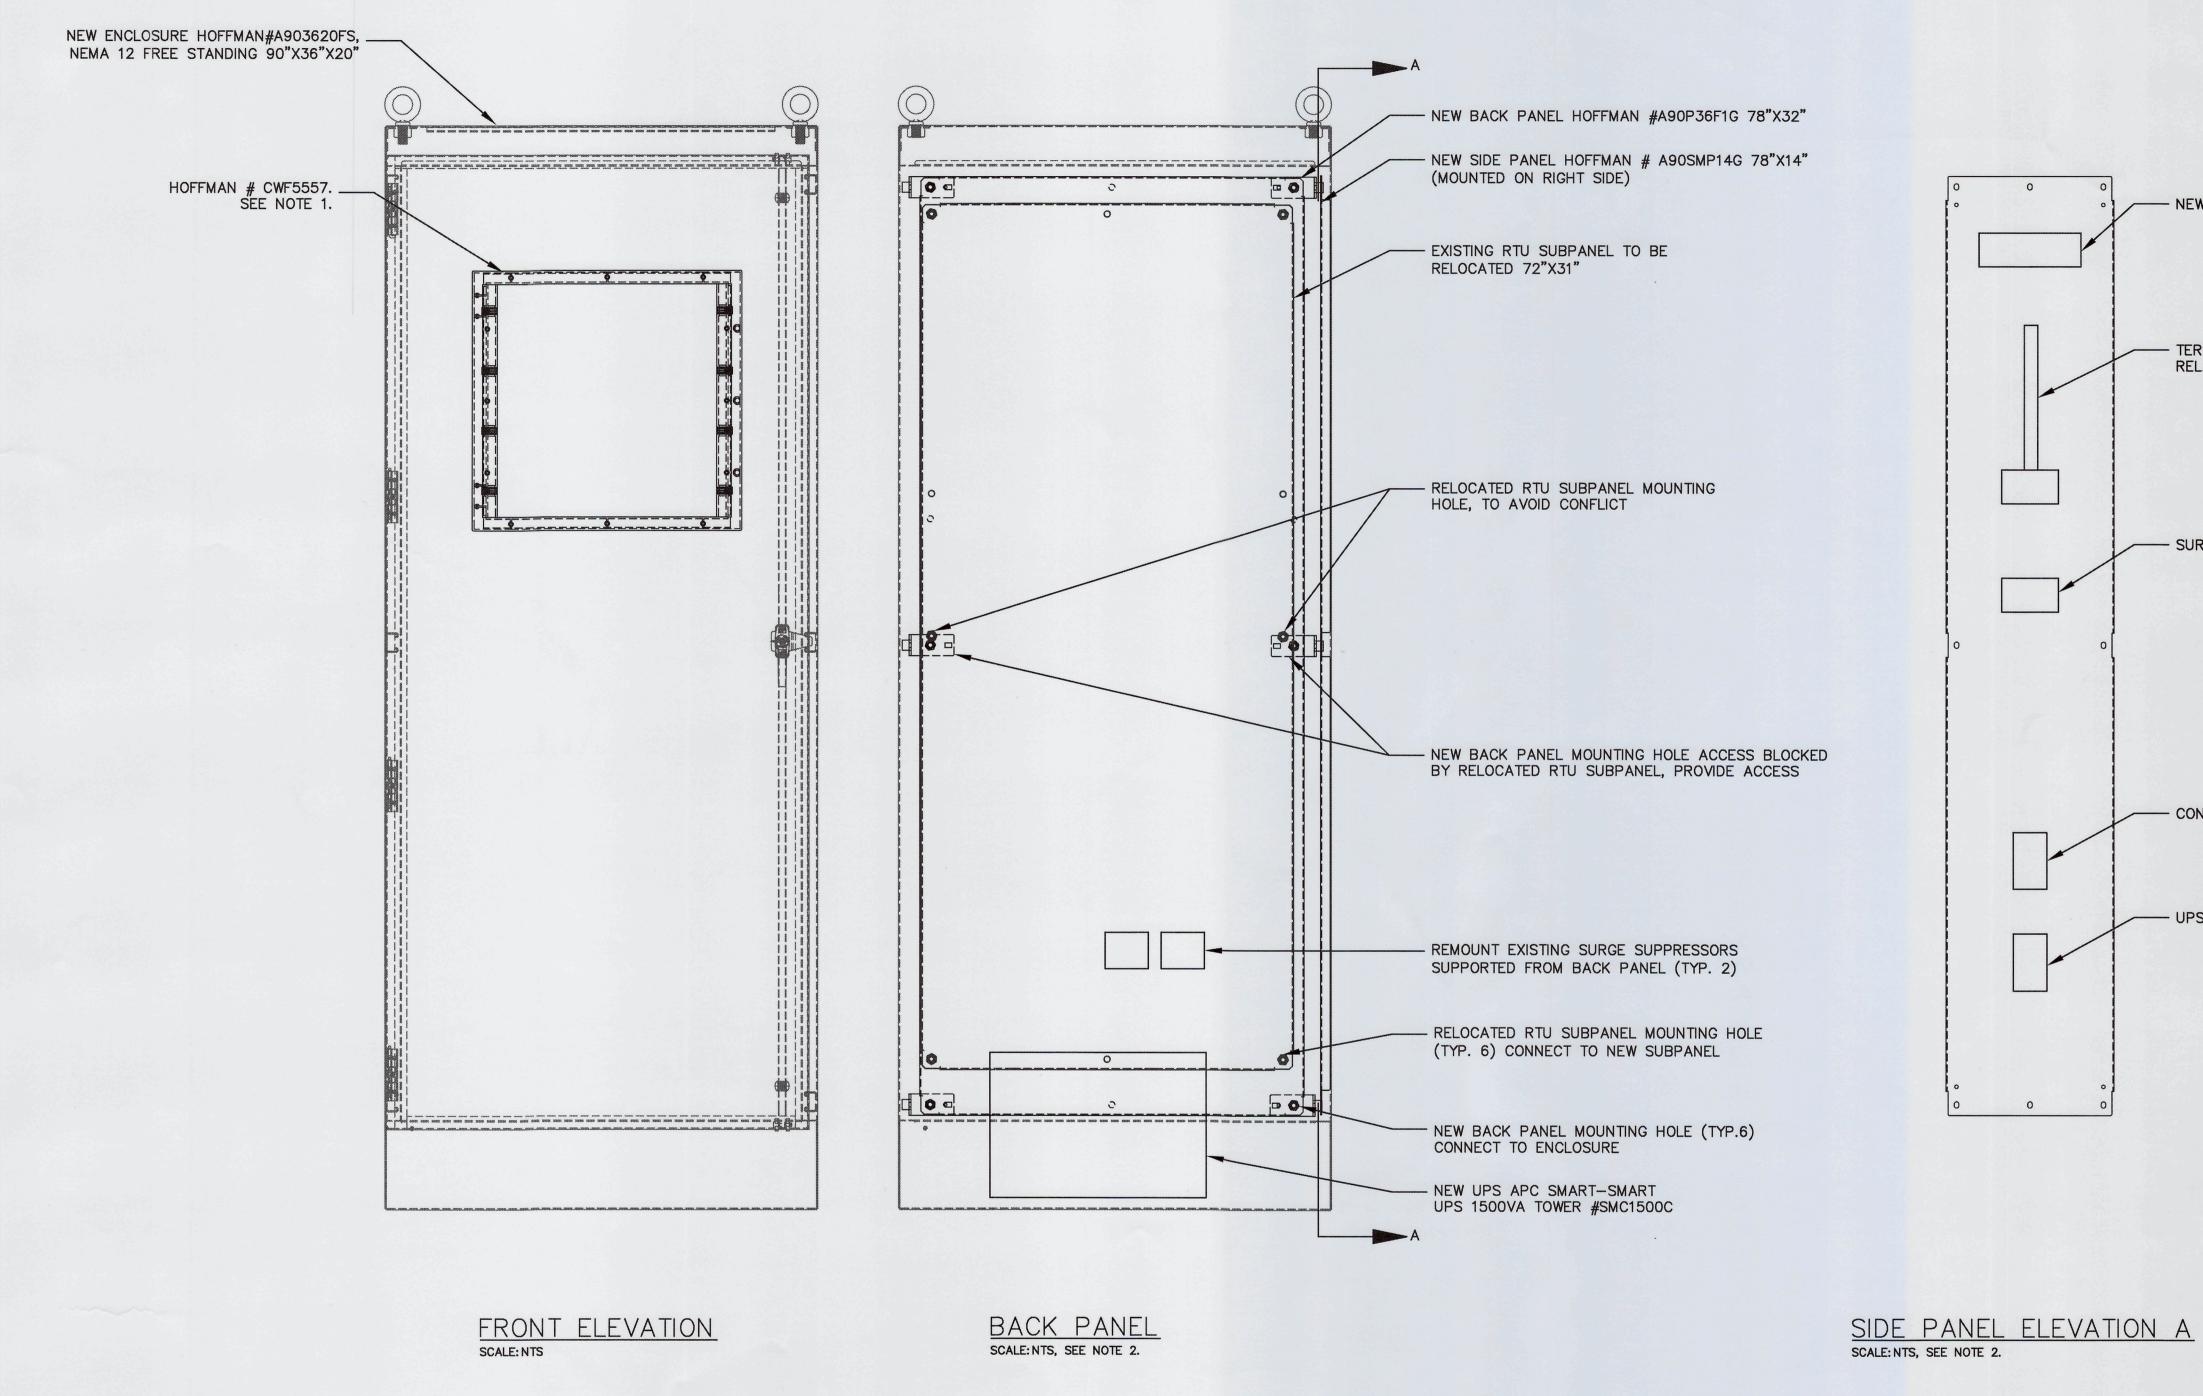

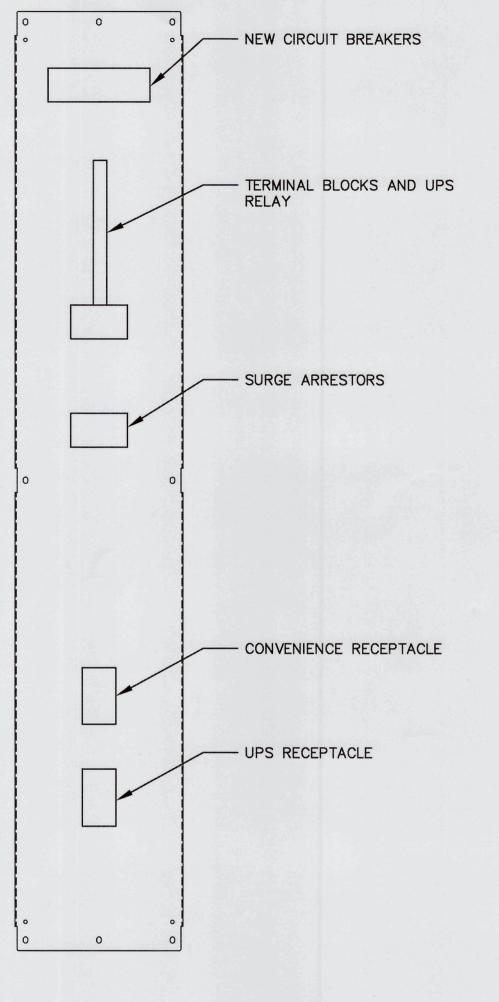


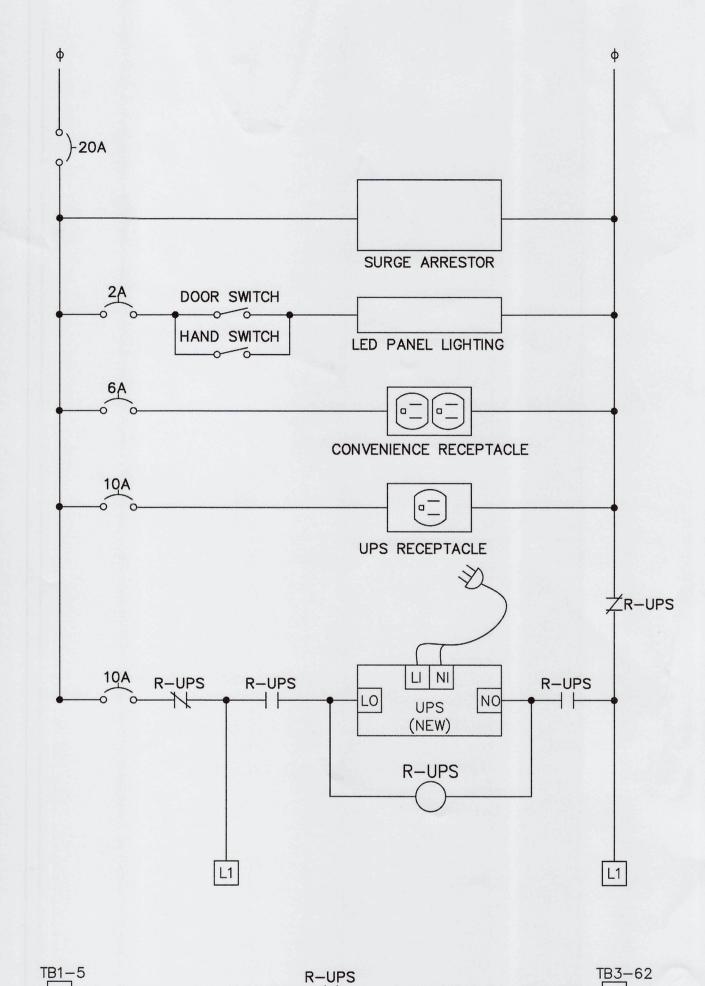

SHUNT

CONTROL PANEL SCHEMATIC DIAGRAM SCALE: NTS, SEE NOTE 2.

DESCRIPTION

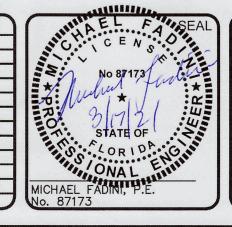





LIFT STATION 12A ELECTRICAL PUMP & **VFD REHABILITATION** 

> INSTRUMENTATION **CONTROL PANEL**

PROJ. START DATE:	2020. JUN	SCALE
MCE PROJ. #	01024-0181	
DRAWN	JG	HORIZONTAL:
DESIGNED	MFF	N/A
CHECKED	MAC	VERTICAL:
PROJ. MGR.	AAH	TBD