



landscape
structural engineering
mechanical engineering
electrical engineering architecture civil engineering

SCHENKEL SHULTZ ARCHITECTURE
ZNS ENGINEERING
ZNS ENGINEERING
XNS ENGINEERING
ME3 CONSULTING ENGINEERS
ME3 CONSULTING ENGINEERS
ME3 CONSULTING ENGINEERS

## 0Wntown

CAT ON THE GO

677 North Washington Blvd.
Sarasota, FI 34236
voice 941.952.5875
fax 941.957.3630
schenkelshultz.com
SS Lic No - AA-C000937

SCHENKELSHULTZ

radenton

# Station

601 13th Street West Bradenton, FI, 34205



Manatee County Government 1112 Manatee Ave West 8th Floor Bradenton, FI 34208

#### location map

PROJECT AREA: 0.50 ACRES LOCATION: ON 13TH ST WEST BETWEEN 6TH AVE WEST AND 8TH AVE WEST. PLEASE SEE MAP ON THIS SHEET FOR MORE INFO.

### sheet index

design rendering

DRAINAGE AND GRADING PLAN DRAINAGE DETAILS DRAINAGE DETAILS WATER & SEWER DETAILS SECTIONS SECTIONS SECTIONS SECTIONS SIGNAGE AND STRIPING PLAN MAINTENANCE OF TRAFFIC PLAN MAINTENANCE OF TRAFFIC PLAN

LANDSCAPE PLAN IRRIGATION PLAN LANDSCAPE SPECIFICATIONS LANDSCAPE AND IRRIGATION SPECIFICATIONS

\$\$\$\$\$\$\$\$\$\$\$\$5432444 BUILDING STRUCTURE
BUILDING STRUCTURE
BUILDING STRUCTURE
BUS SHELTER STRUCTURE
ART WALL STRUCTURE
PERGOLA STRUCTURES
STRUCTURAL NOTES SCHEDULES


ARCHITECTURAL INFORMATION SHEET ARCHITECTURAL SITE PLAN BUILDING FLOOR PLAN BUILDING FLOOR PLAN BUILDING FLOOR PLAN ENLARGED PLANS EQUIPEMNT AND FINISH FLOOR PLAN REFLECTED CEILING PLAN ROOF PLAN ROOF DETAILS EXTERIOR ELEVATIONS EXTERIOR ELEVATIONS EXTERIOR ELEVATIONS EXTERIOR ELEVATIONS WALL SECTIONS WALL SECTIONS MISCELLANEOUS DETAILS MISCELLANEOUS DETAILS MISCELLANEOUS DETAILS

design rendering

MECHANICAL FLOOR AND ROOF PLANS MECHANICAL DETAILS MECHANICAL SCHEDULES

design rendering

ELECTRICAL LEGEND
ELECTRICAL SITE PLAN
LIGHTING PLANS
LIGHTING PLANS
LIGHTING PLANS
LIGHTING PLANS
ELECTRICAL FLOOR PLANS
ELECTRICAL DOF PLANS
ELECTRICAL DETAILS
ELECTRICAL DETAILS
ELECTRICAL RISER
LIGHTING SCHEDULES
ELECTRICAL SCHEDULES
ELECTRICAL SCHEDULES PLUMBING LEGEND & SCHEDULES PLUMBING FLOOR PLAN PLUMBING DETAILS

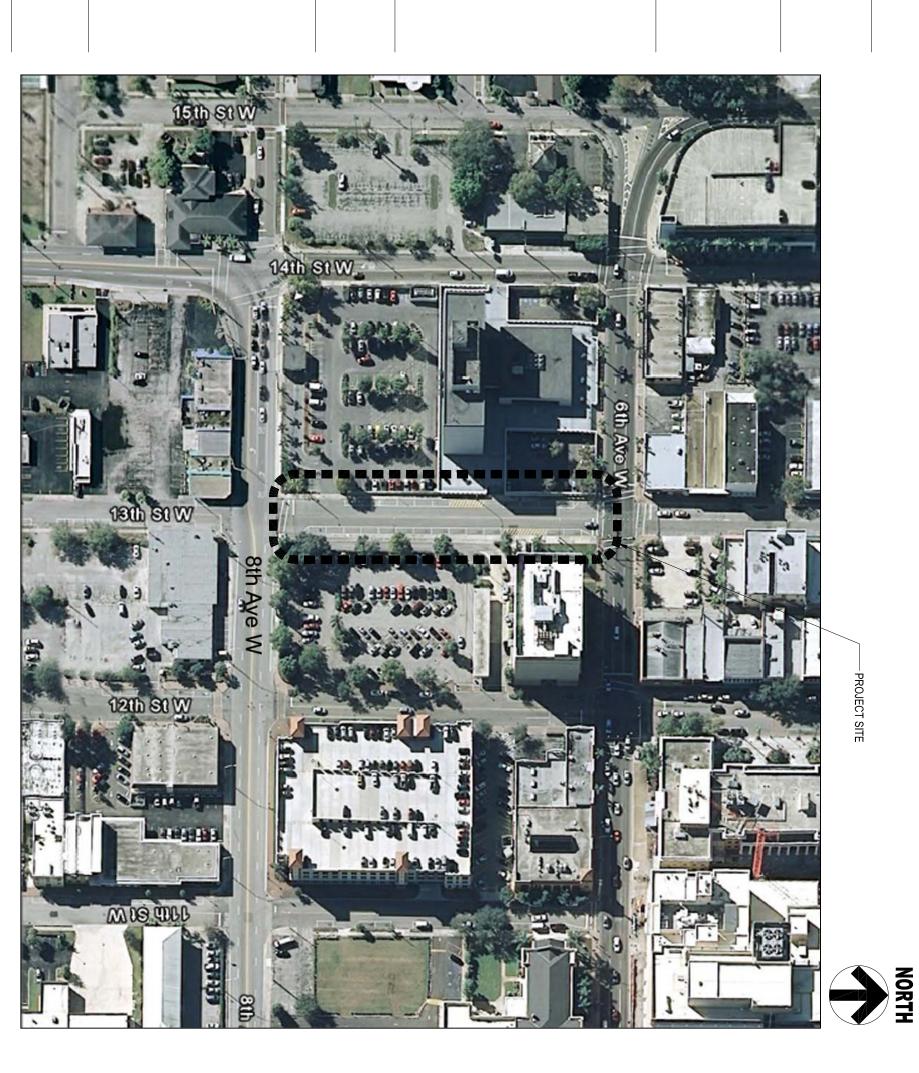

Downtown Bradenton


Transit Station

Manatee County Government 1112 Manatee Ave West 8th Floor Bradenton, FI 34208

601 13th Street West Bradenton, FI 34205

**COVER SHEET** 

date: 11.12.10 comm. no.: 0920818

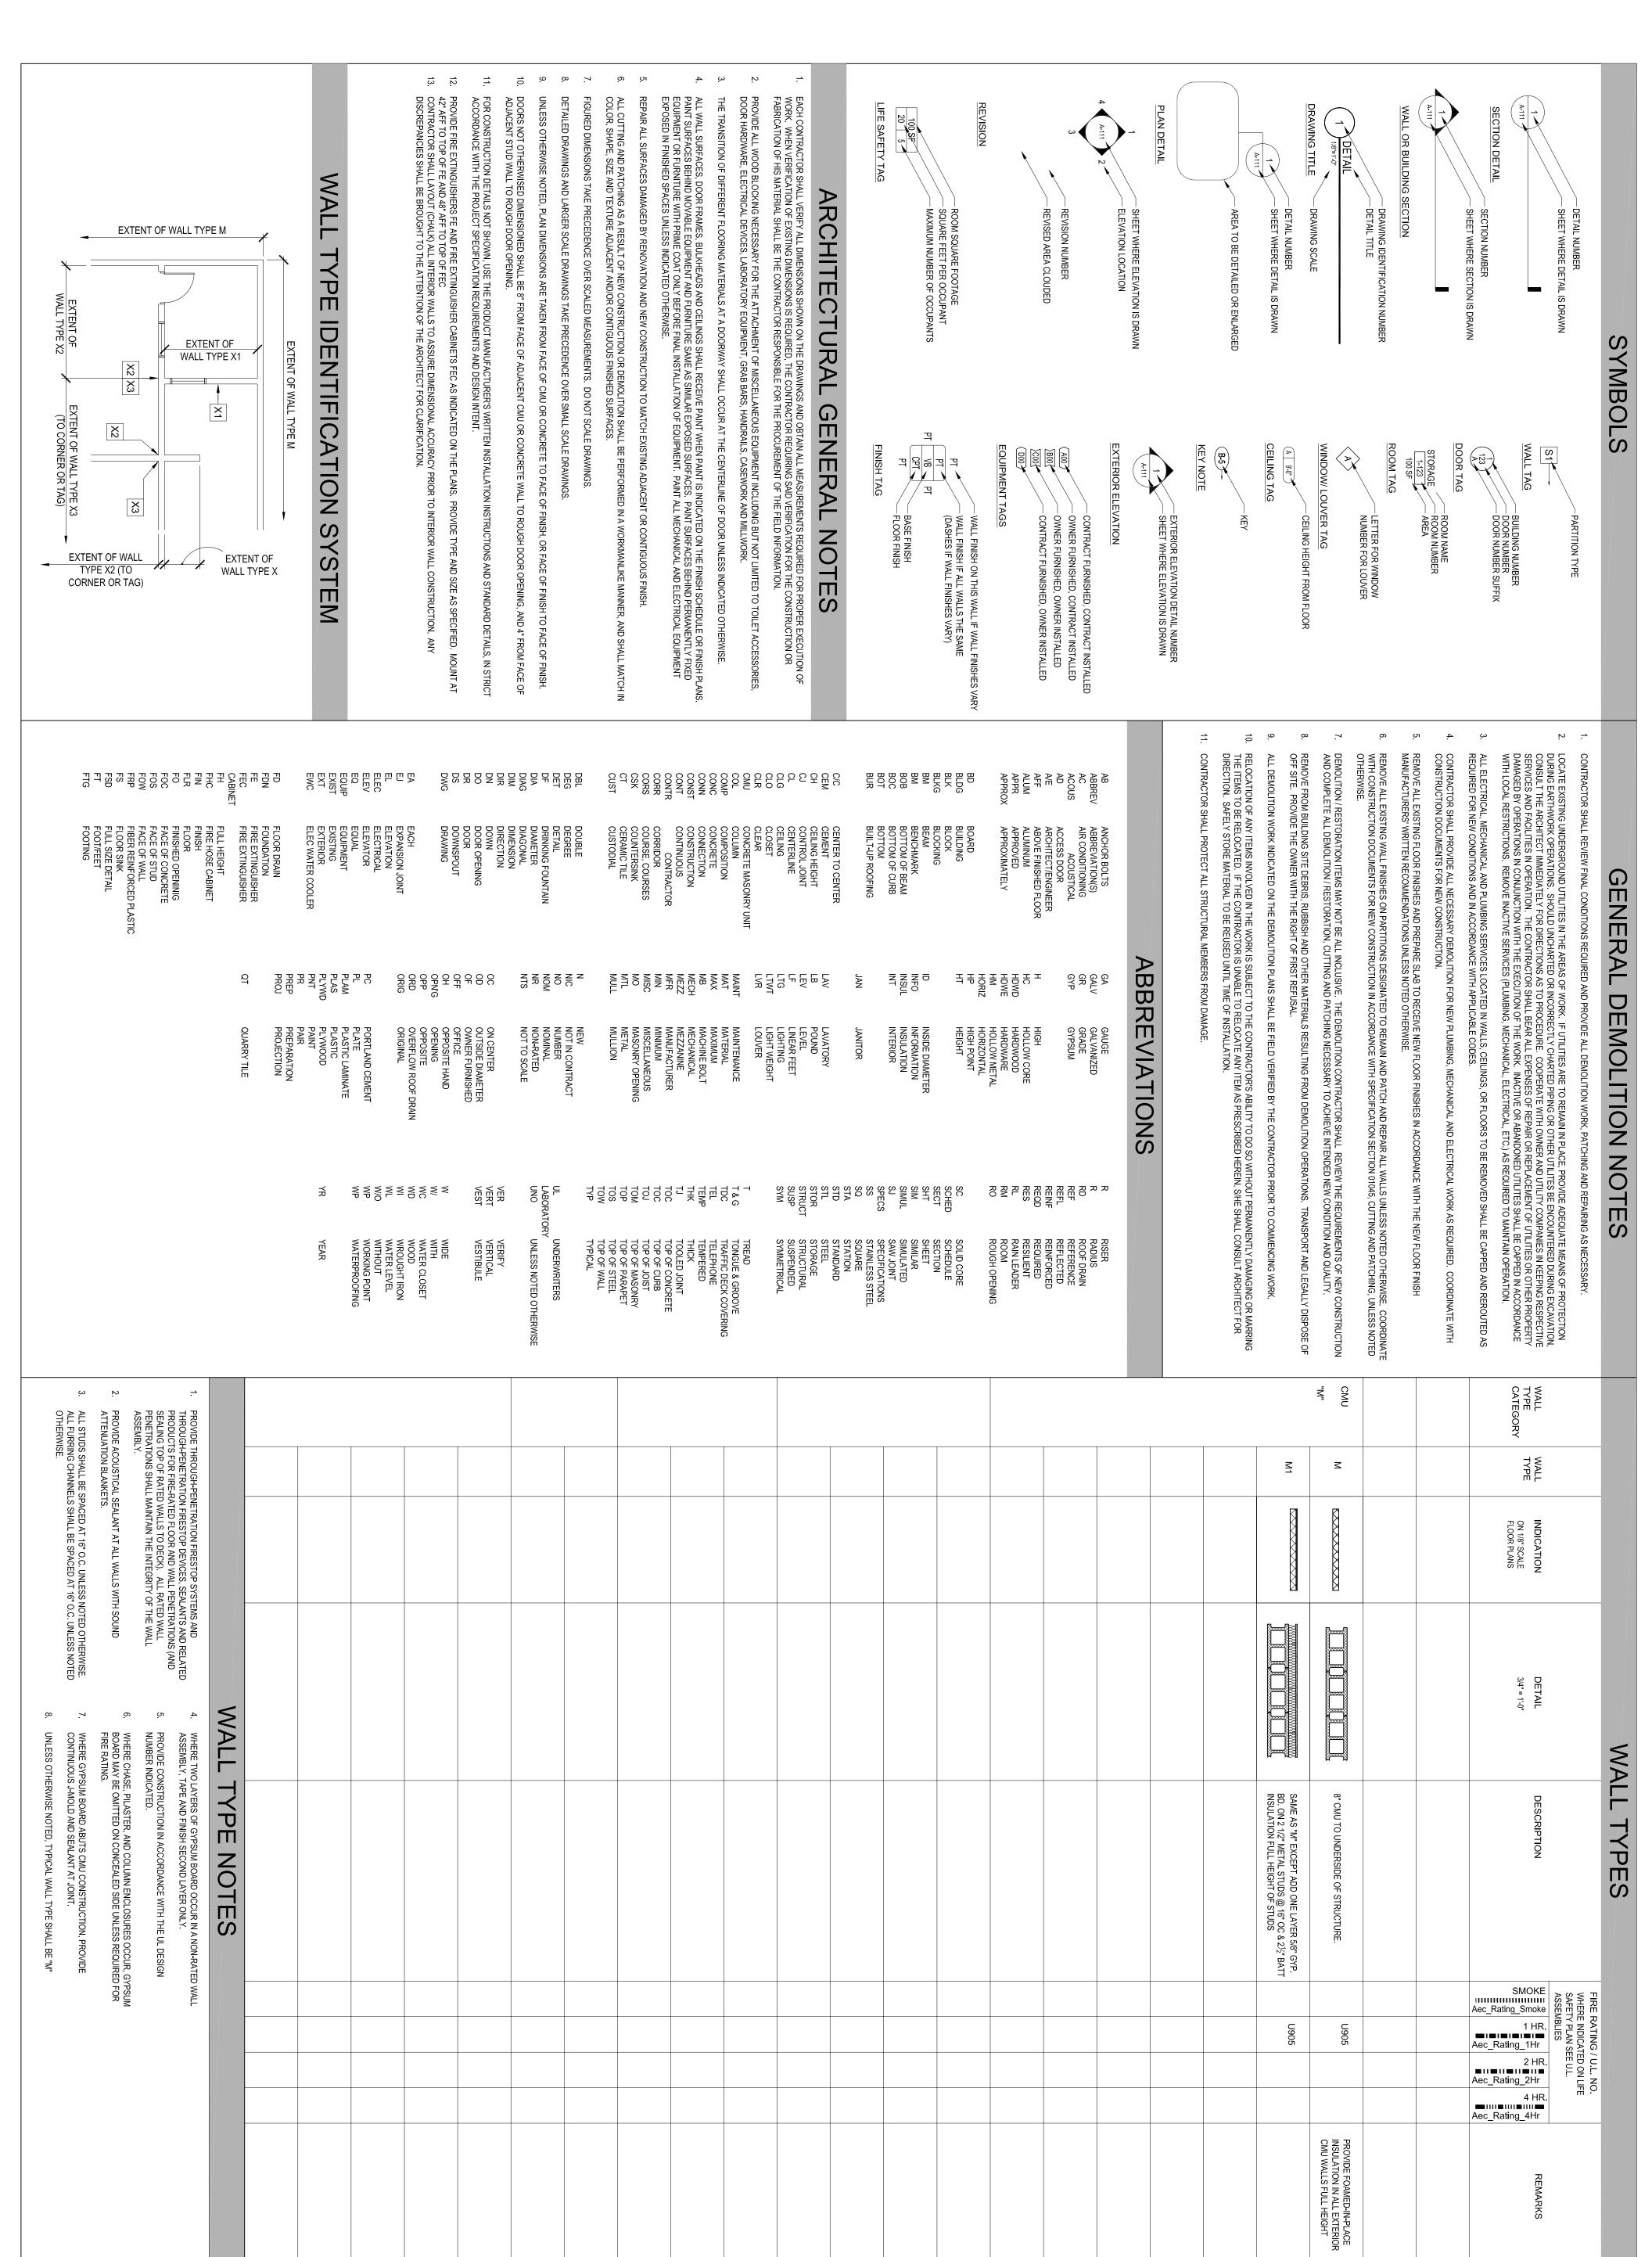

100% Construction Documents

SCHENKELSHULTZ

677 North Washington Blvd.
Sarasota, Fl 34236
voice 941.952.5875
fax 941.957.3630
schenkelshultz.com
SS Lic No - AA-C000937

REMARKS

DRAŽEN AHMEDIĆ


Bradenton Downtown 601 13th Street West Bradenton, FI 34205 Transit Station

Manatee County Government 1112 Manatee Ave West 8th Floor Bradenton, FI 34208

drawn: checked: date: 11.12.10
comm. no.: 0920818

INFORMATION SHEET

ARCHITECTURAL

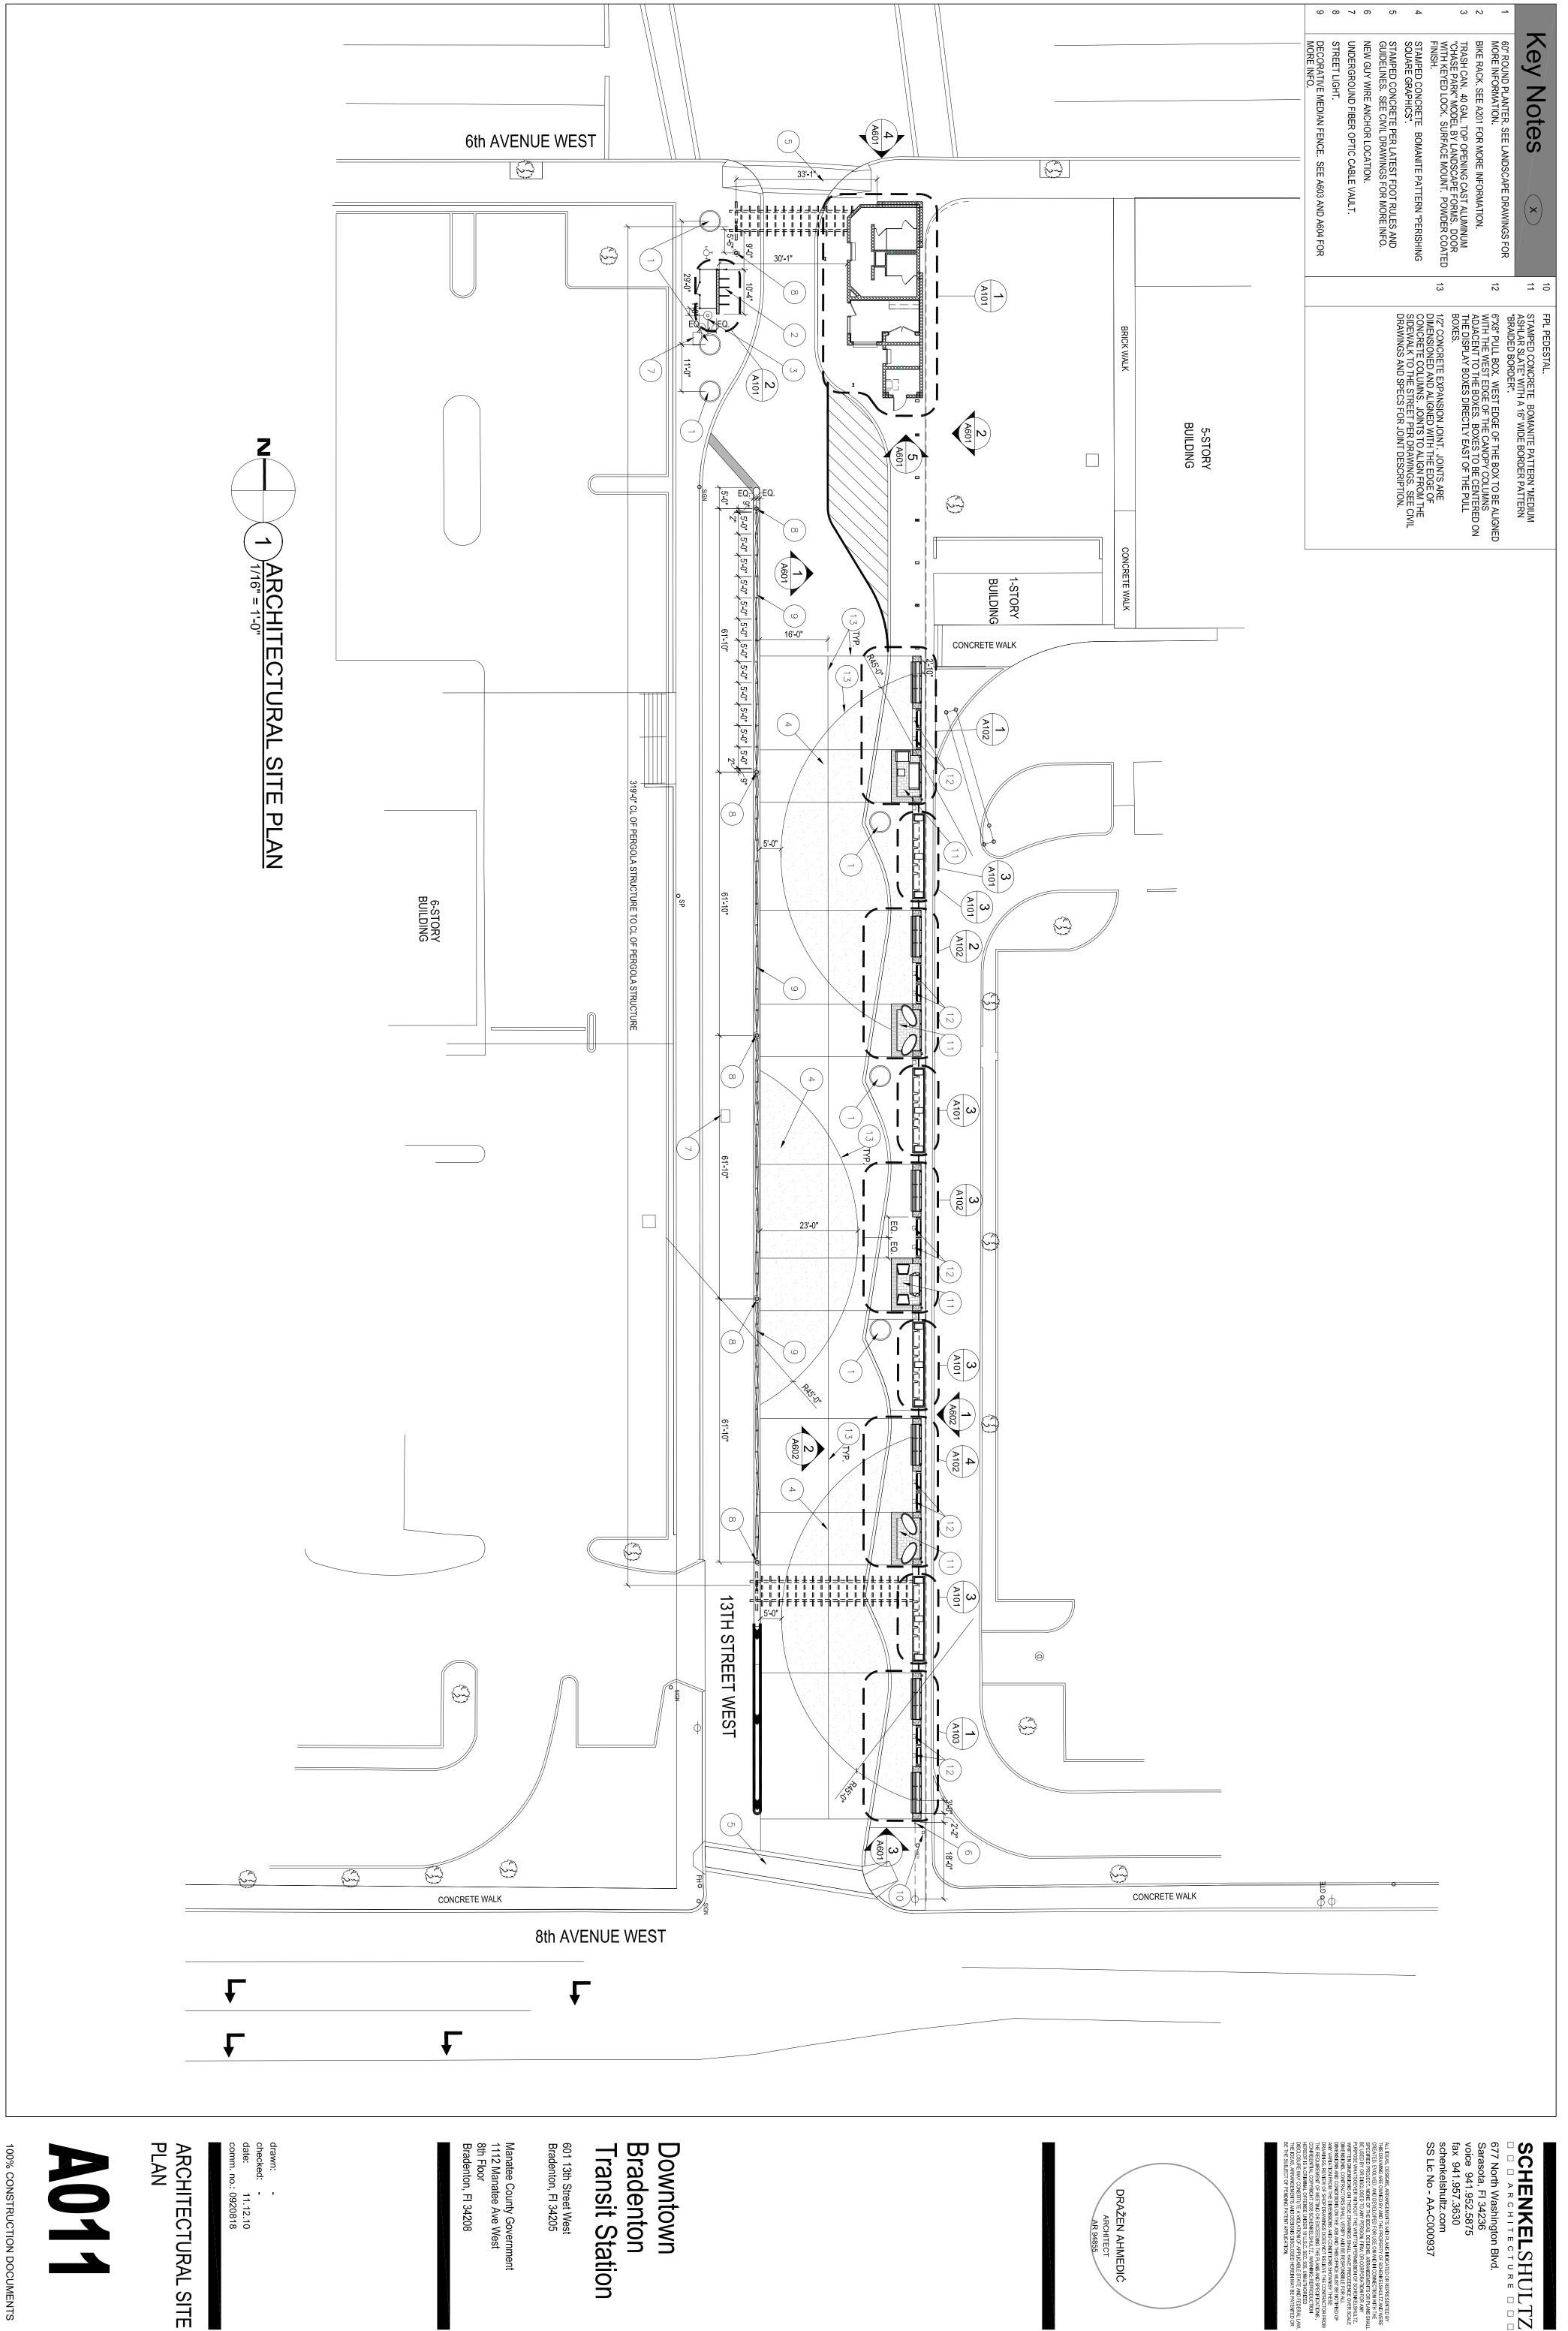



drawn: checked: date: 11.12.10
comm. no.: 0920818


Manatee County Government 1112 Manatee Ave West 8th Floor Bradenton, FI 34208



677 North Washington Blvd.
Sarasota, Fl 34236
voice 941.952.5875
fax 941.957.3630
schenkelshultz.com
SS Lic No - AA-C000937

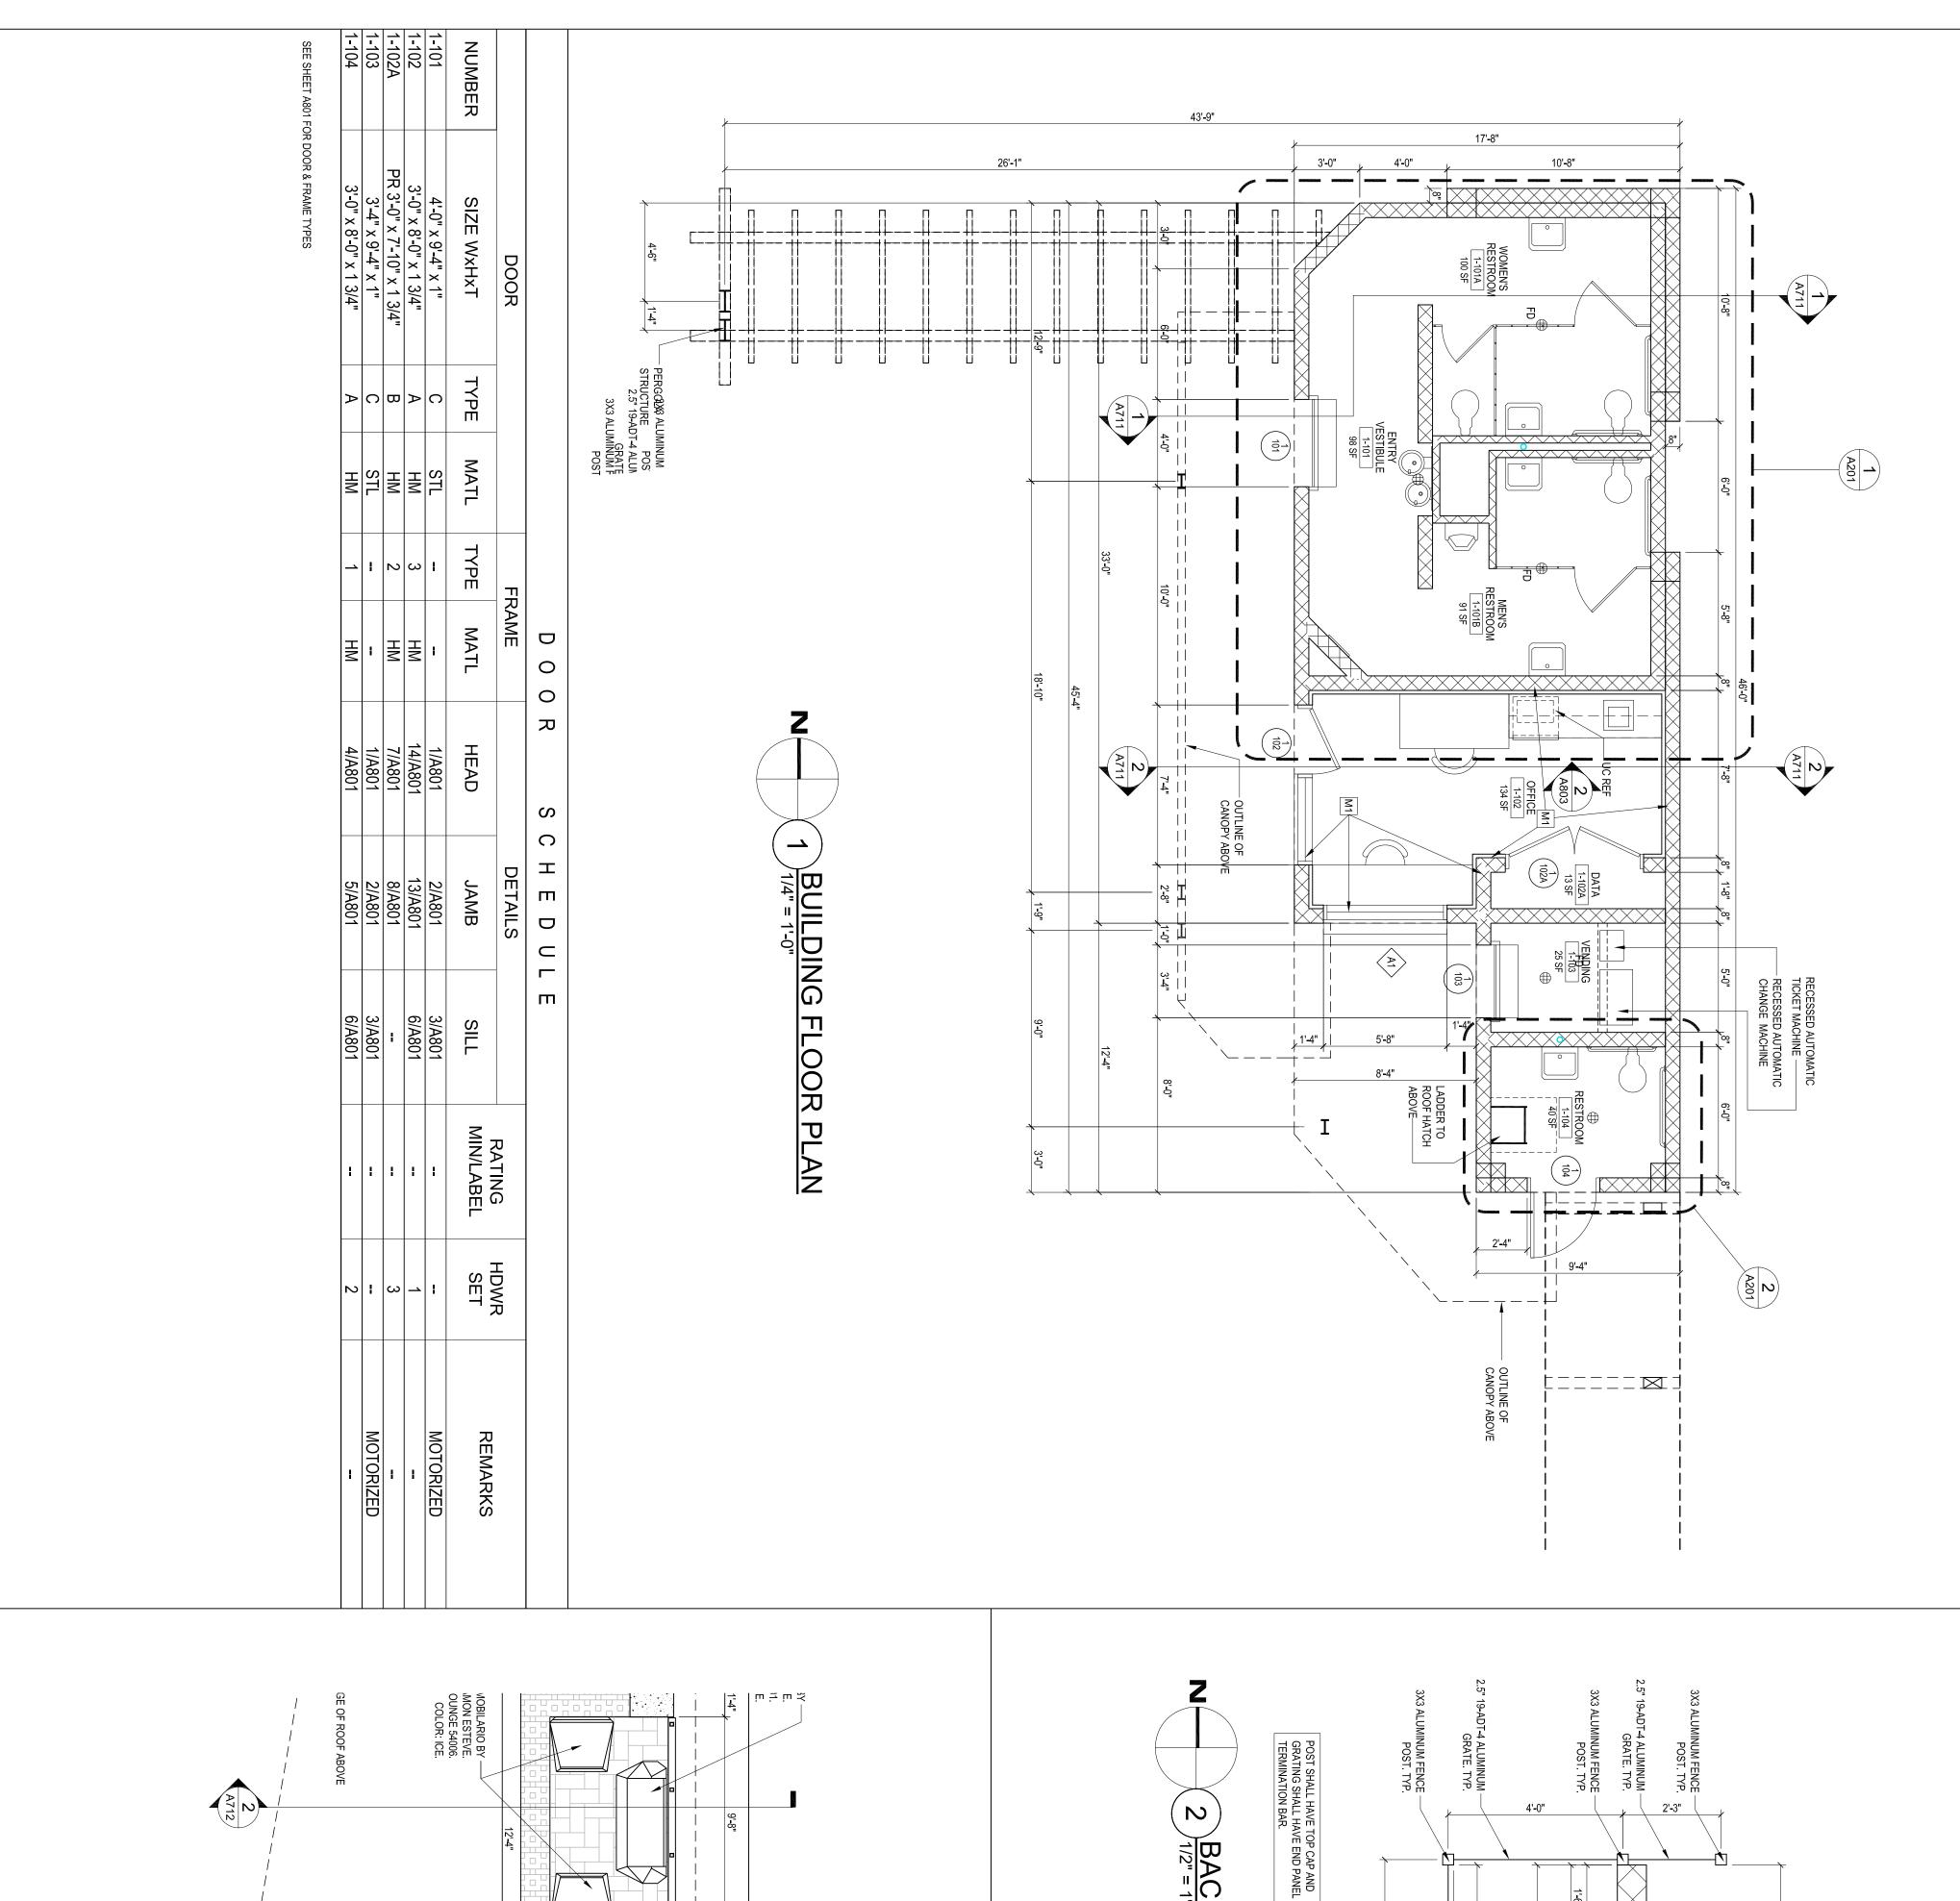

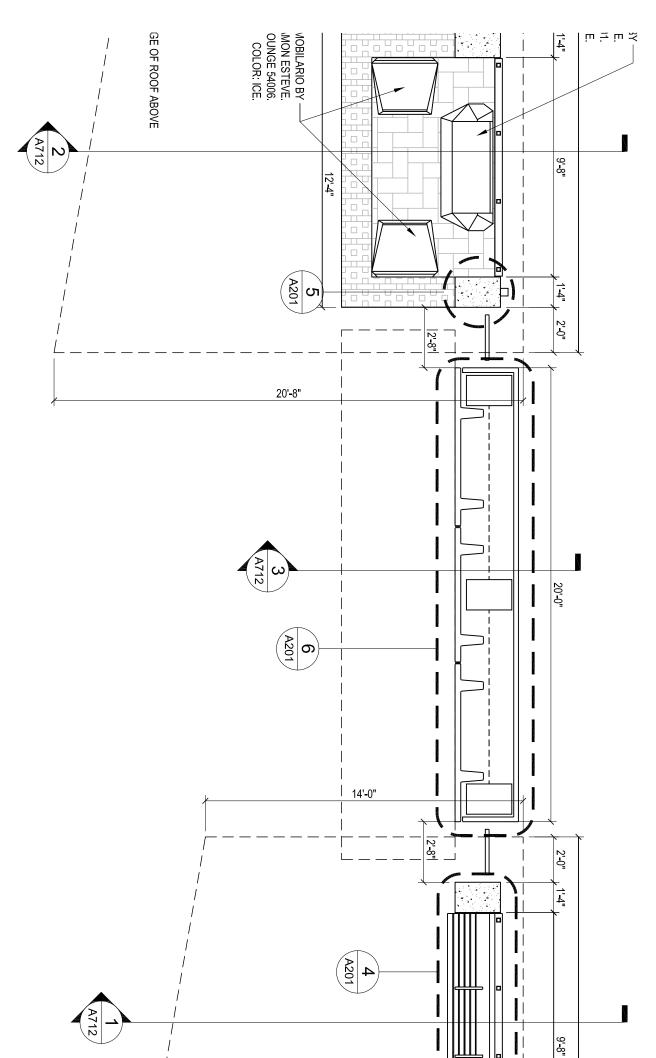

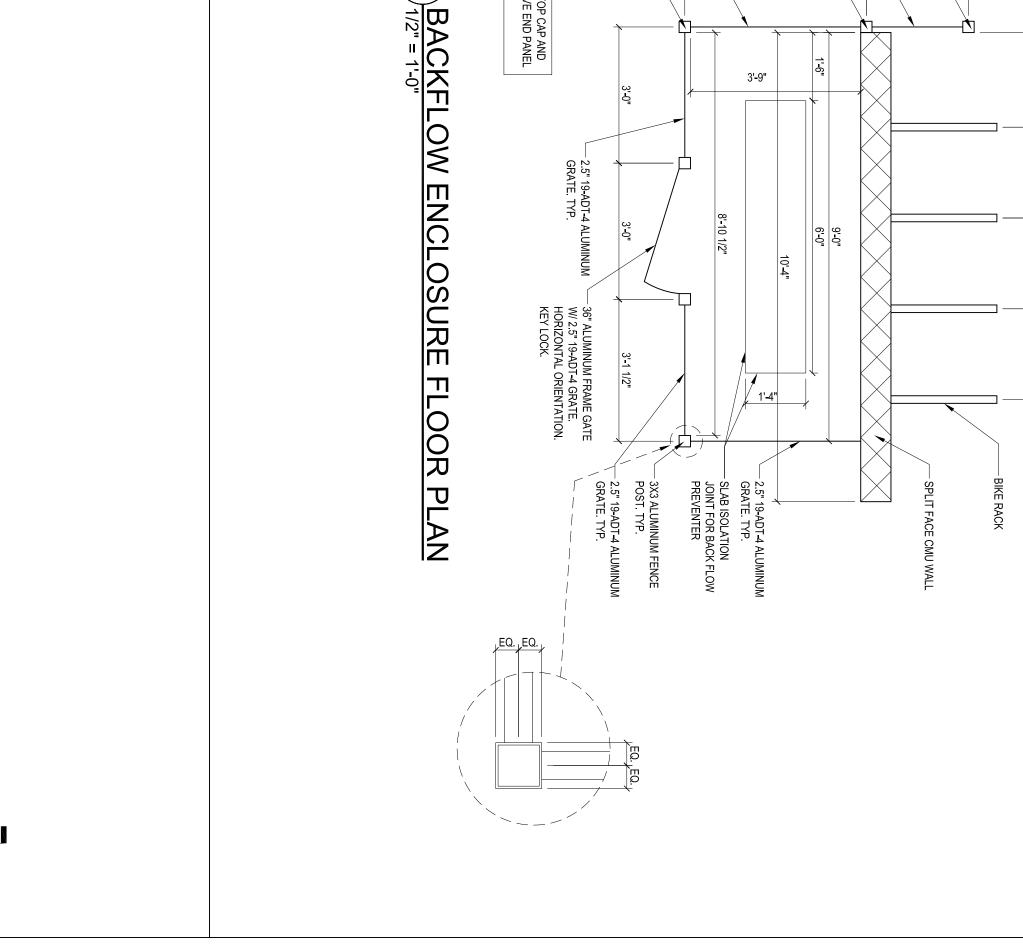



3'-9"

6-0"

677 North Washington Blvd.
Sarasota, Fl 34236
voice 941.952.5875
fax 941.957.3630
schenkelshultz.com
SS Lic No - AA-C000937

SCHENKELSHULTZ

8'-10 1/2"

Downtown

Bradenton Transit Station

601 13th Street West Bradenton, FI 34205

Manatee County Government 1112 Manatee Ave West 8th Floor Bradenton, FI 34208


drawn: da
checked: da
date: 11.12.2010
comm. no.: 0920818


**FLOOR PLAN** 

Z


ယ

TYPICAL ART WALL FLOOR PLAN

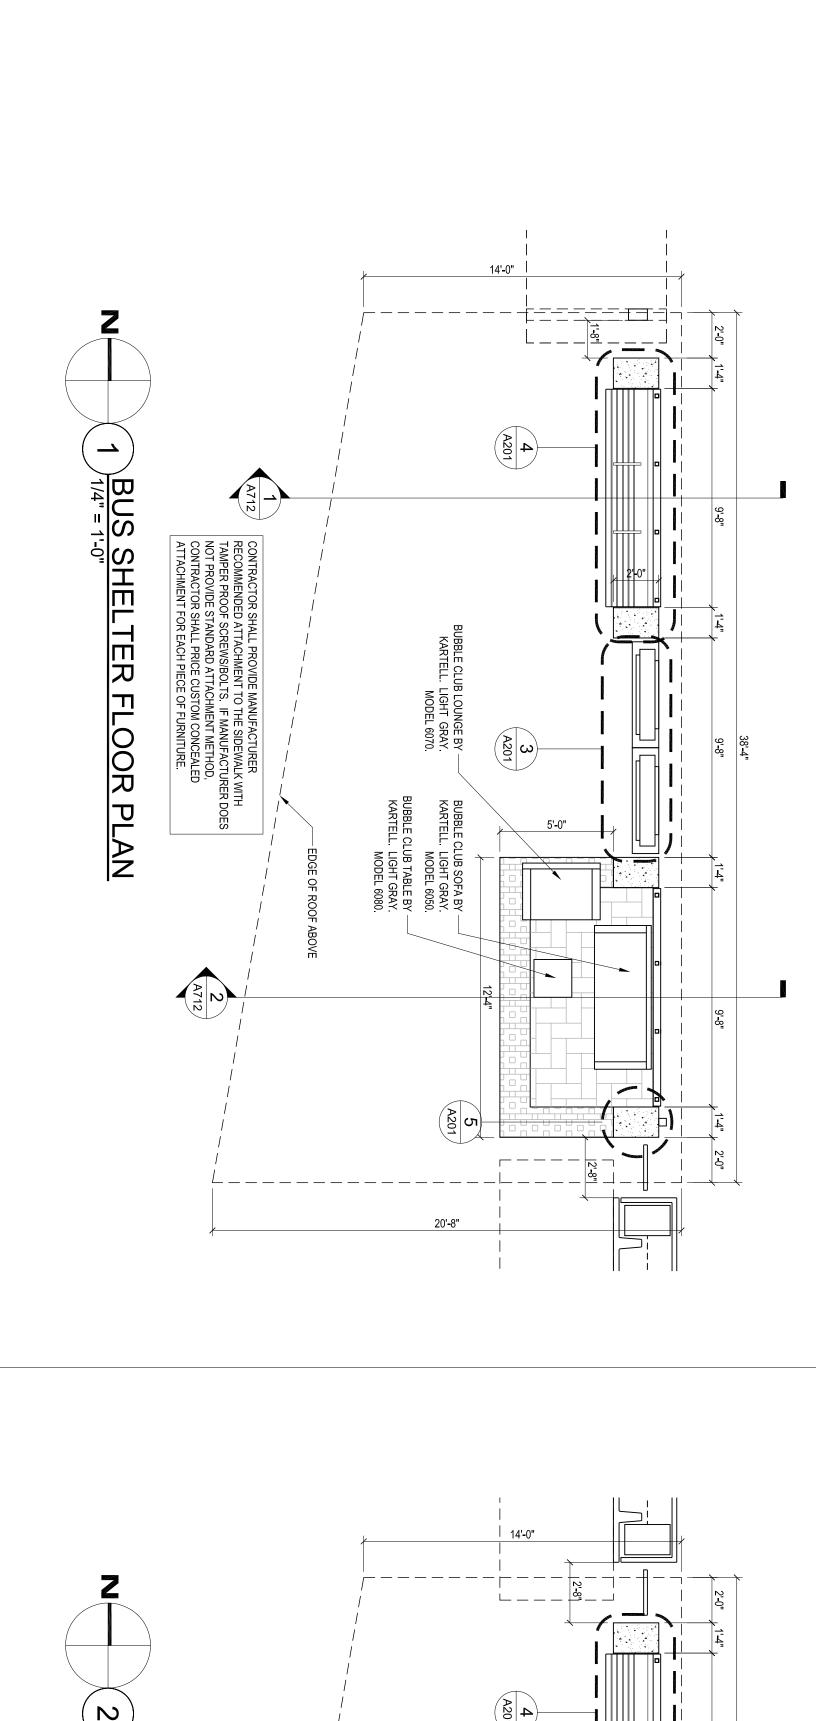

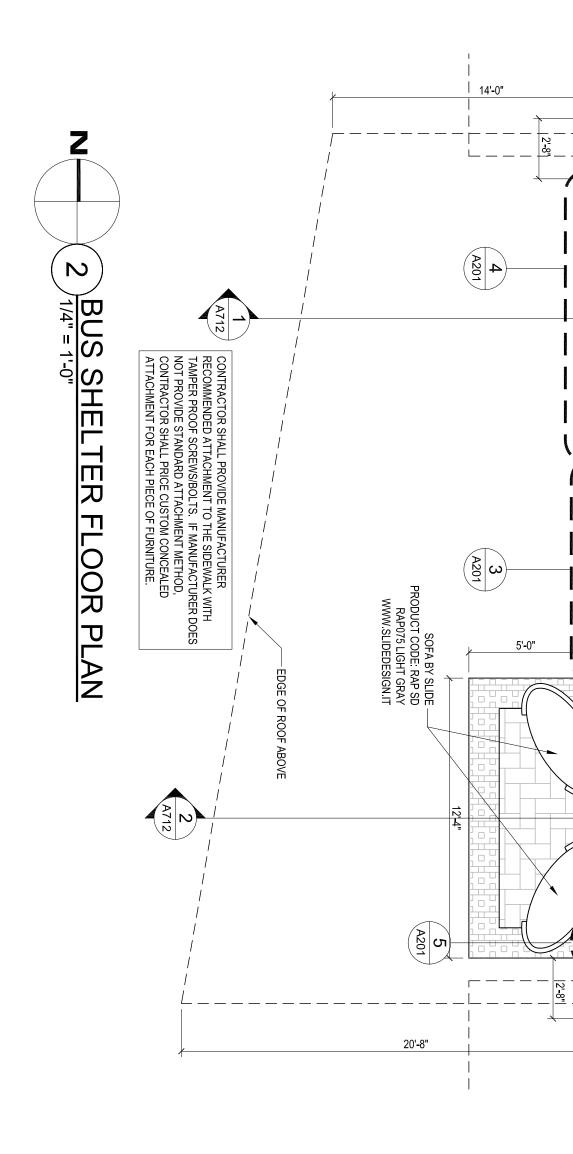

DRAŽEN AHMEDIĆ ARCHITECT AR 94855

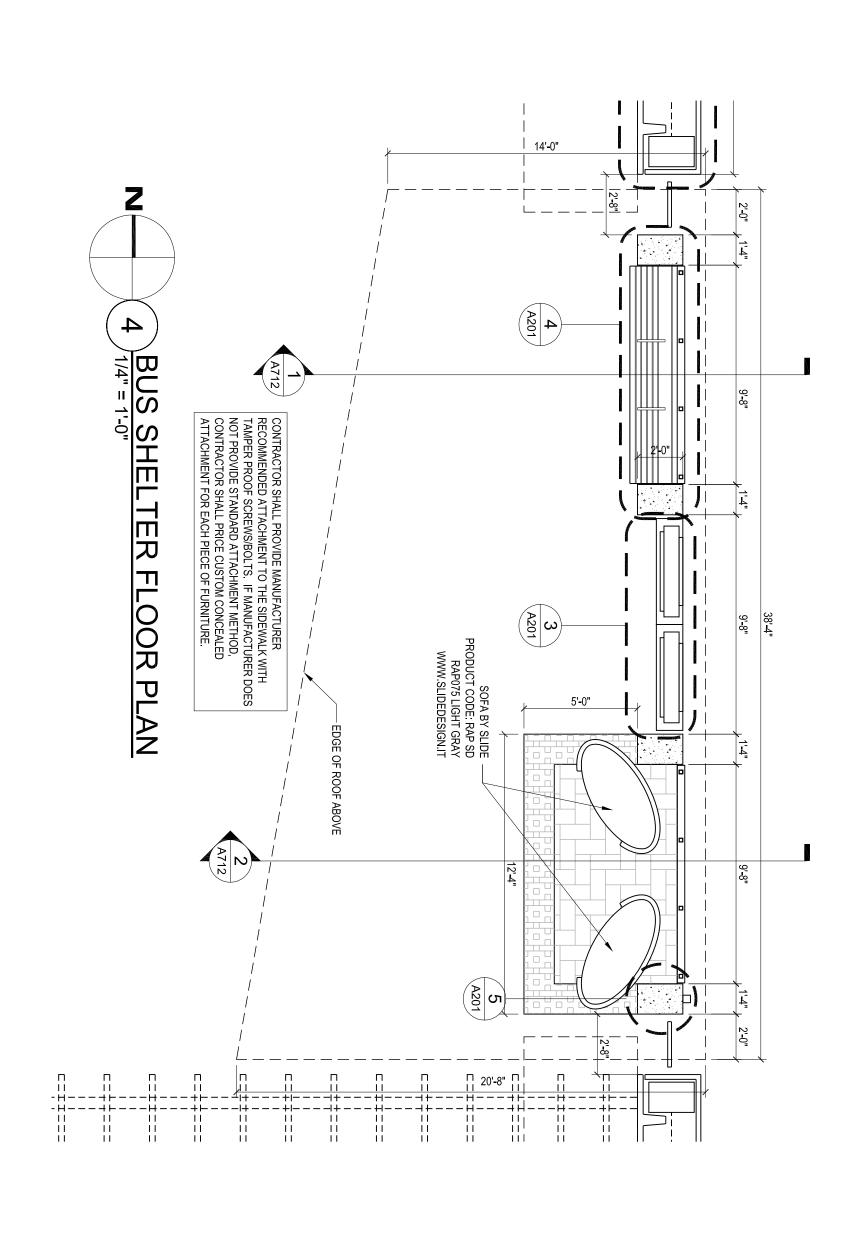

14'-0"


FAZ MOBILARIO BY -RAMON ESTEVE. VONDOM DESIGN. WWW.VONDOM.COM LOUNGE 54006. COLOR: ICE.

A201

EDGE OF ROOF ABOVE

ယ

BUS SHELTER FLOOR PLAN

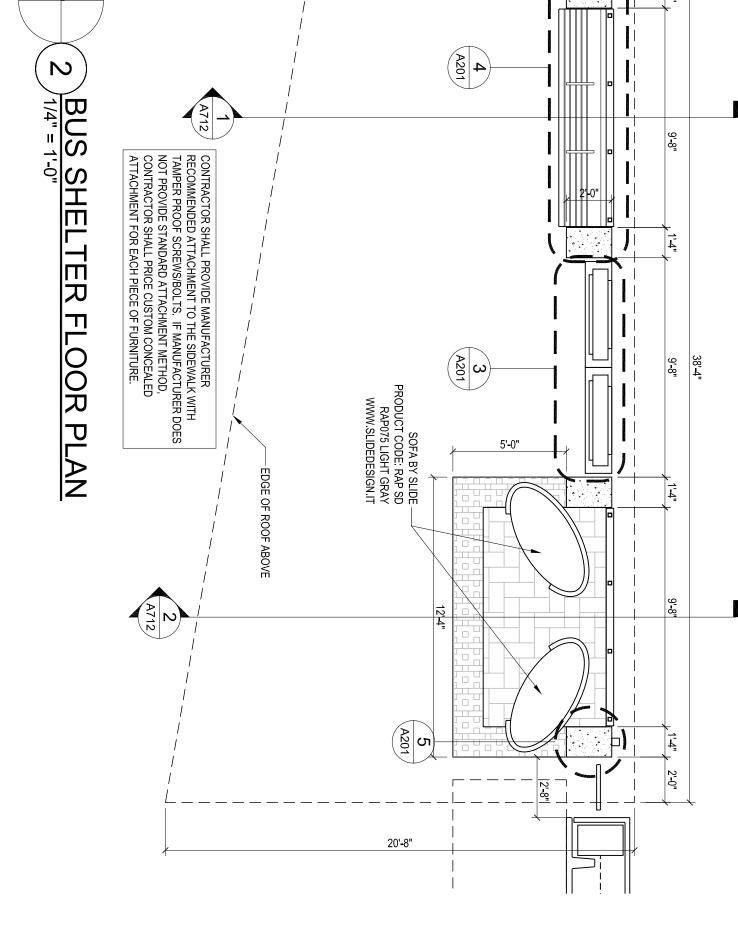

677 North Washington Blvd.
Sarasota, Fl 34236
voice 941.952.5875
fax 941.957.3630
schenkelshultz.com
SS Lic No - AA-C000937

SCHENKELSHULTZ

Bradenton Downtown Transit Station


601 13th Street West Bradenton, FI 34205

Manatee County Government 1112 Manatee Ave West 8th Floor Bradenton, FI 34208

drawn: checked: date: 11.12.10
comm. no.: 0920818

FLOOR PLAN

100% Construction Documents

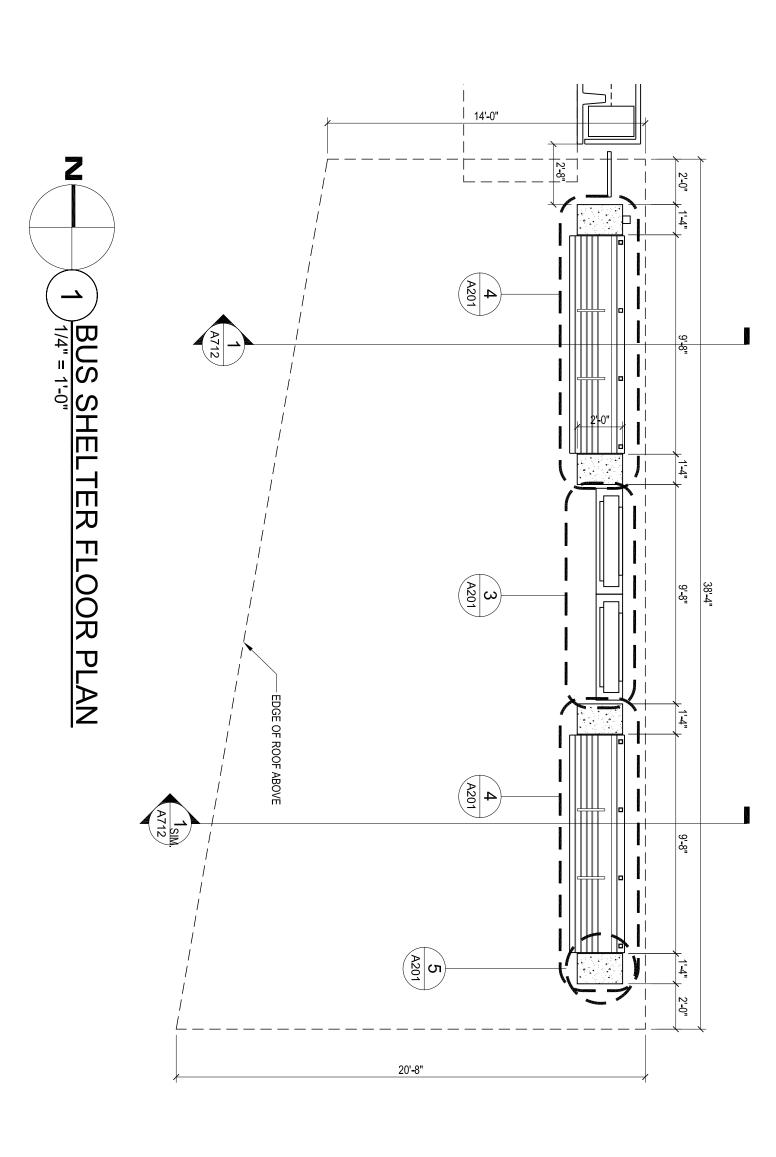

#### Downtown Bradenton Transit Station

601 13th Street West Bradenton, FI 34205

Manatee County Government 1112 Manatee Ave West 8th Floor Bradenton, FI 34208


drawn: checked: date: 11.12.10
comm. no.: 0920818


FLOOR PLAN


**A103** 

100% Construction Documents

DRAŽEN AHMEDIĆ ARCHITECT AR 94855

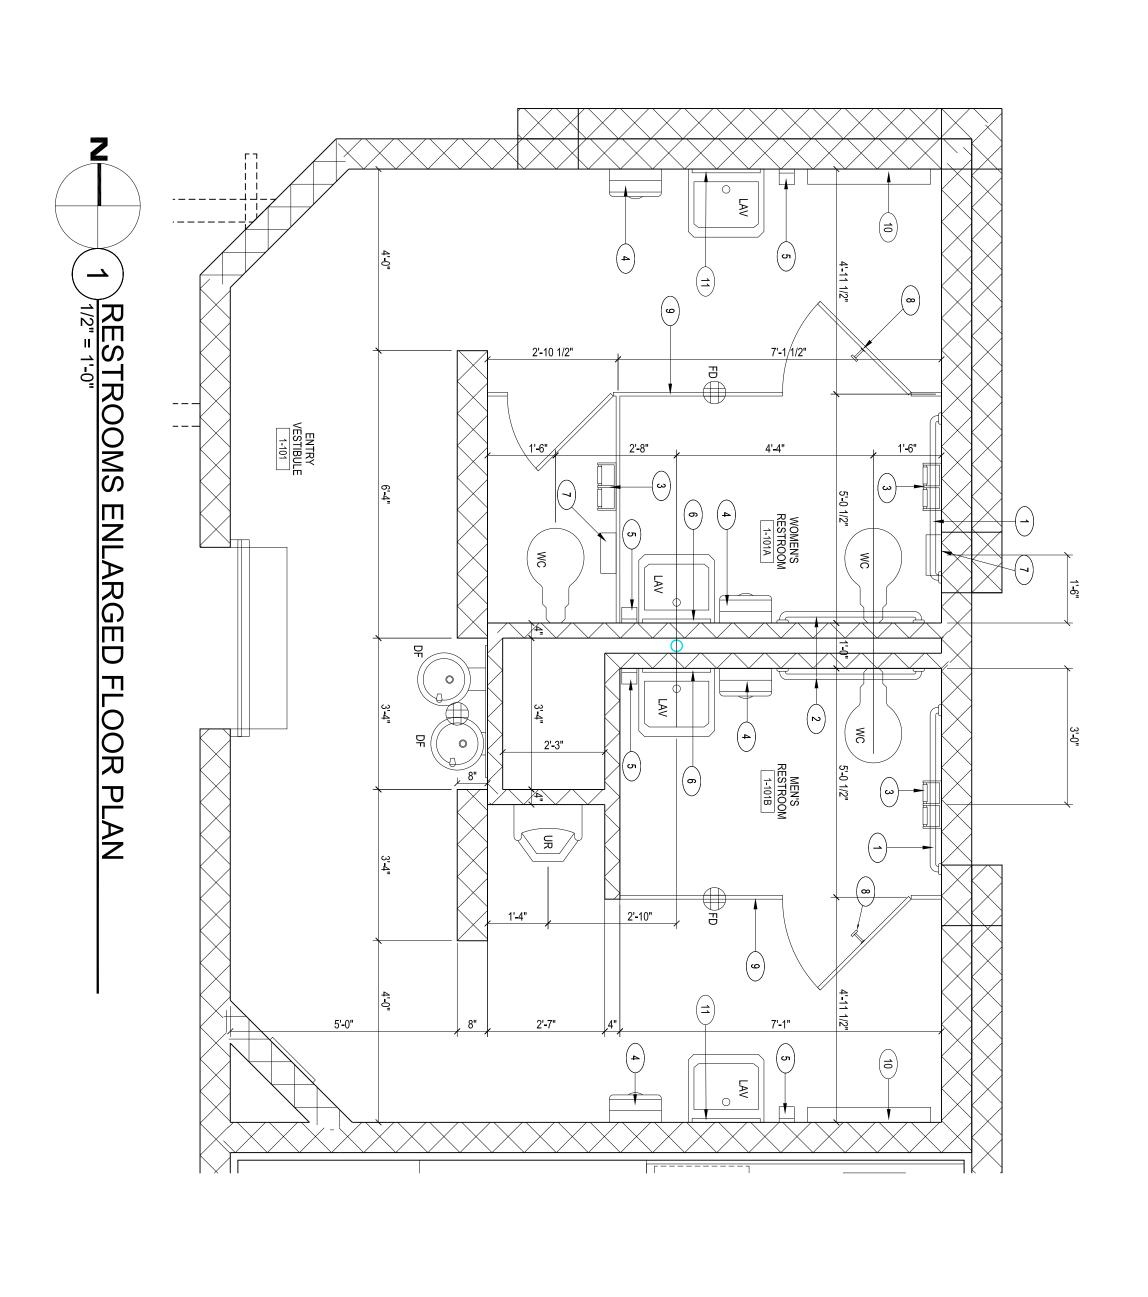


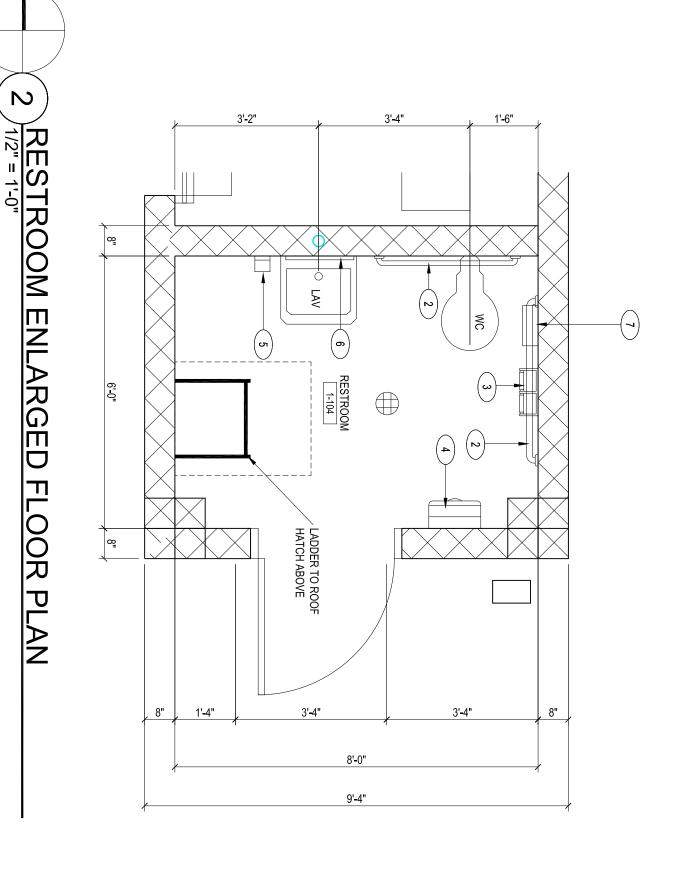

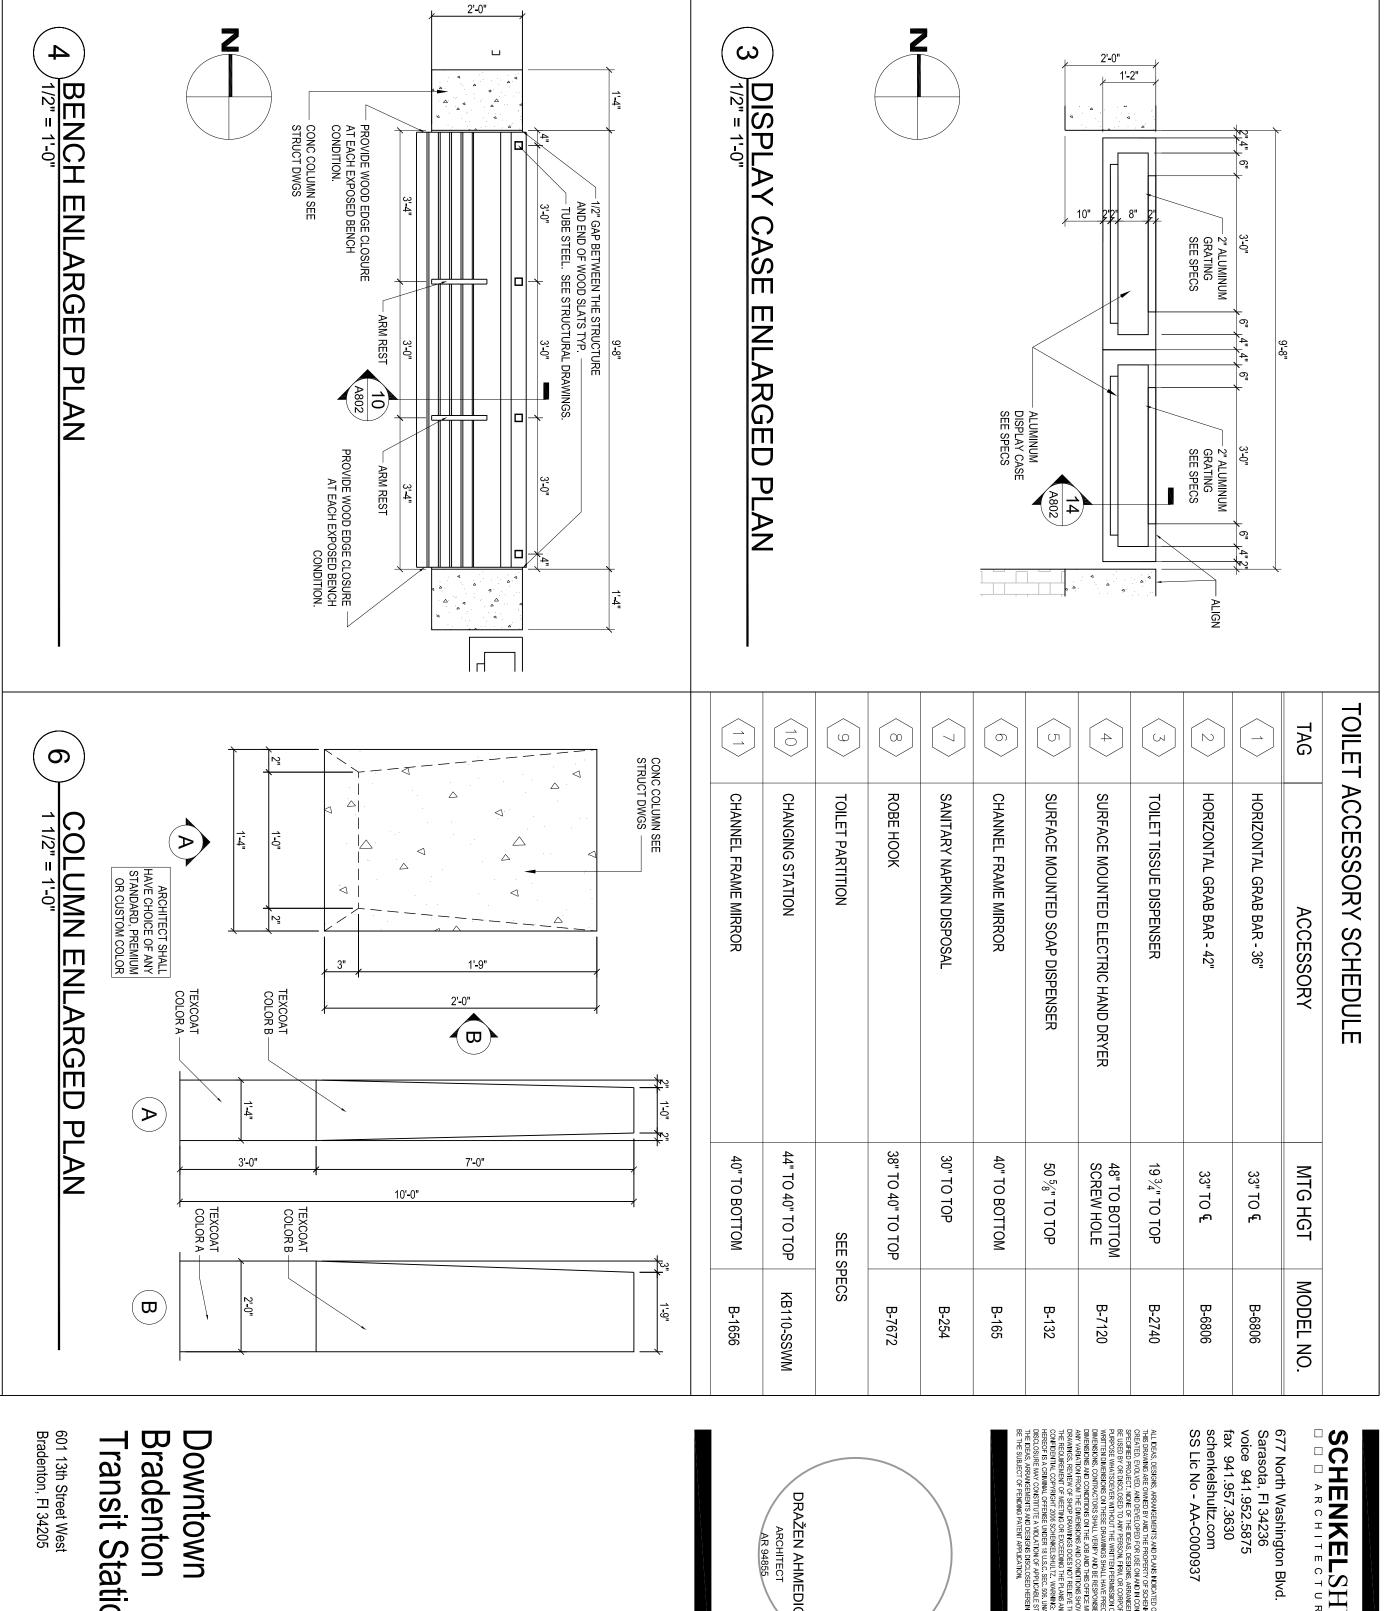

DRAŽEN AHMEDIĆ ARCHITECT AR 94855

SCHENKELSHULTZ

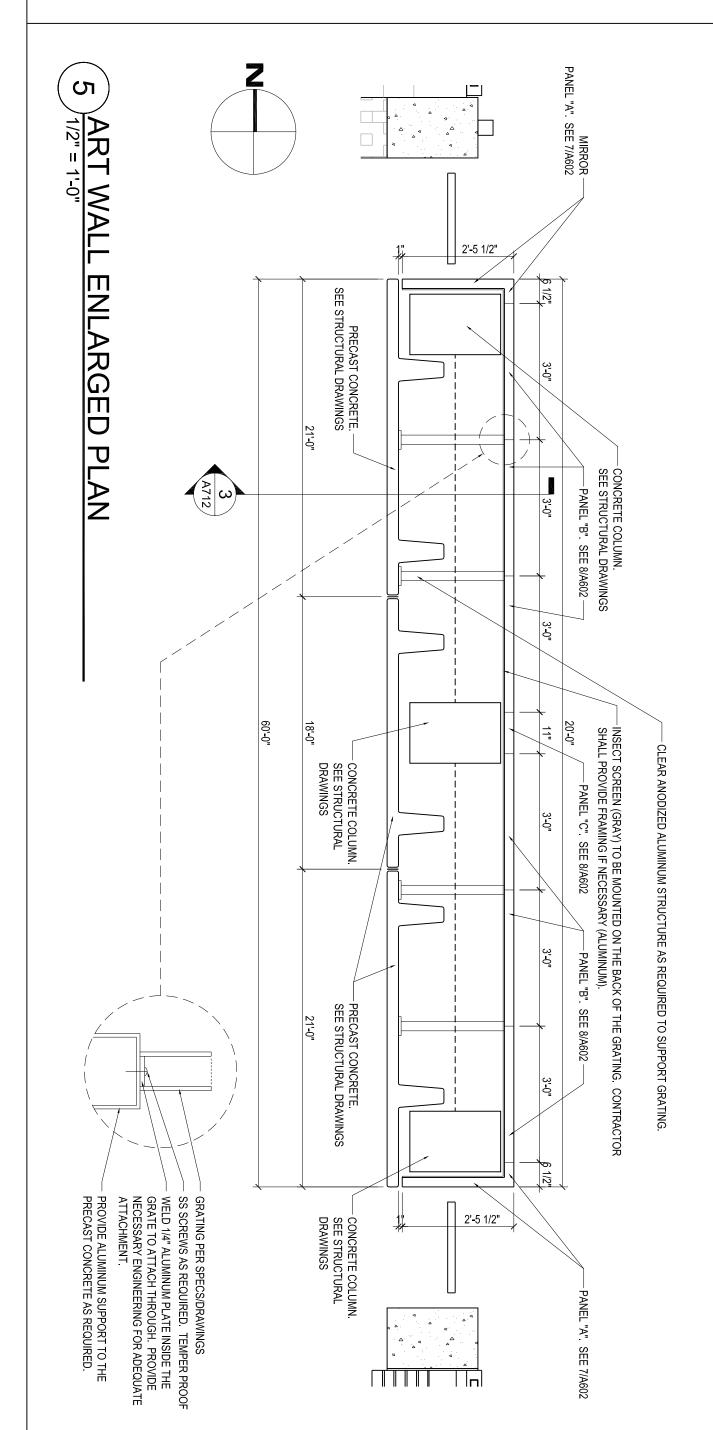

Manatee County Government 1112 Manatee Ave West 8th Floor Bradenton, FI 34208


Downtown


Transit Station

drawn: checked: date: 11.12.10
comm. no.: 0920818

**ENLARGED PLANS** 

100% Construction Documents

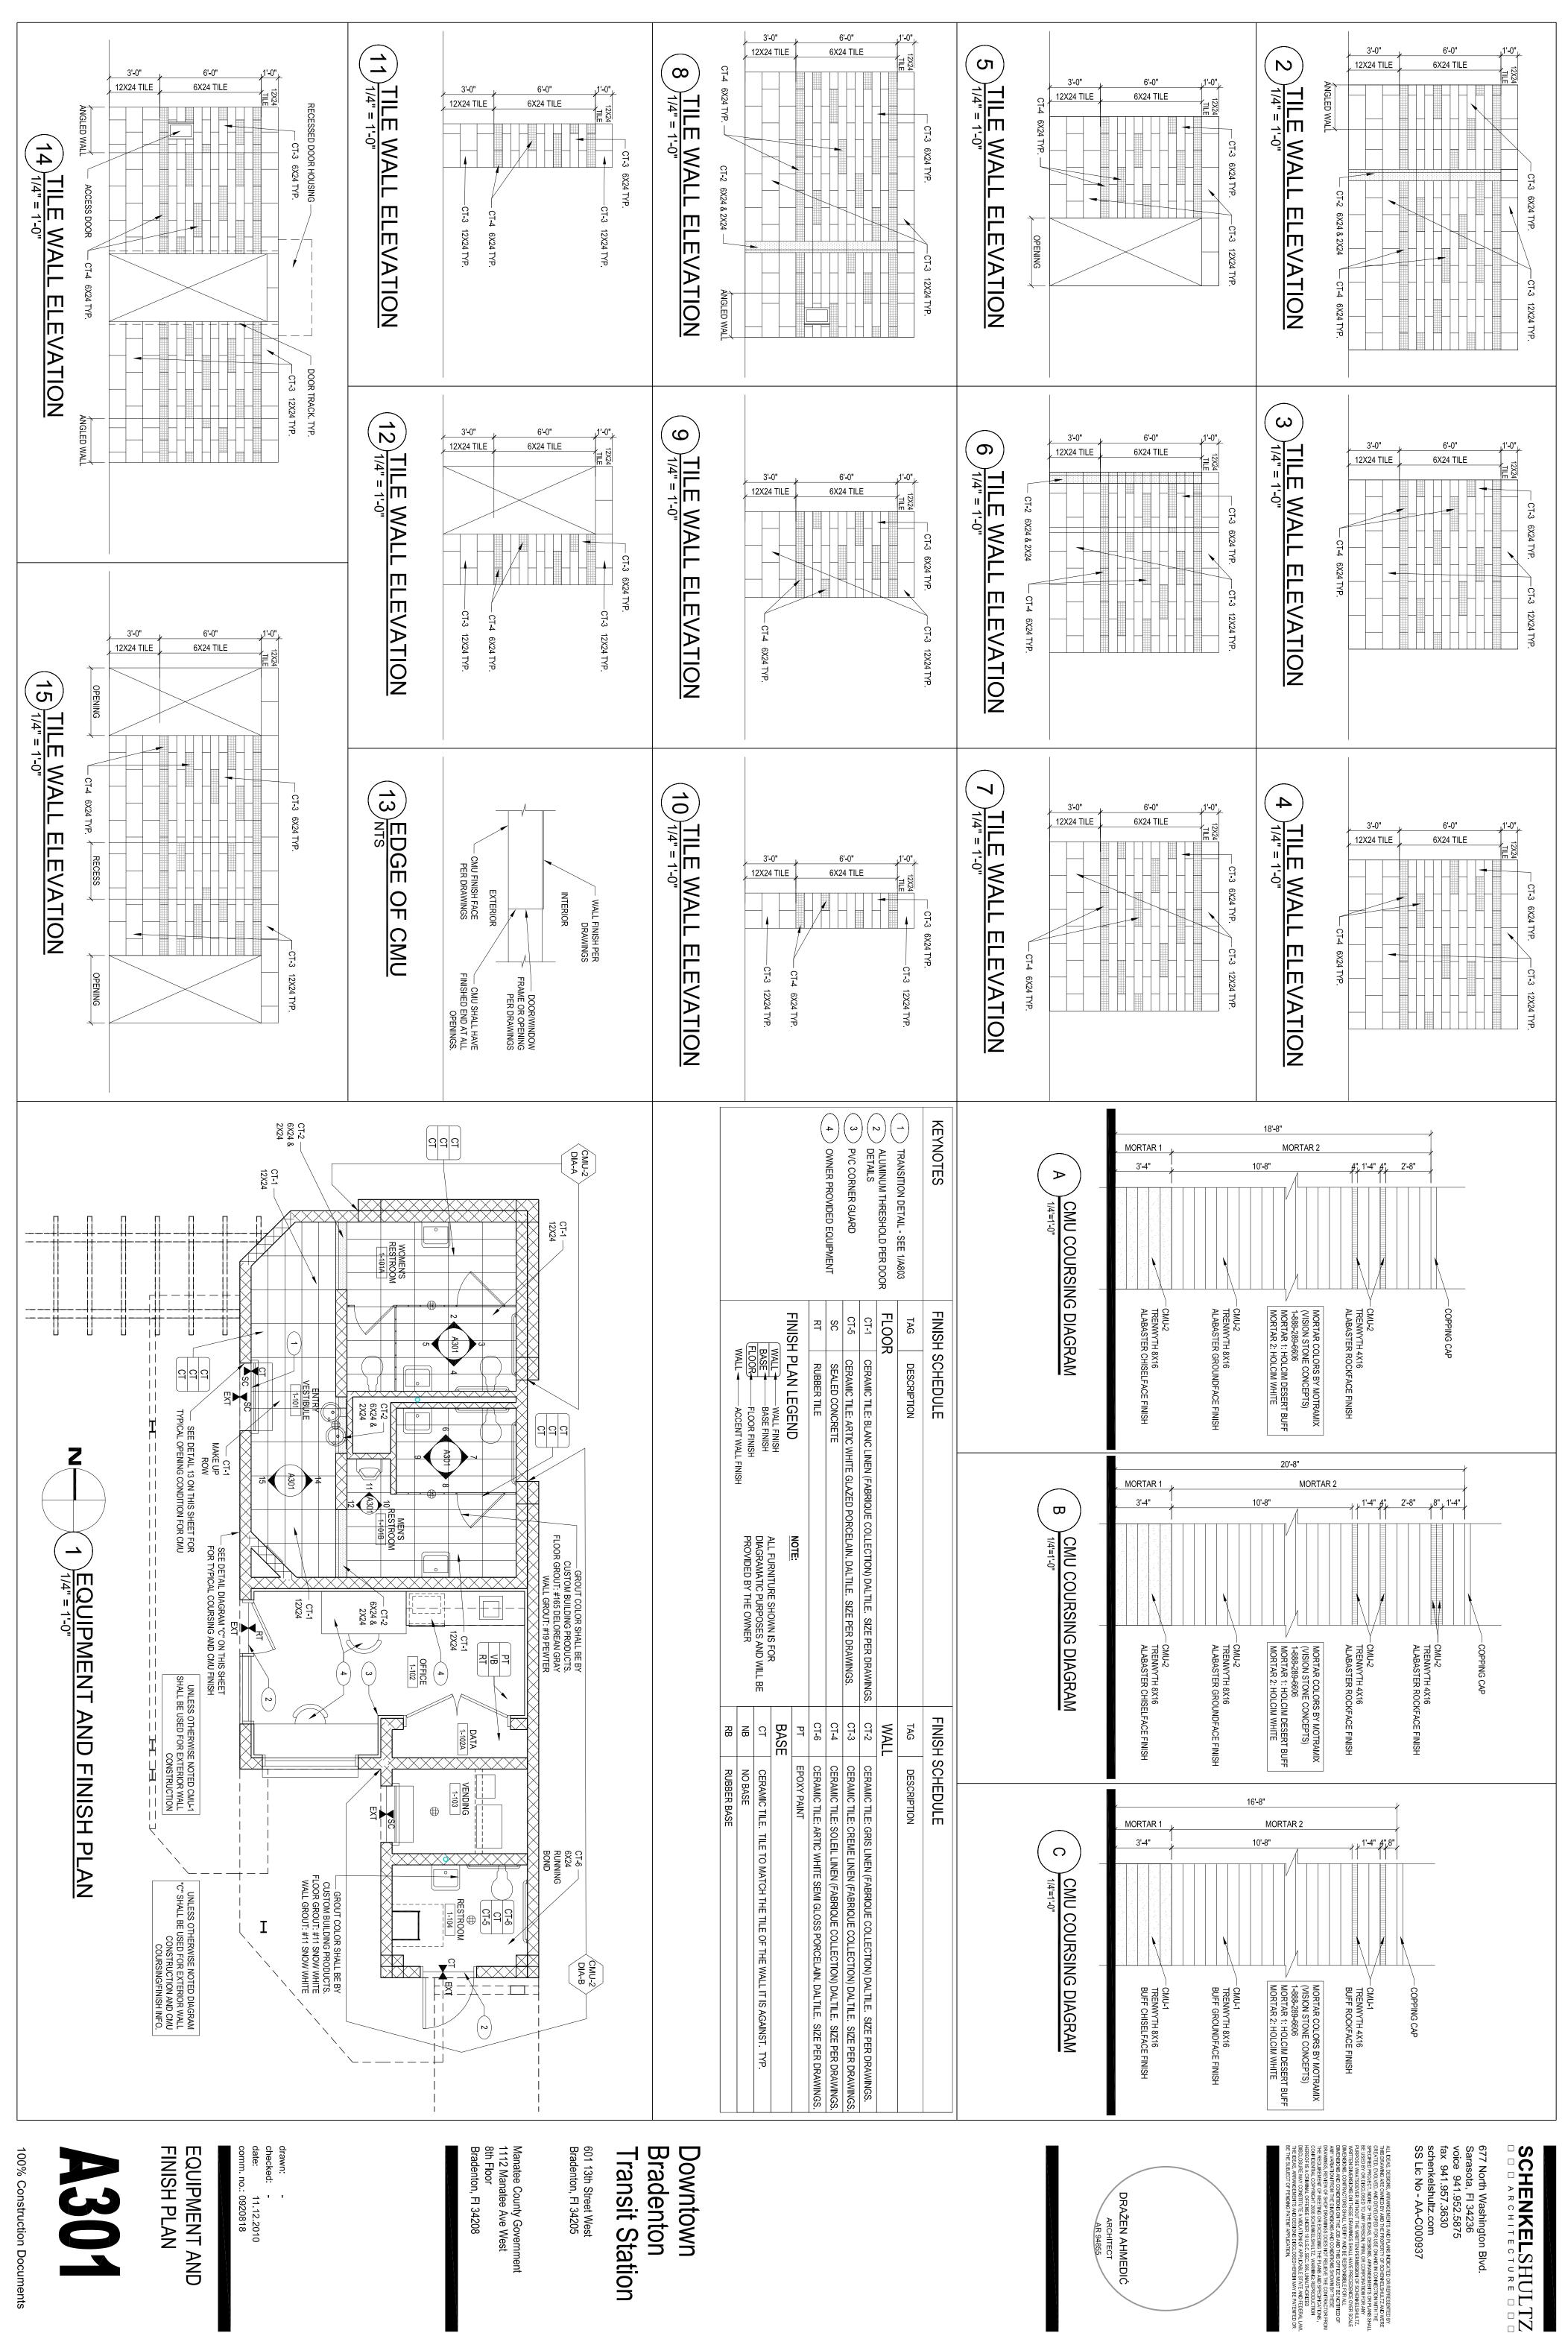

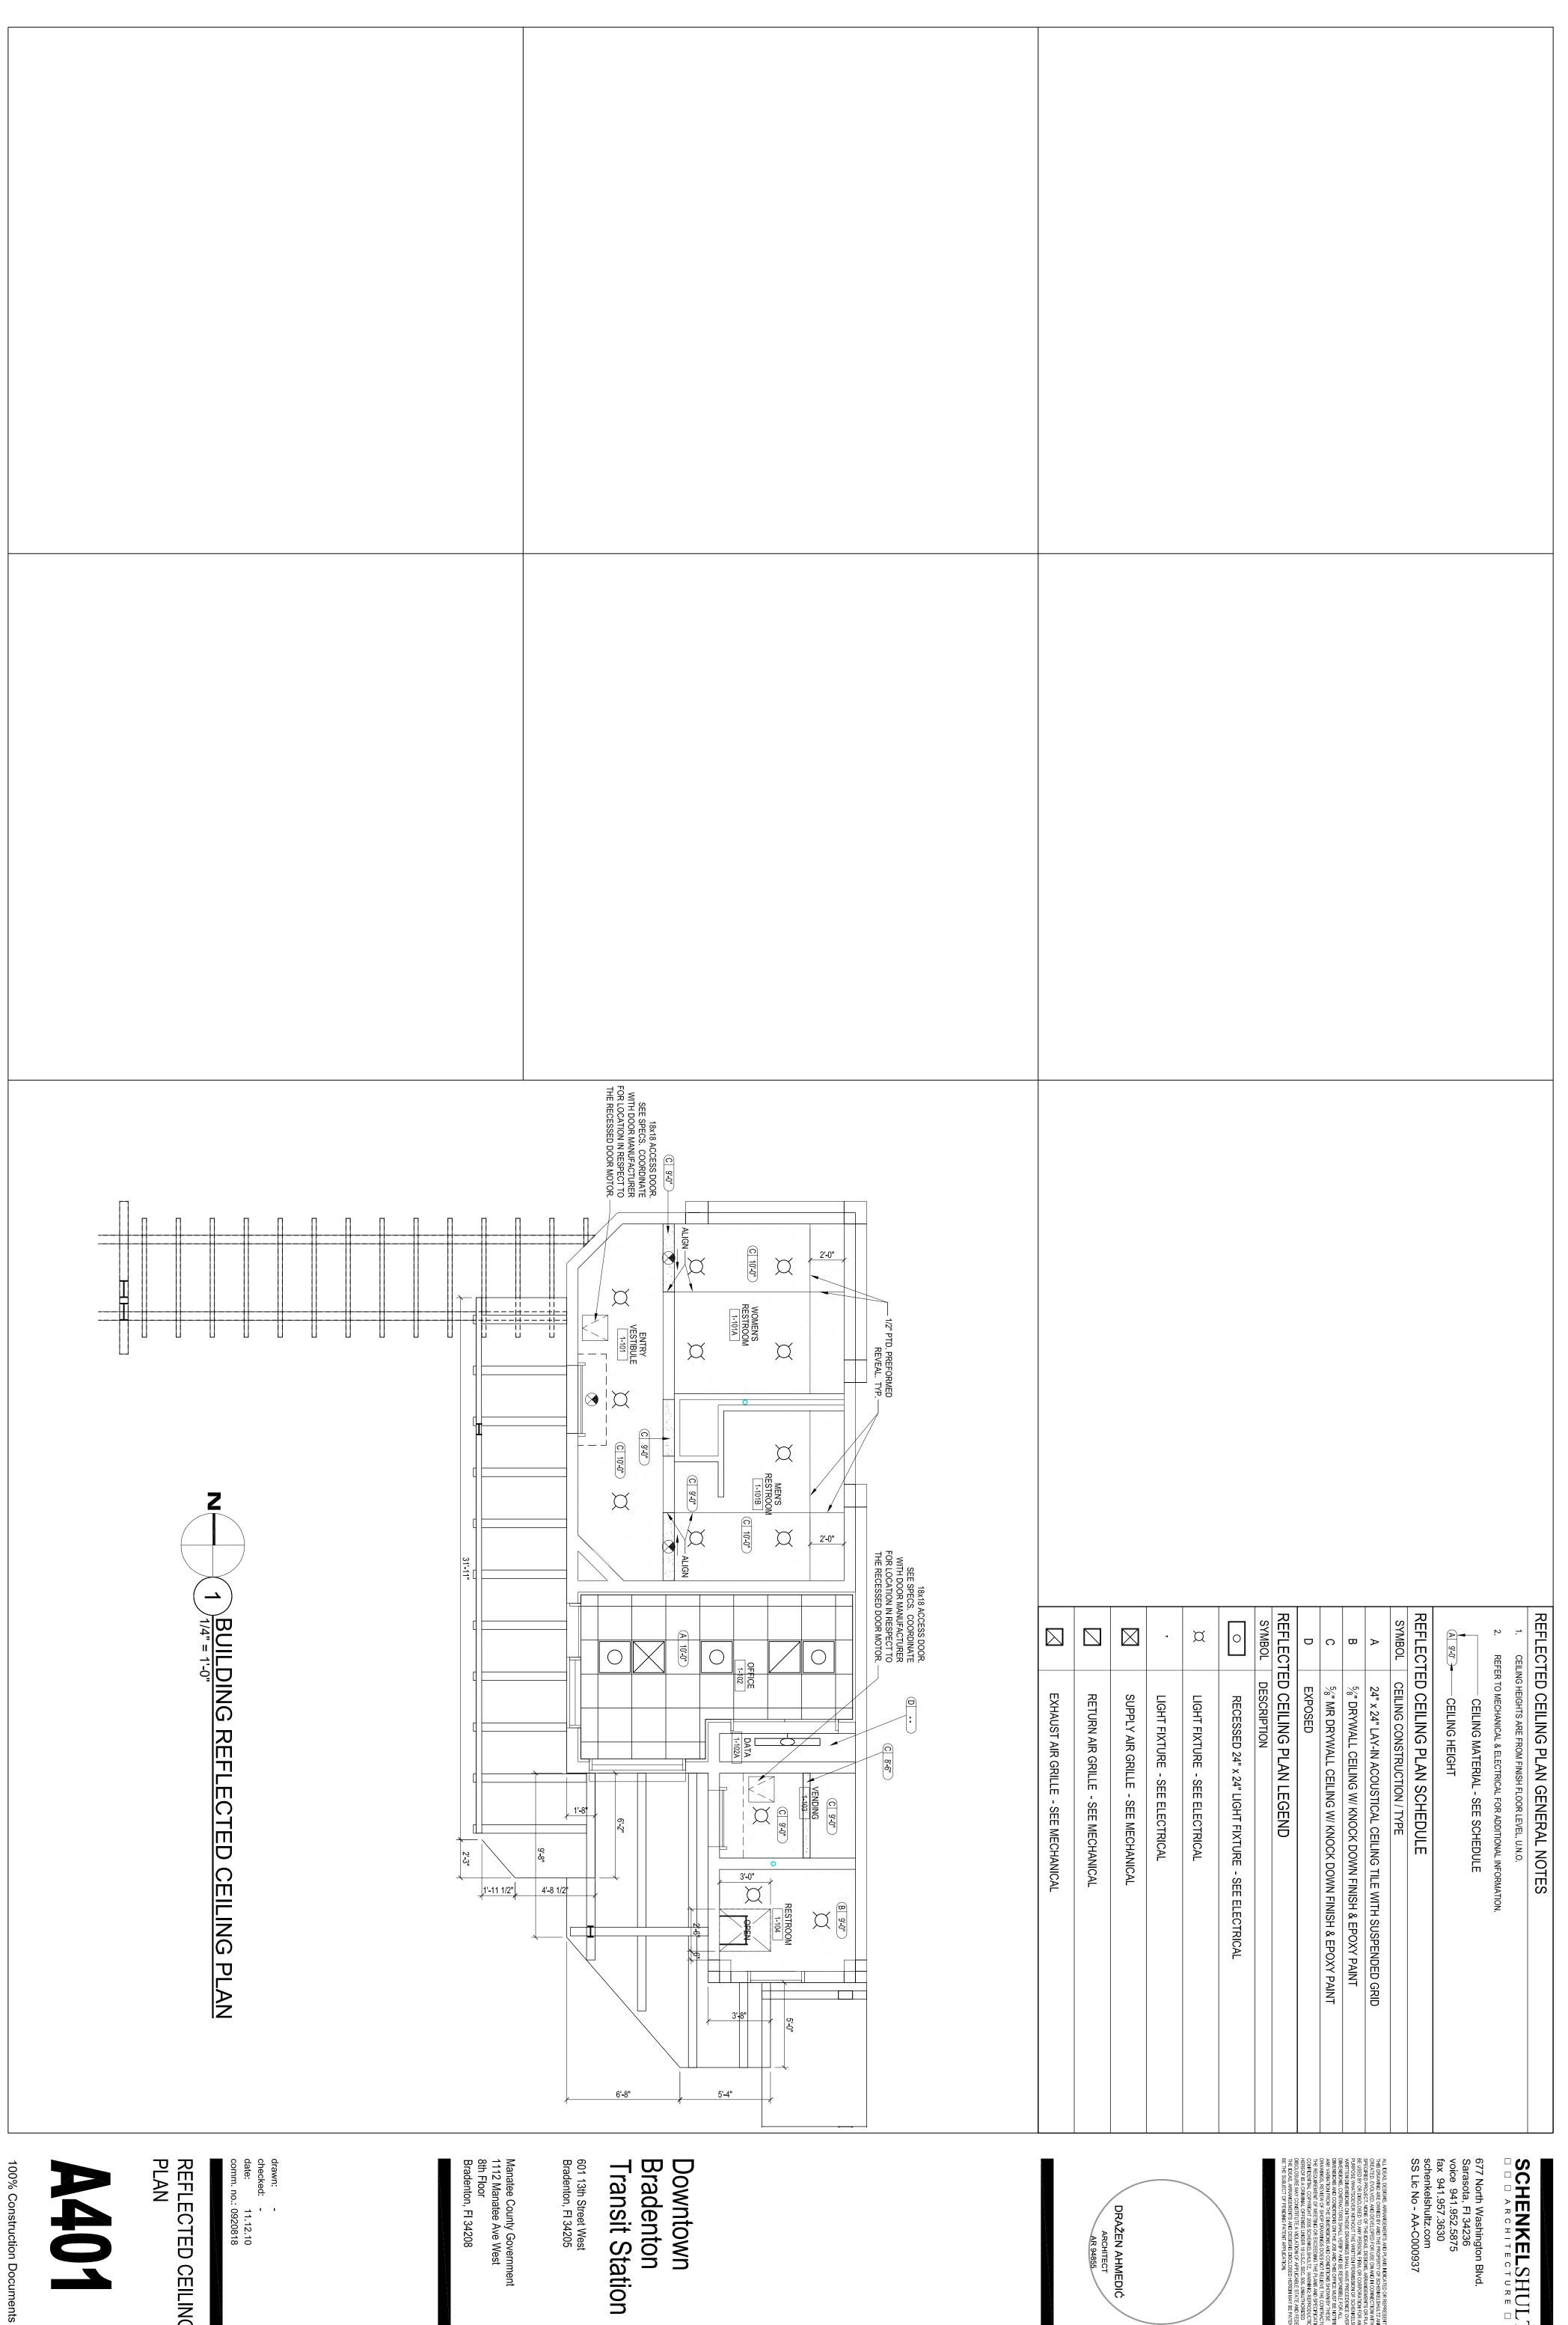

DRAŽEN AHMEDIĆ ARCHITECT AR 94855


Transit Station

Manatee County Government 1112 Manatee Ave West 8th Floor Bradenton, FI 34208


drawn: checked: date: 11.12.10
comm. no.: 0920818

REFLECTED CEILING


SCHENKELSHULTZ

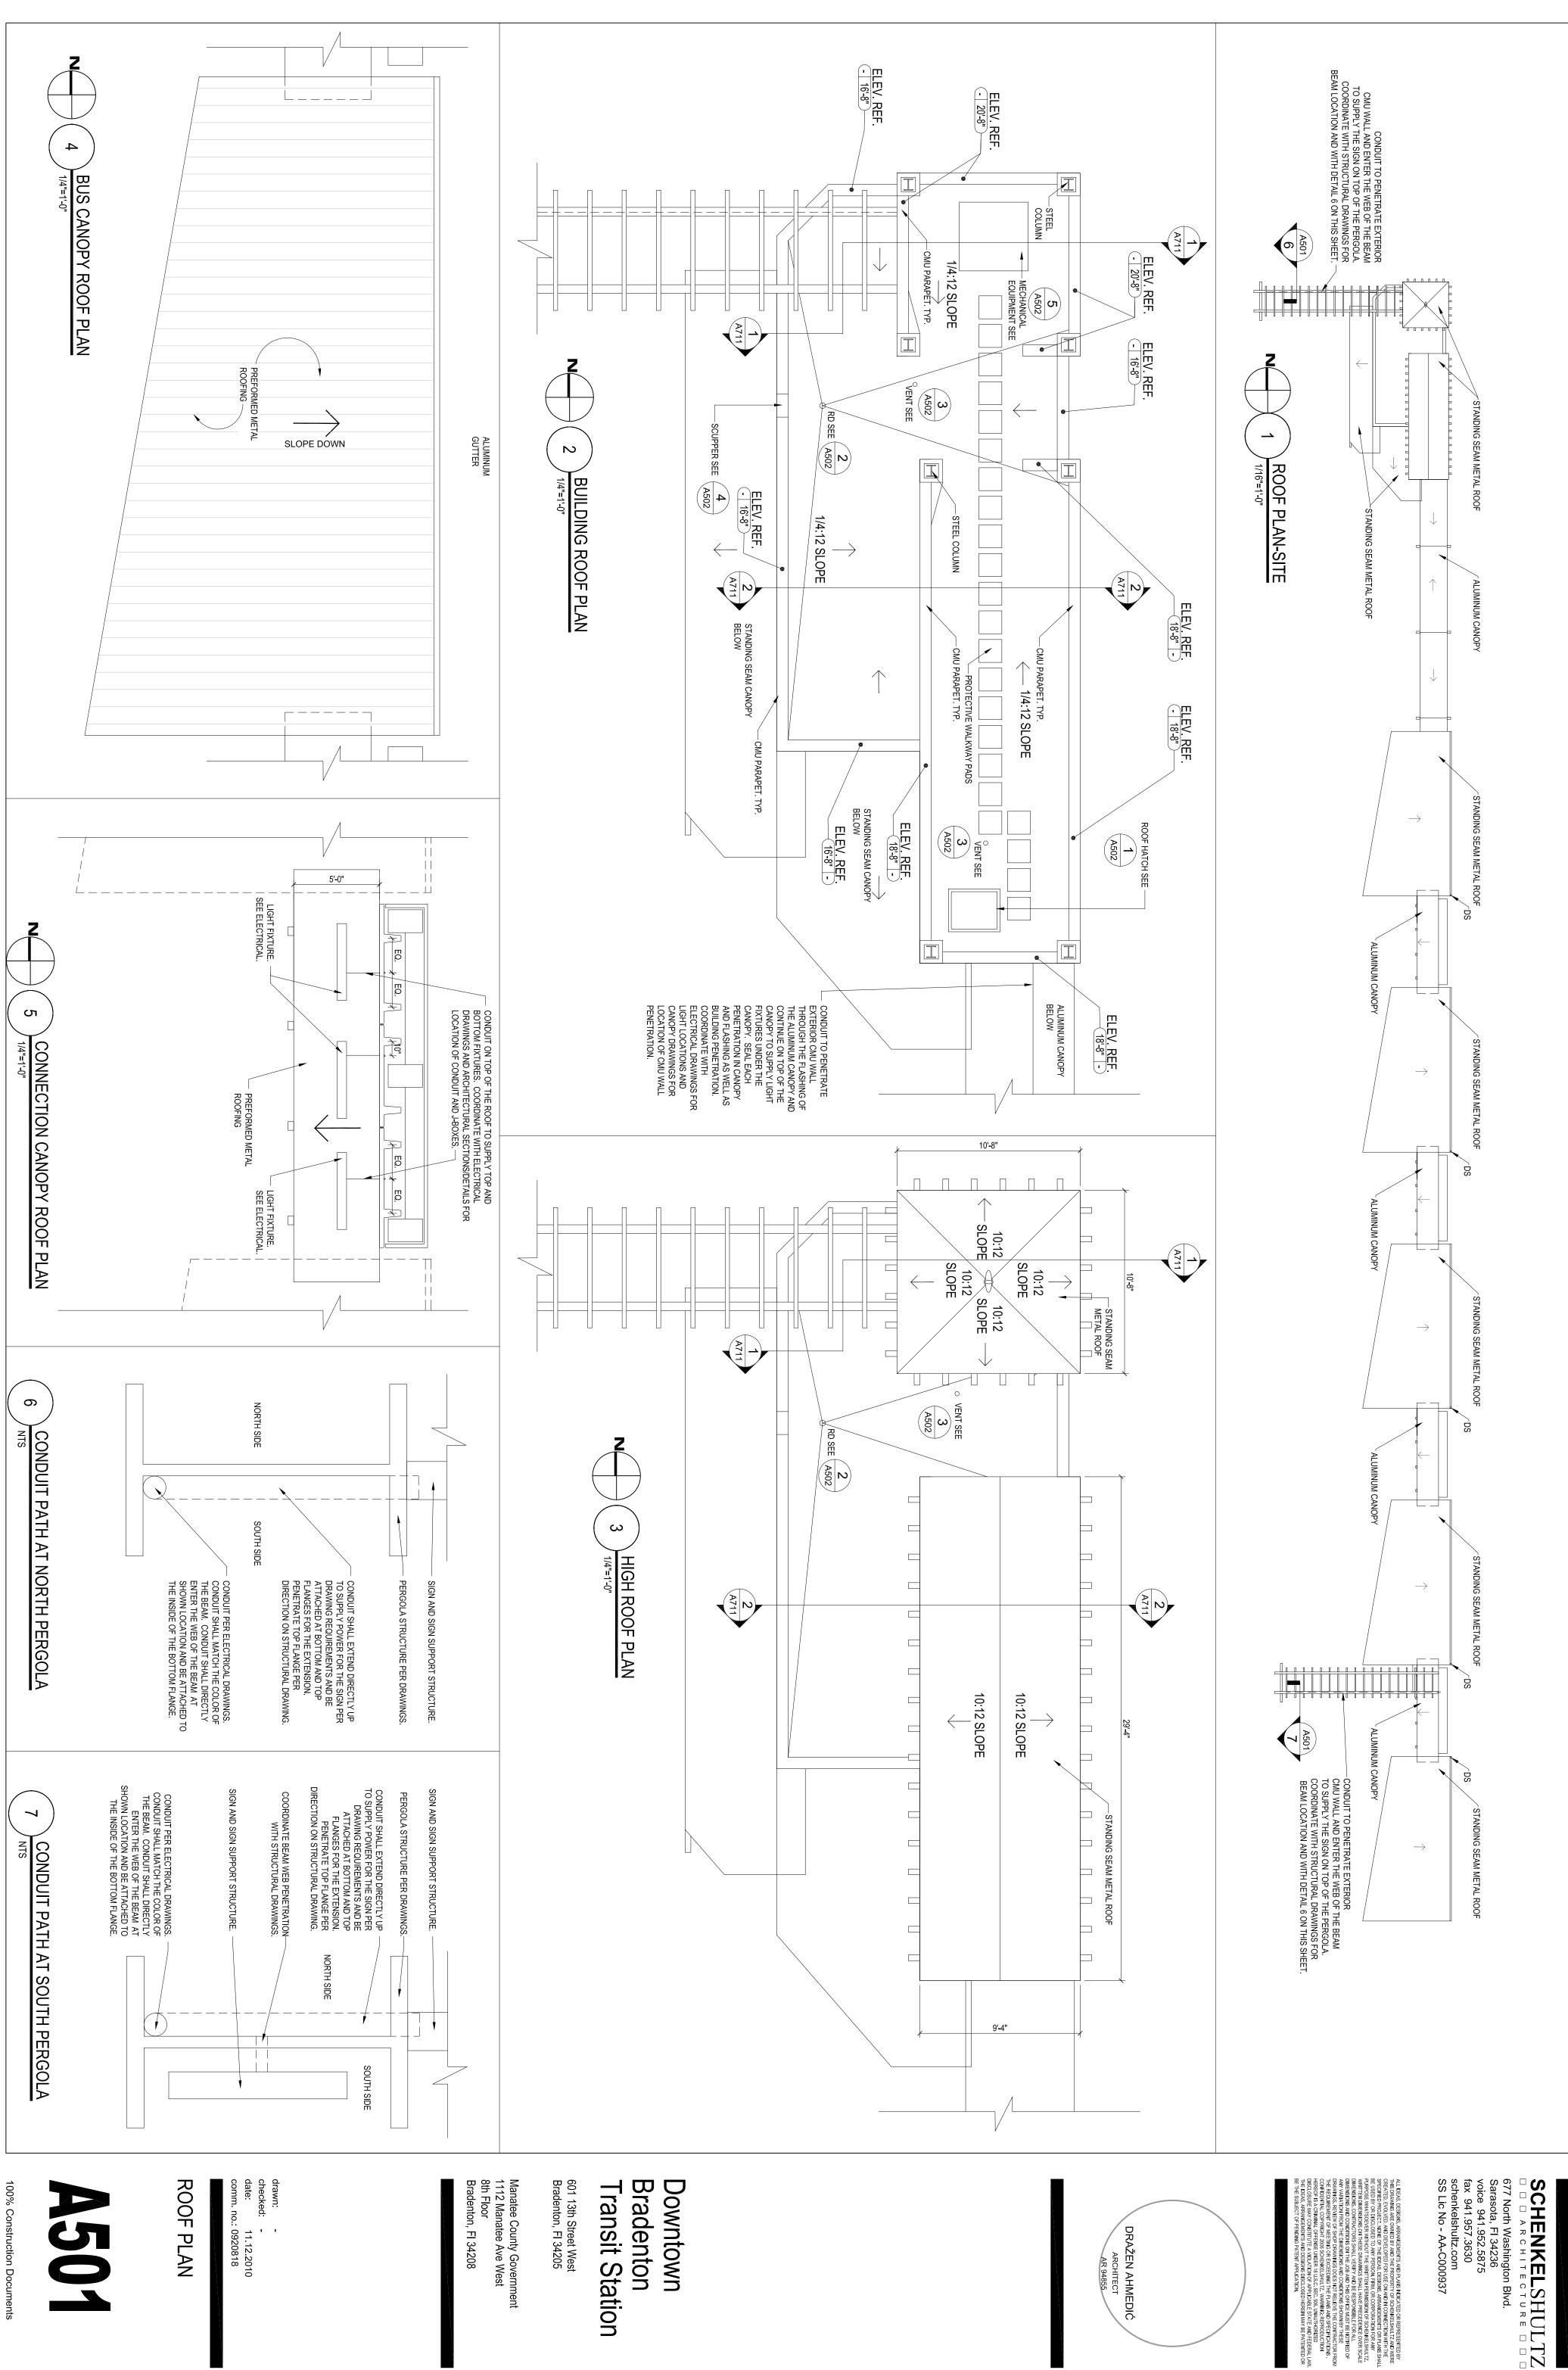

**A501** 

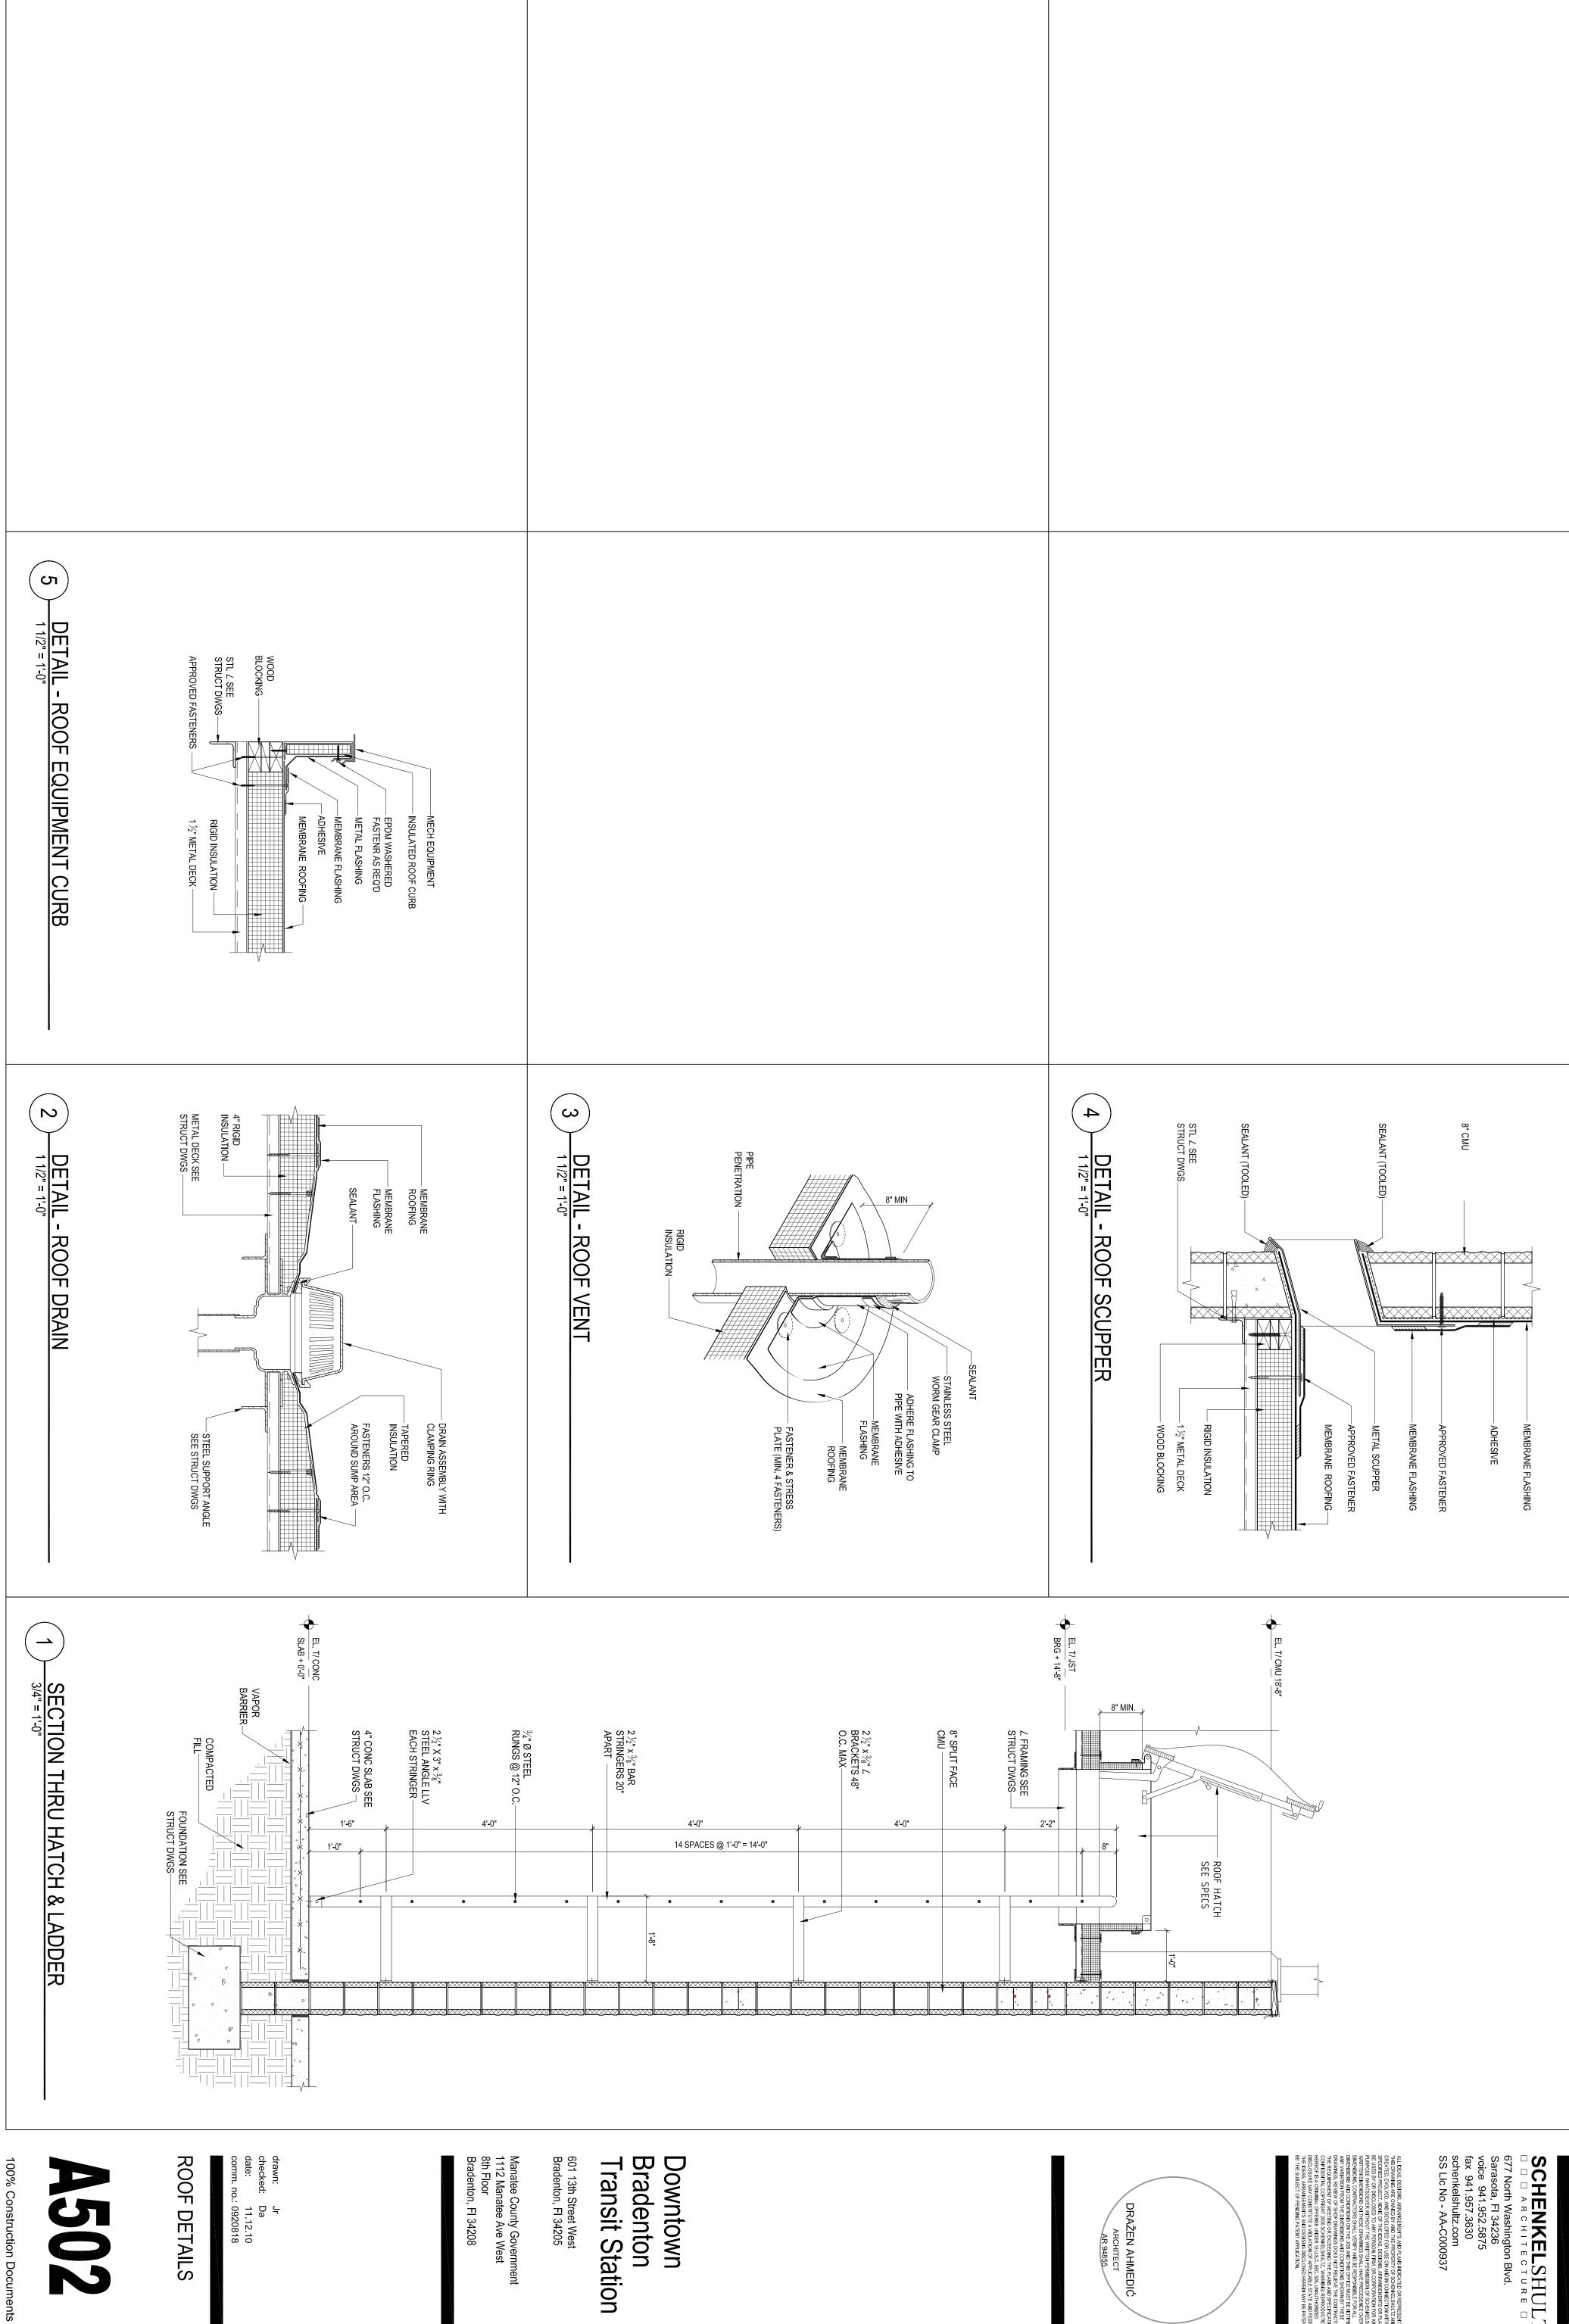


SCHENKELSHULTZ

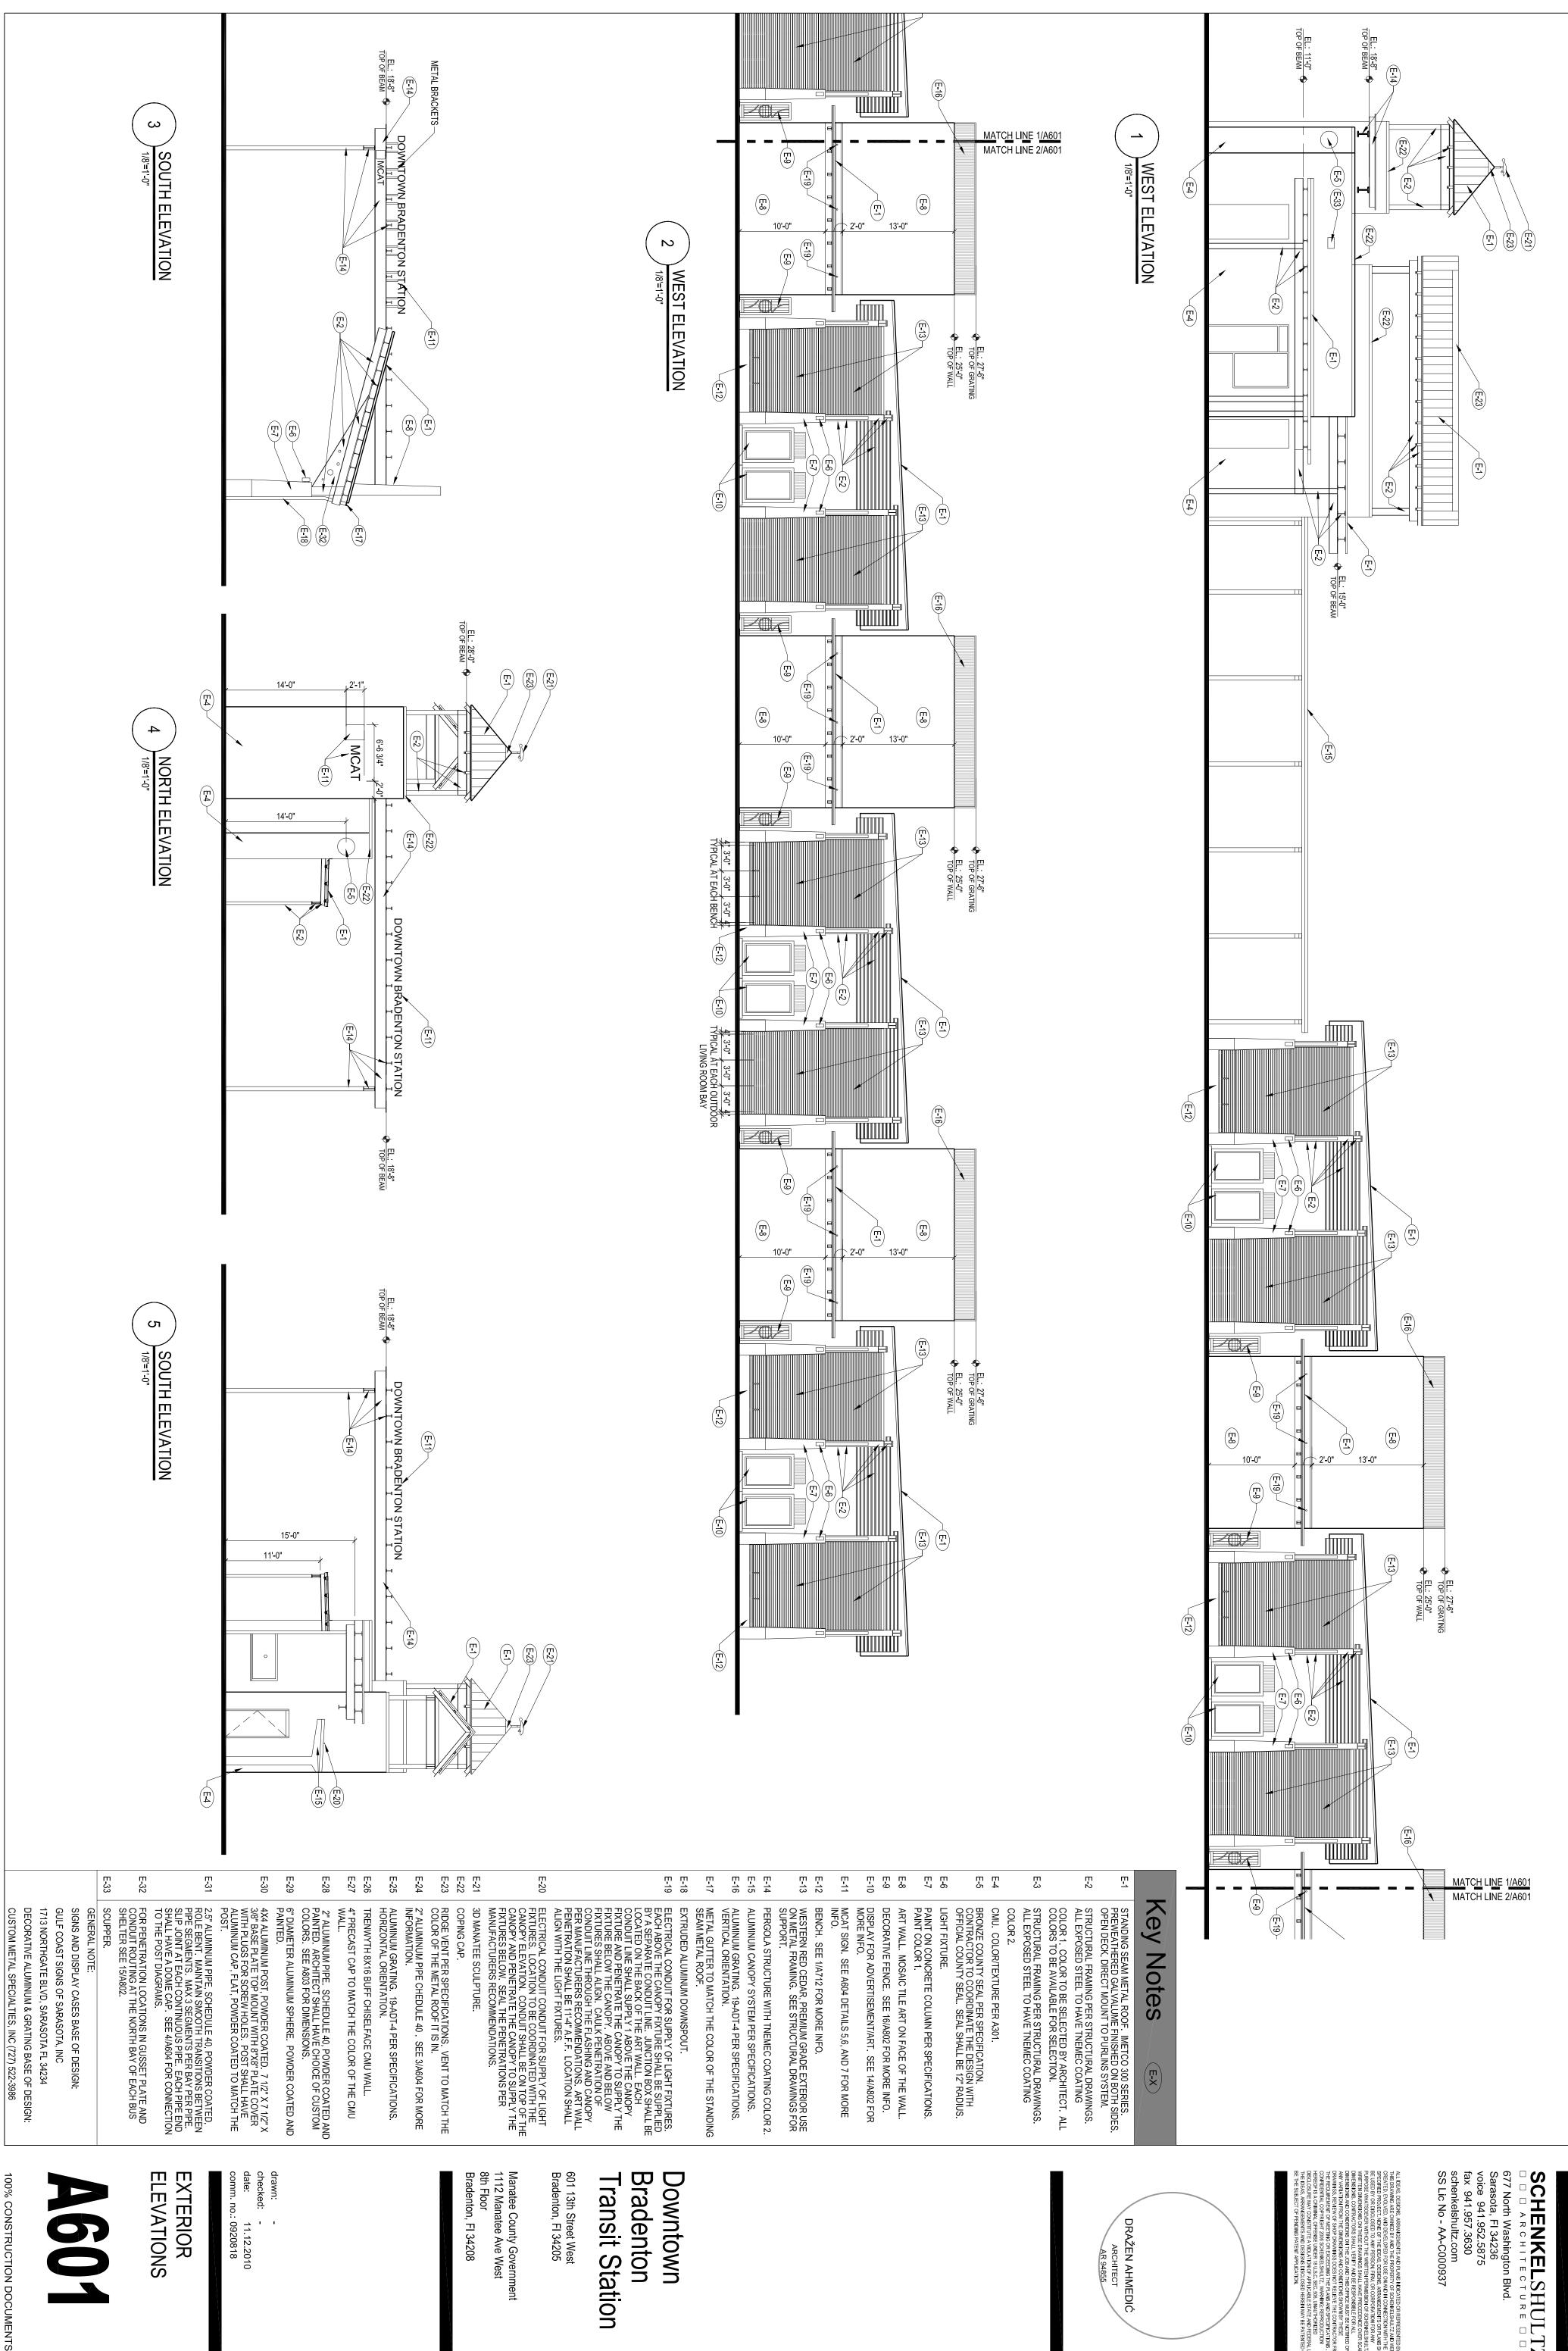

SCHENKELSHULTZ


677 North Washington Blvd.
Sarasota, Fl 34236
voice 941.952.5875
fax 941.957.3630
schenkelshultz.com
SS Lic No - AA-C000937


**ELEVATIONS** 

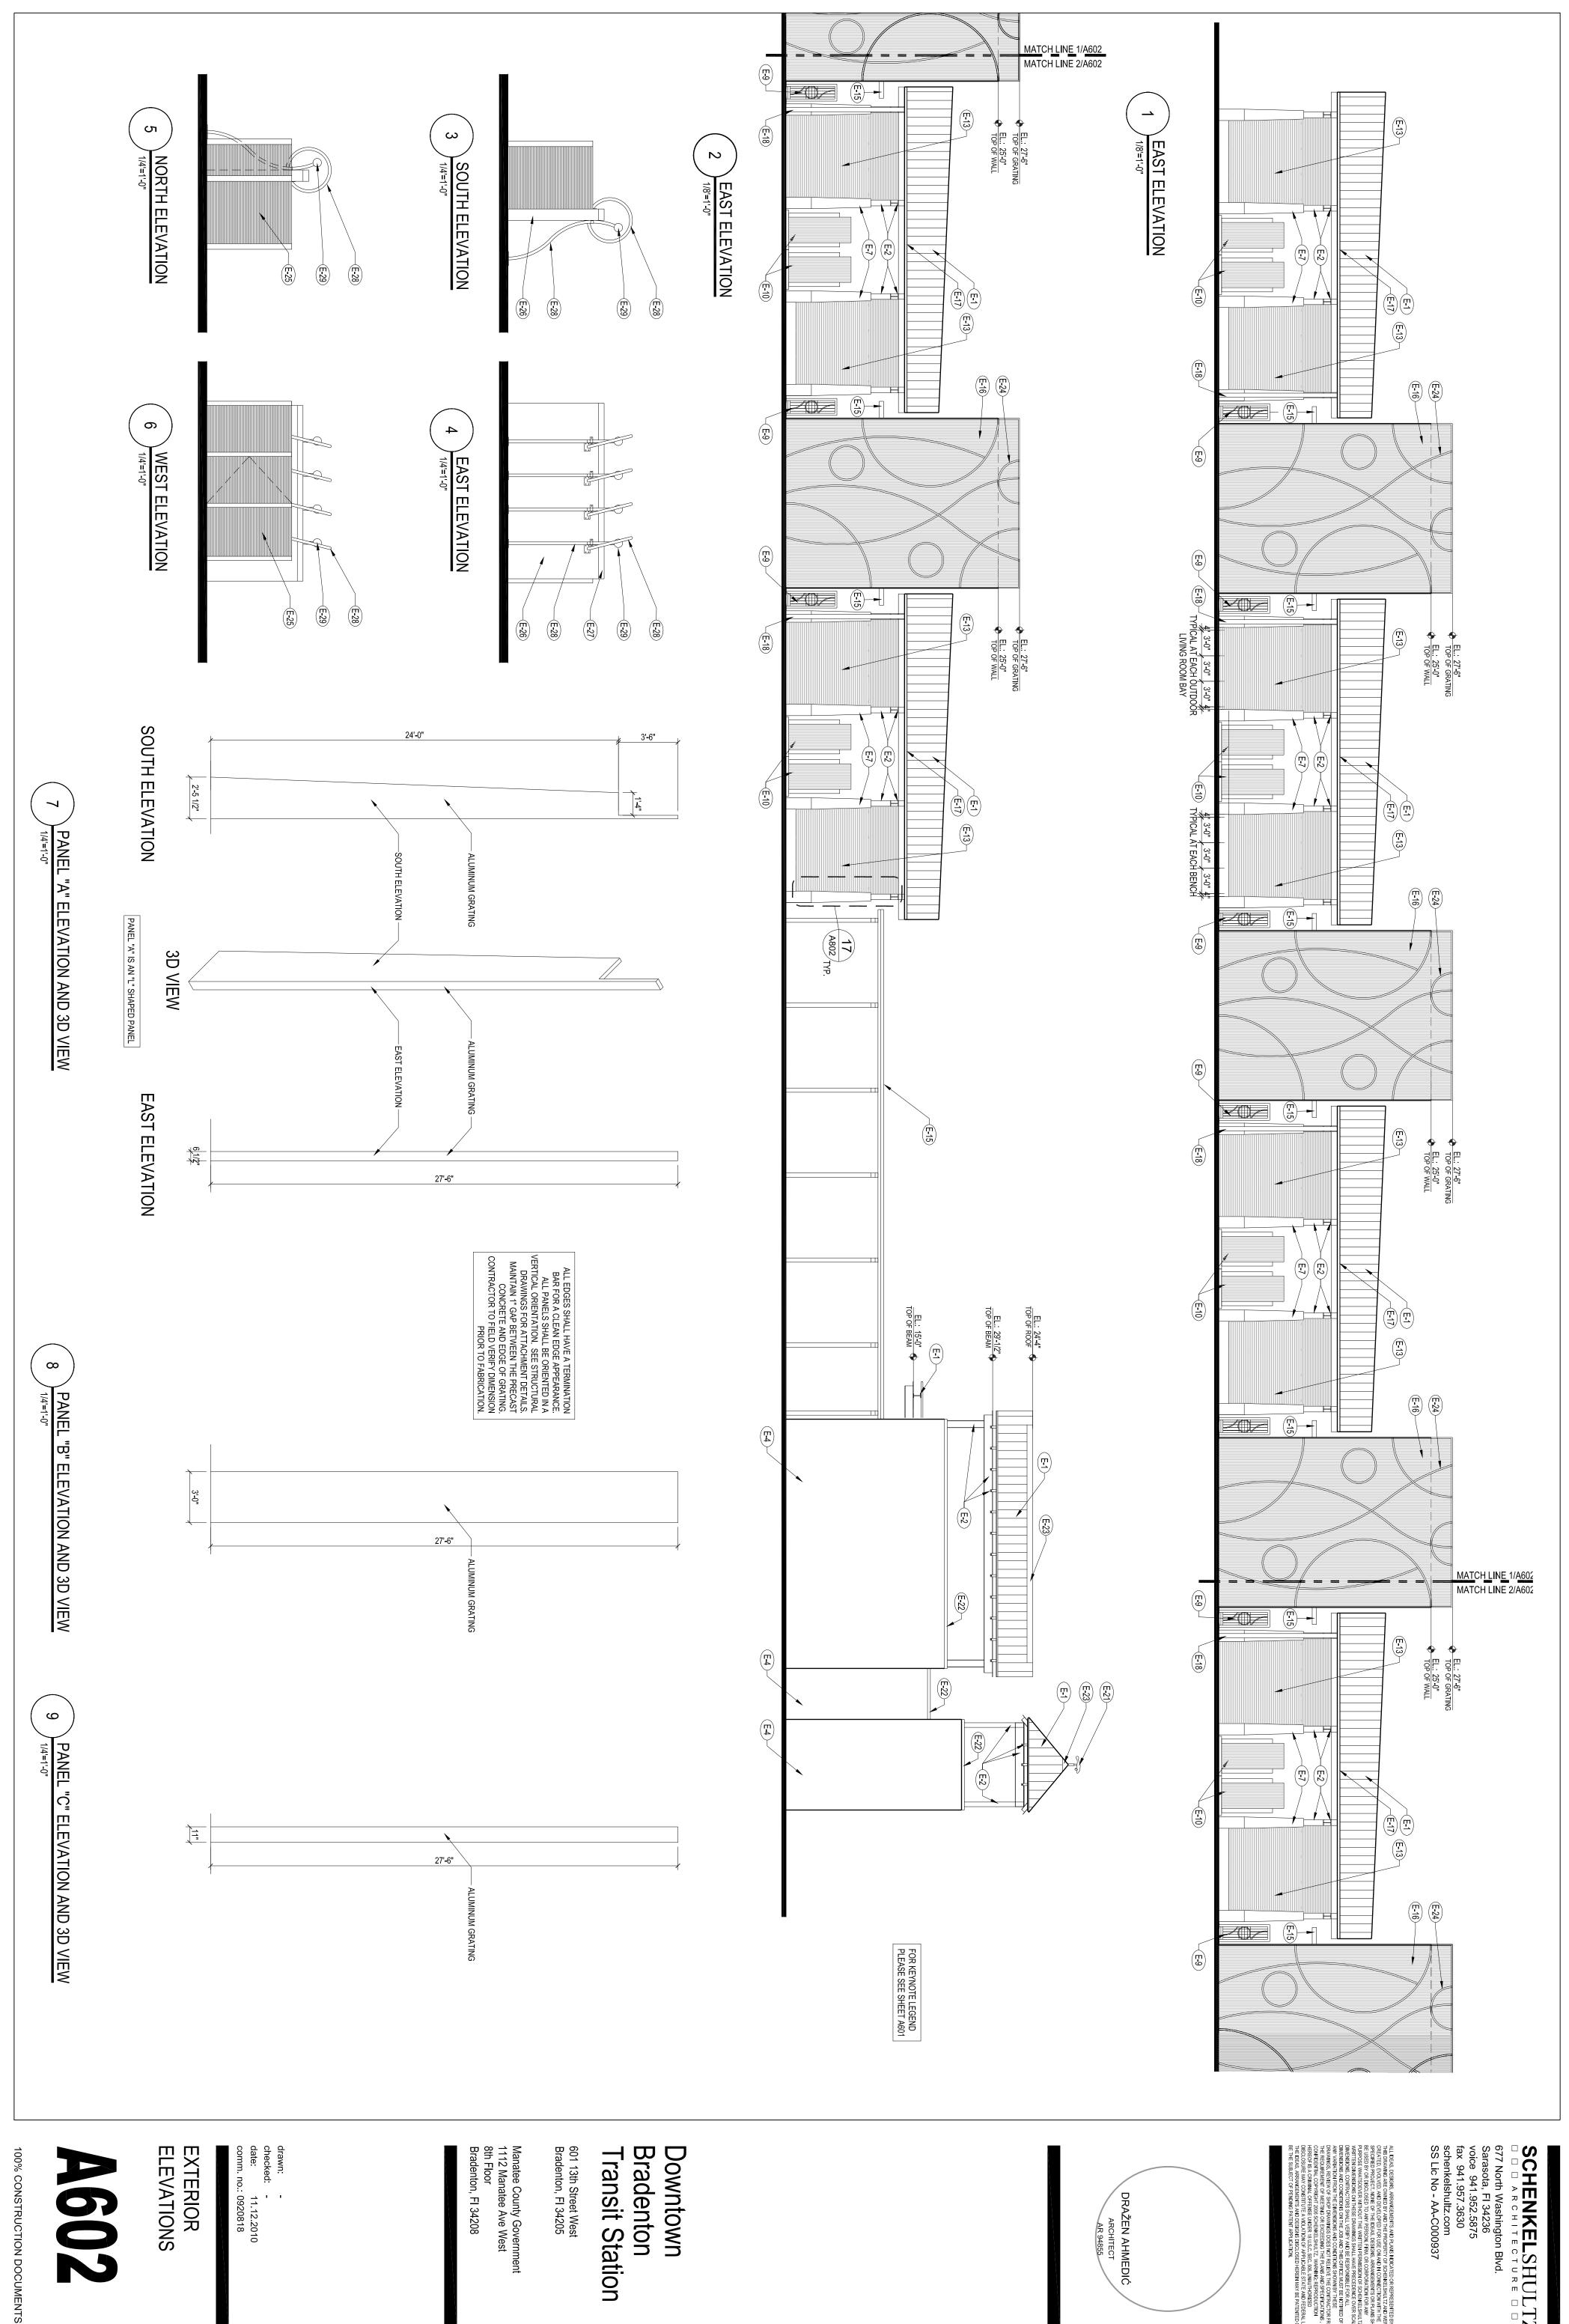



SCHENKELSHULTZ

677 North Washington Blvd.
Sarasota, Fl 34236
voice 941.952.5875
fax 941.957.3630
schenkelshultz.com
SS Lic No - AA-C000937

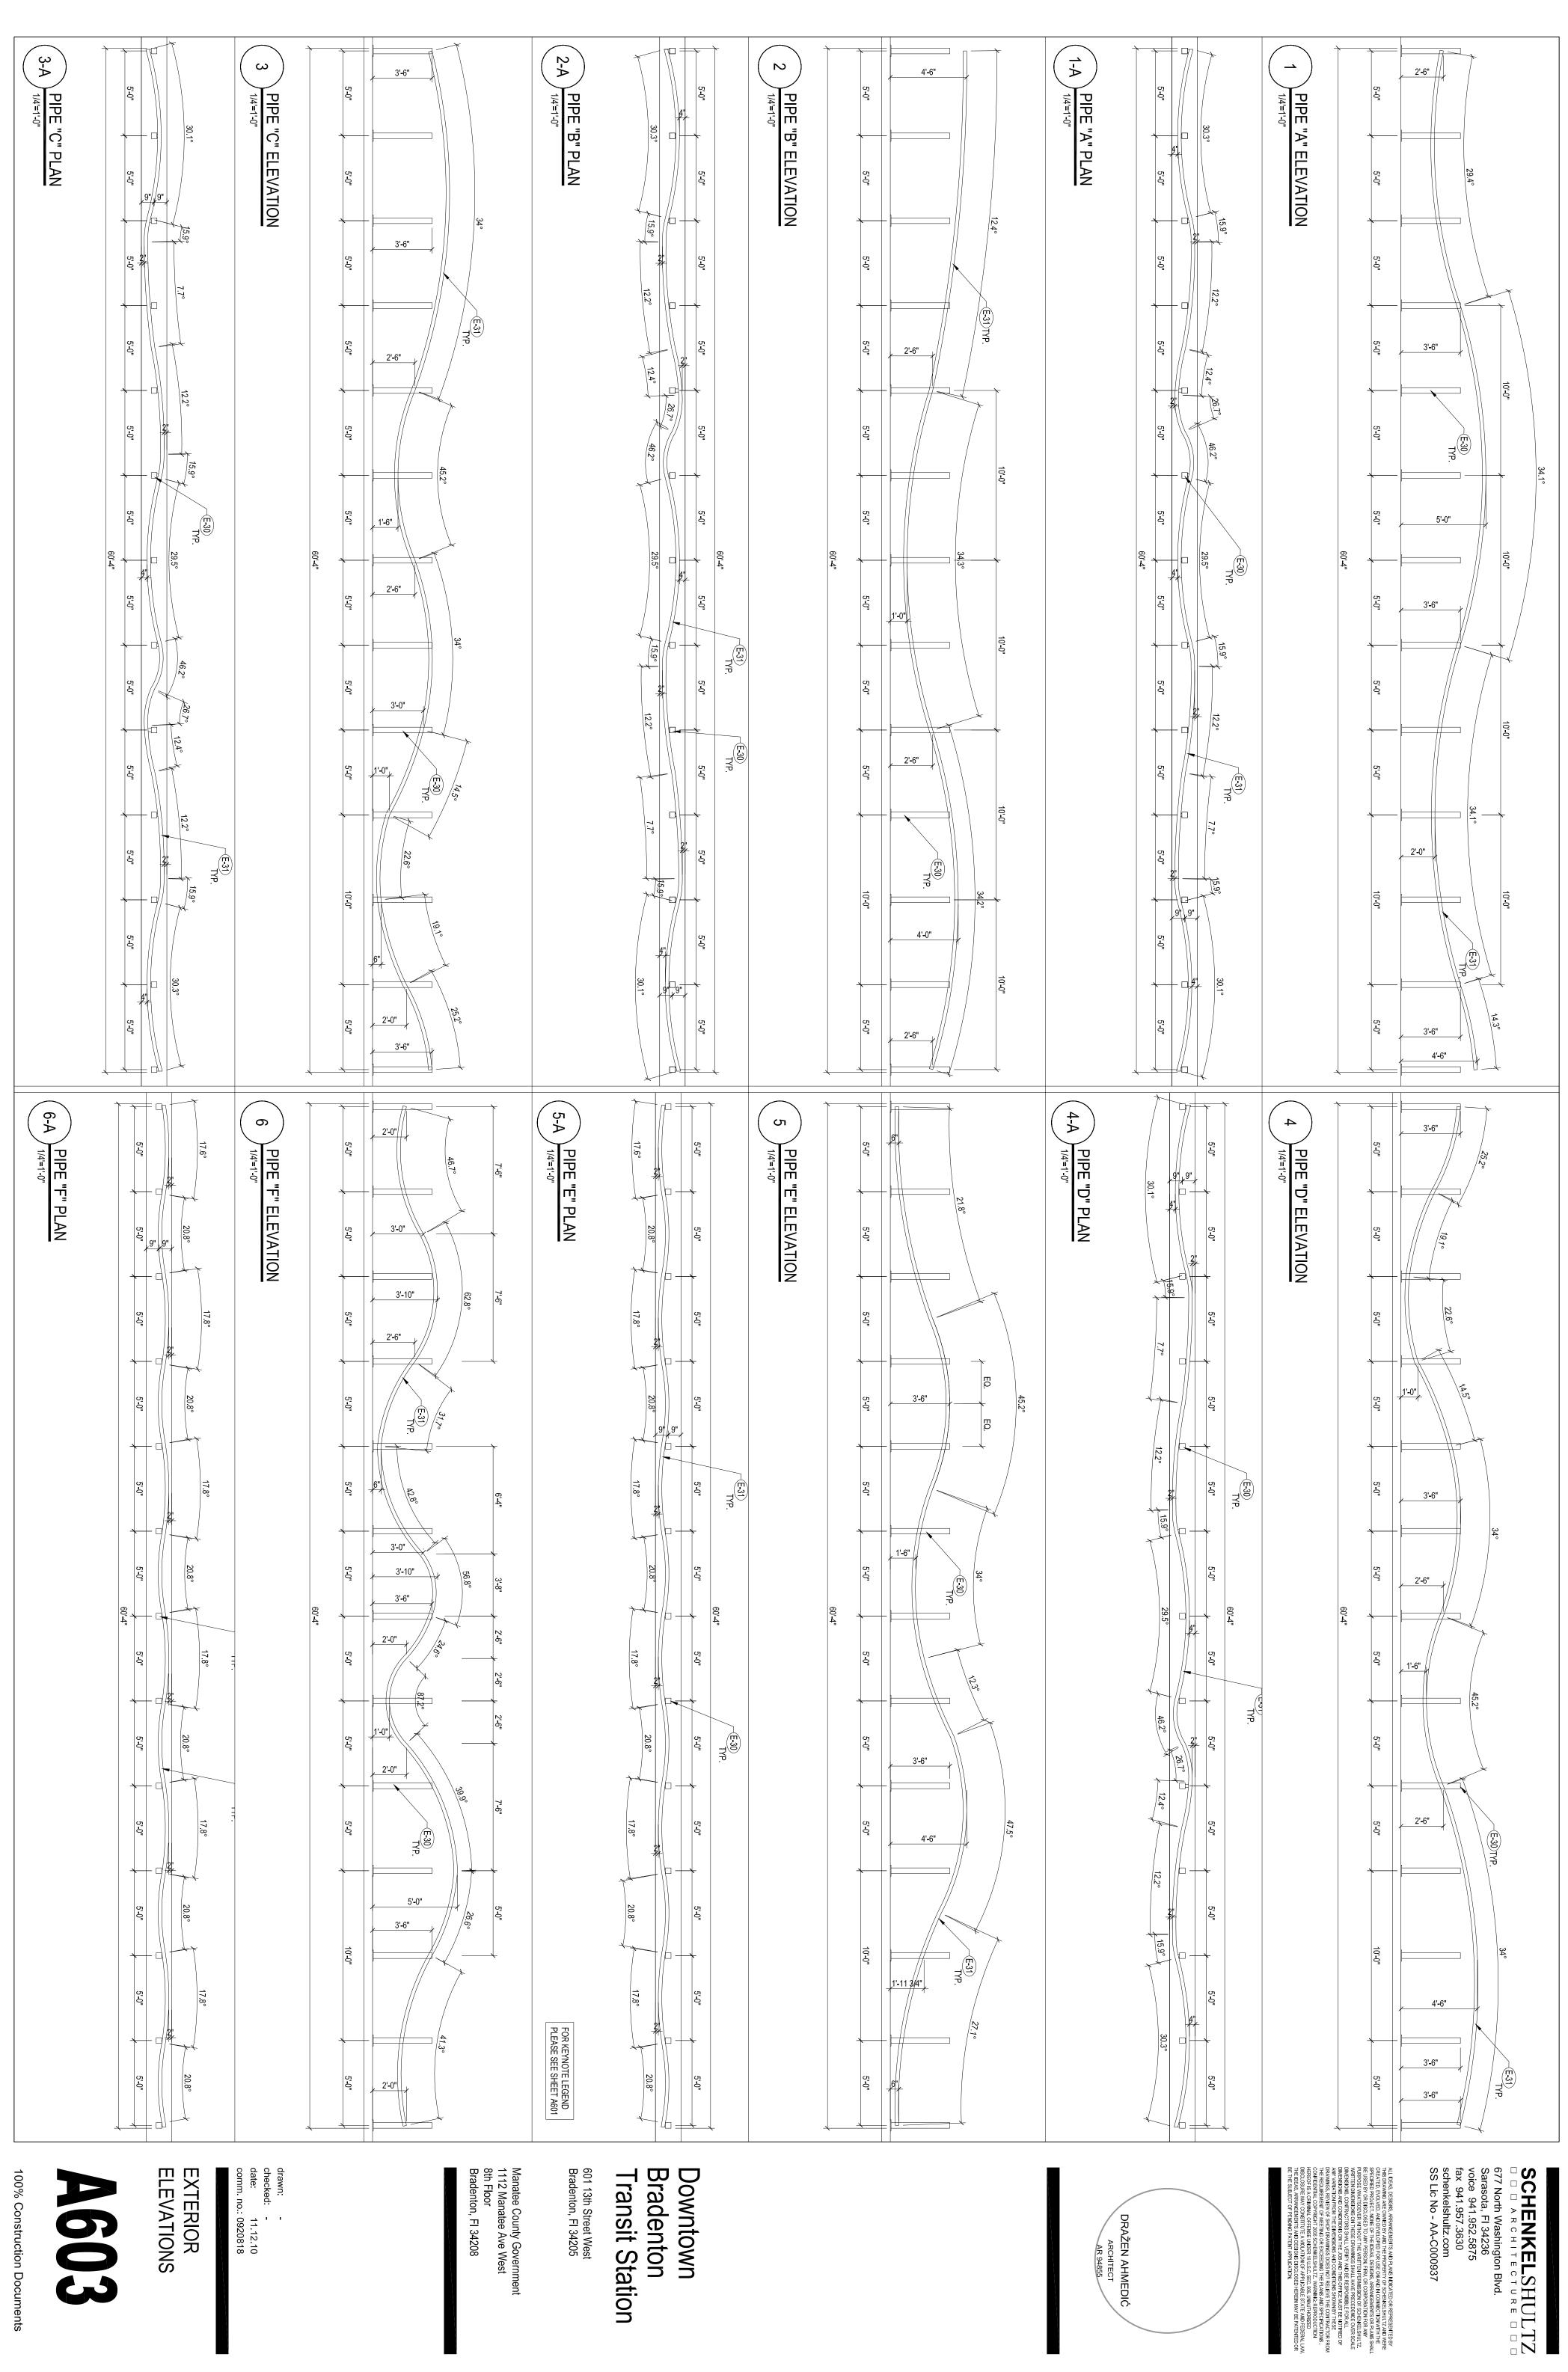

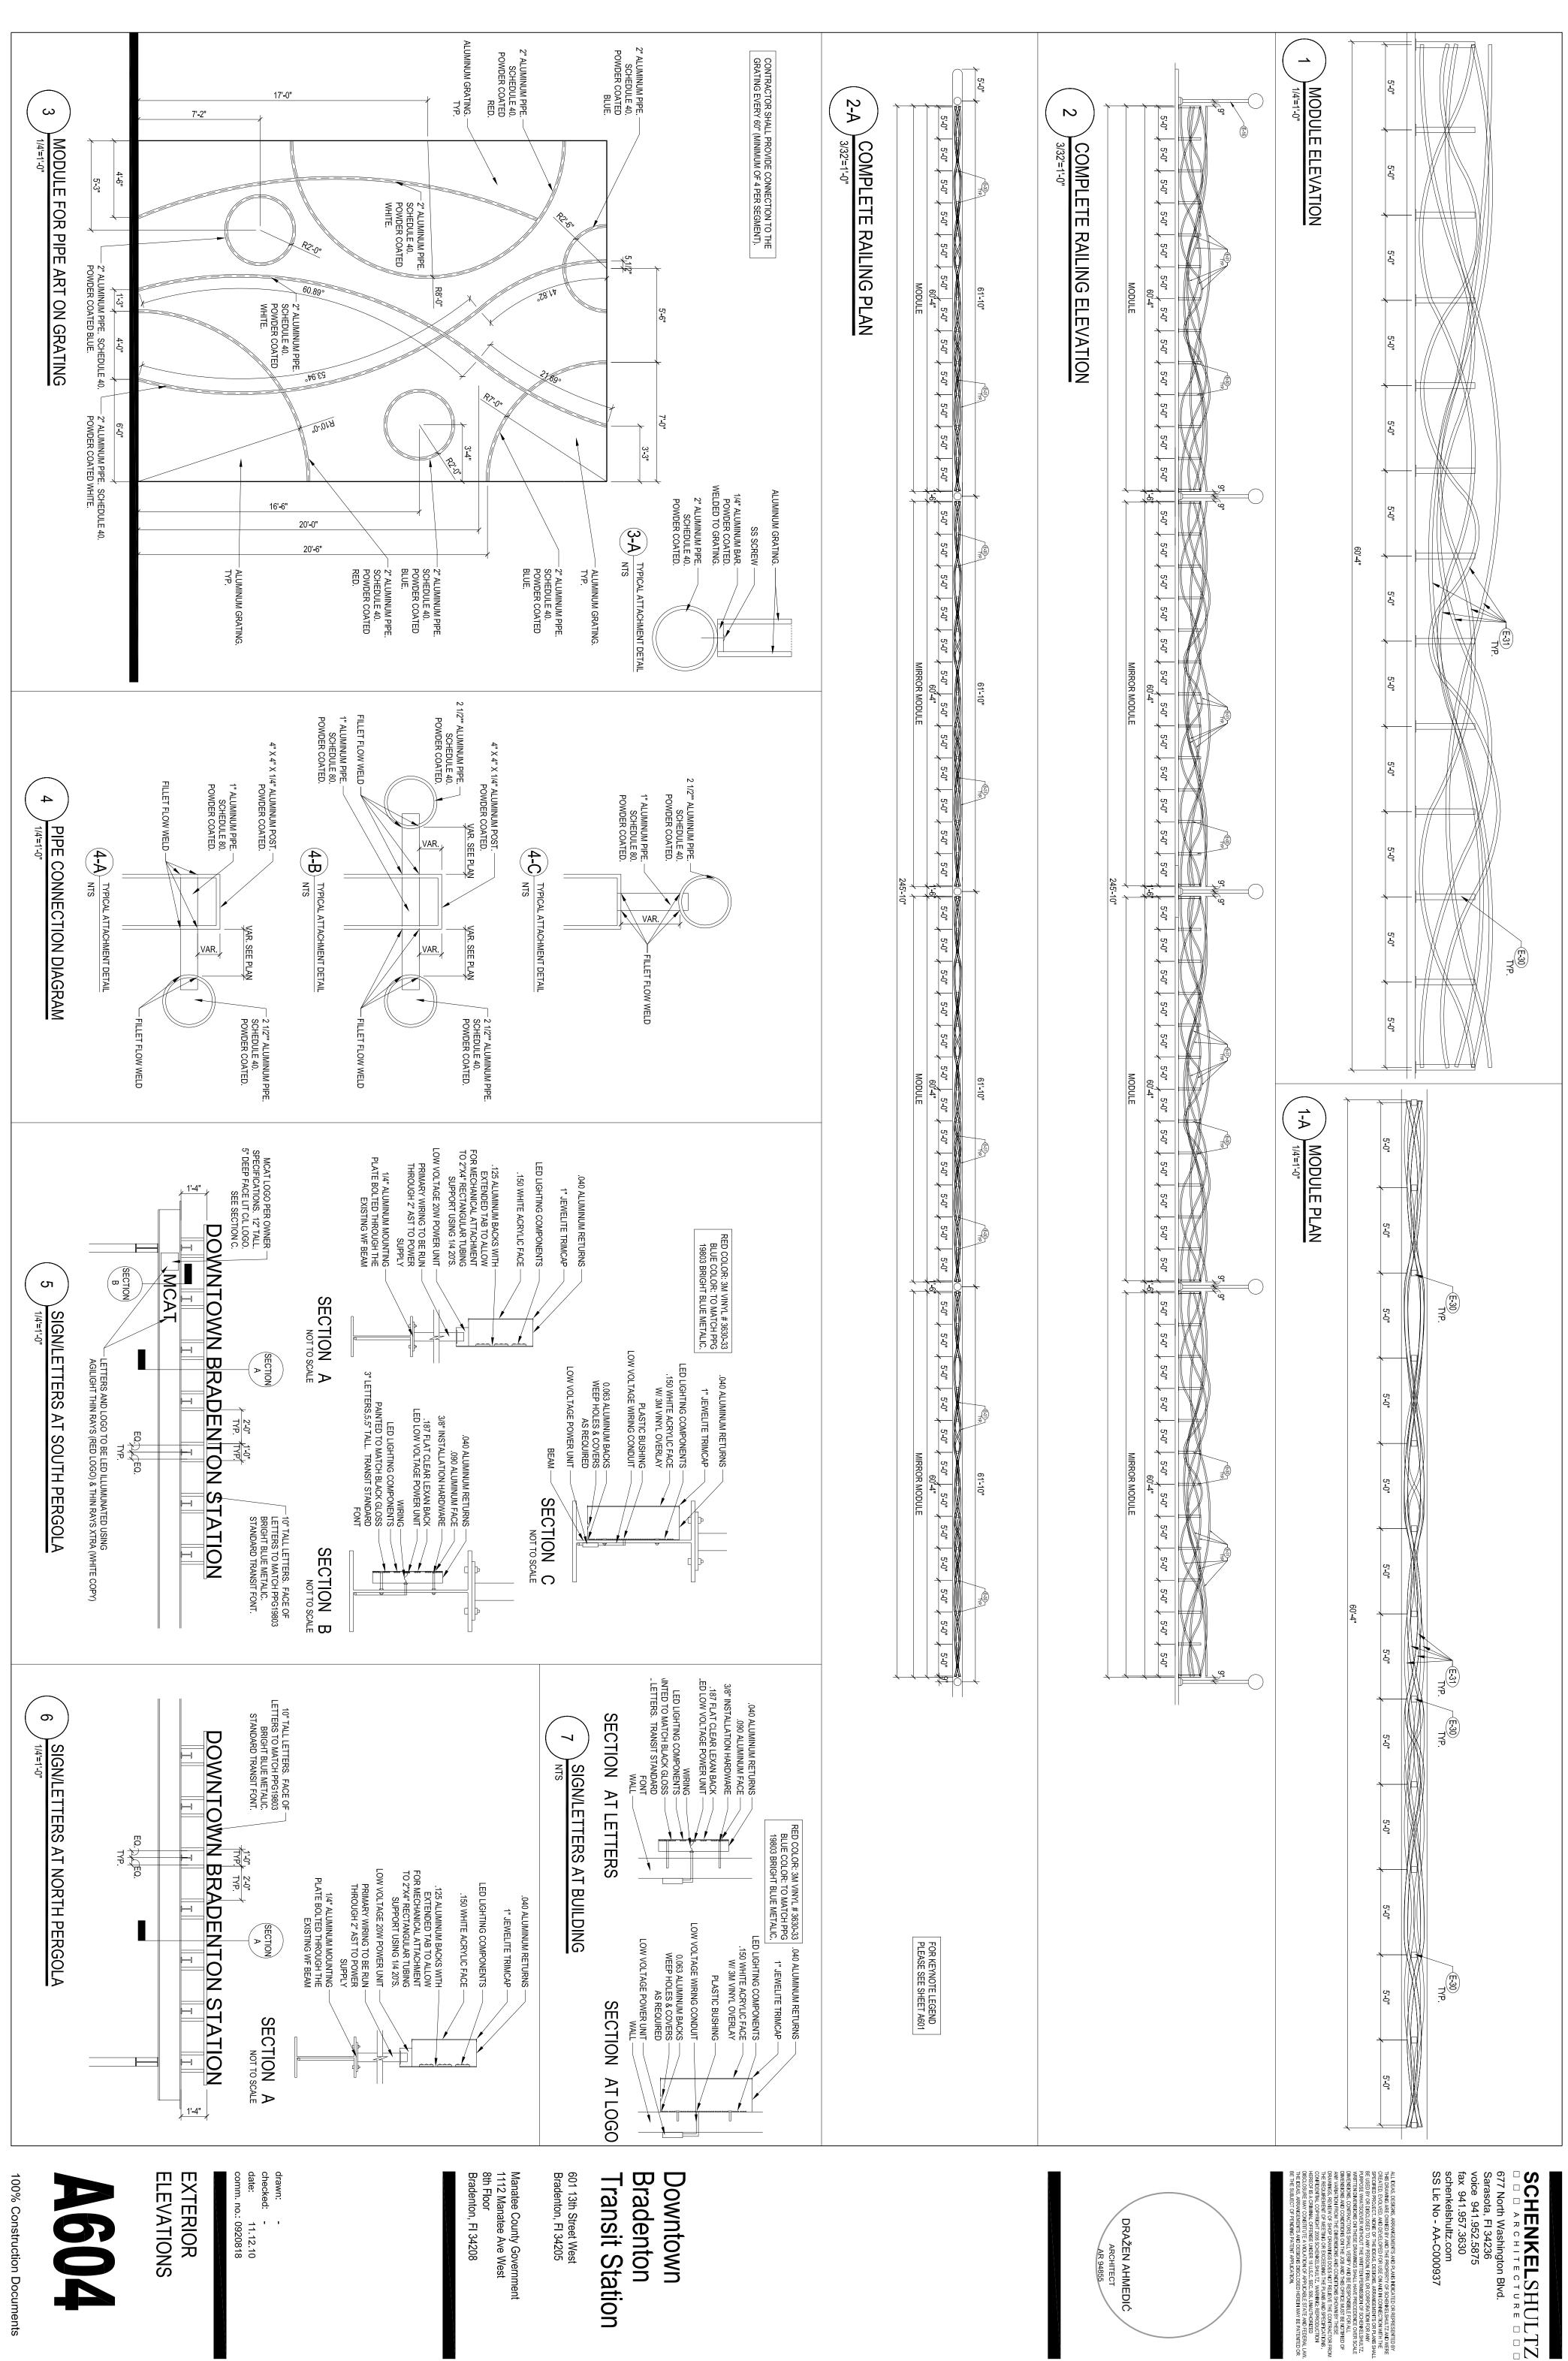

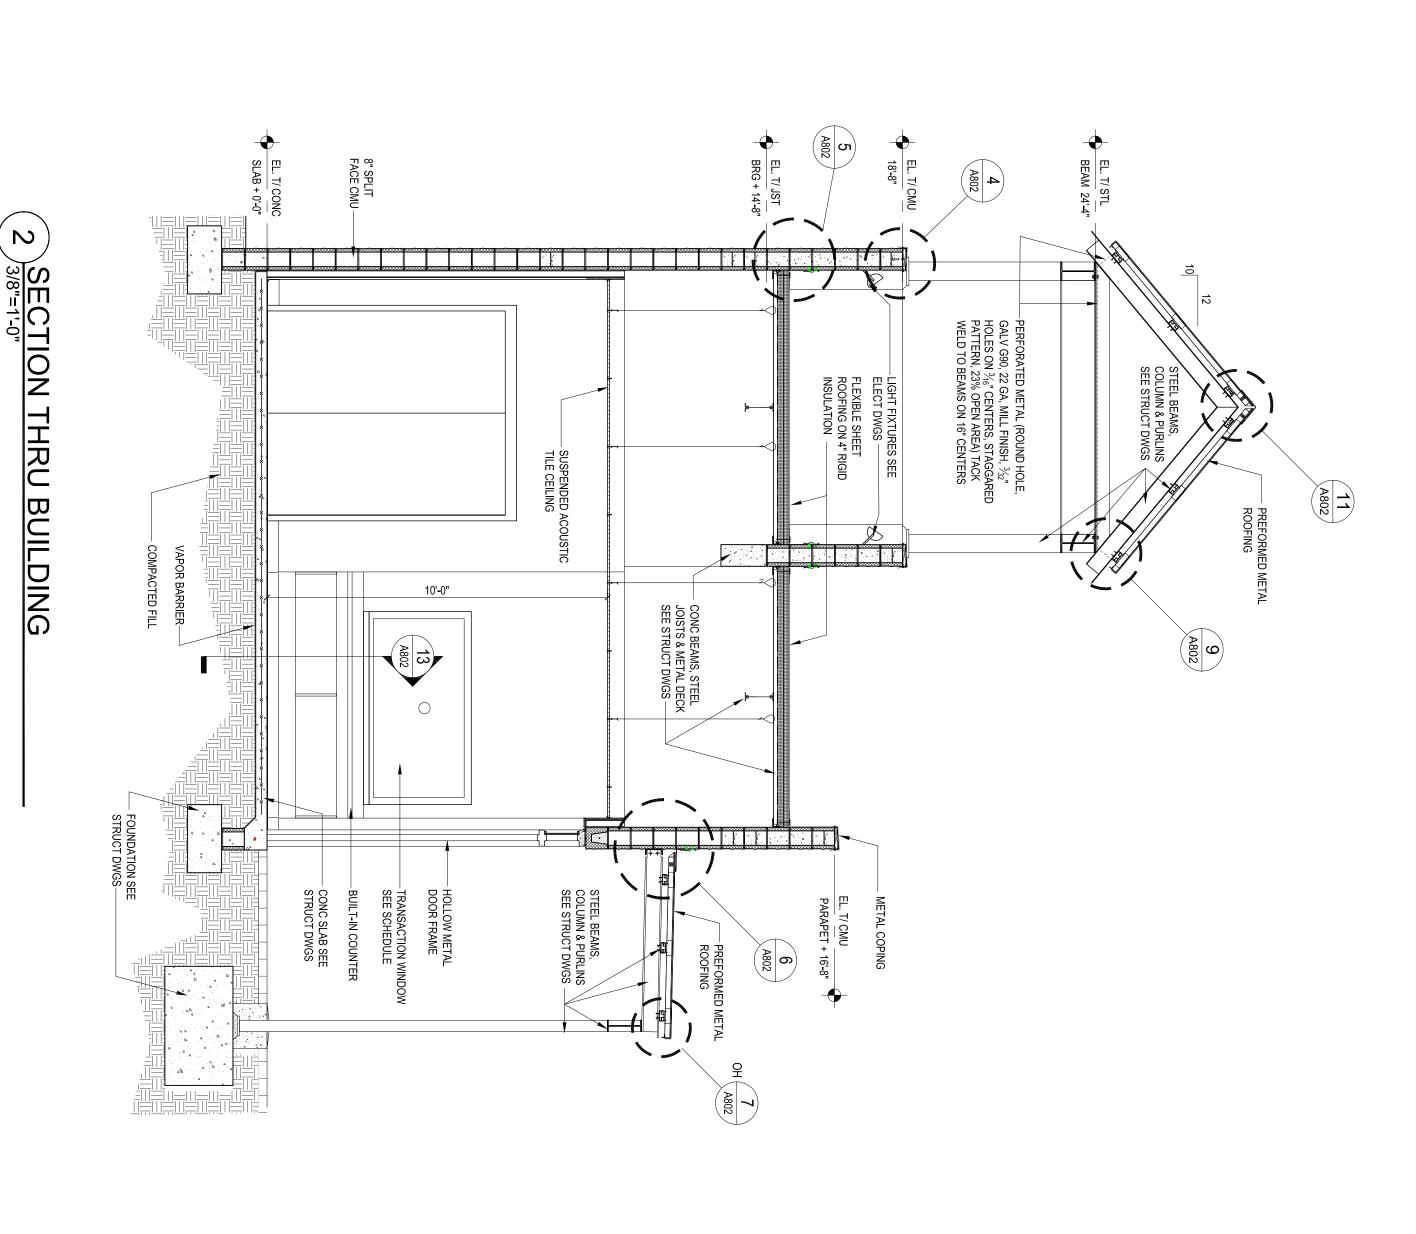

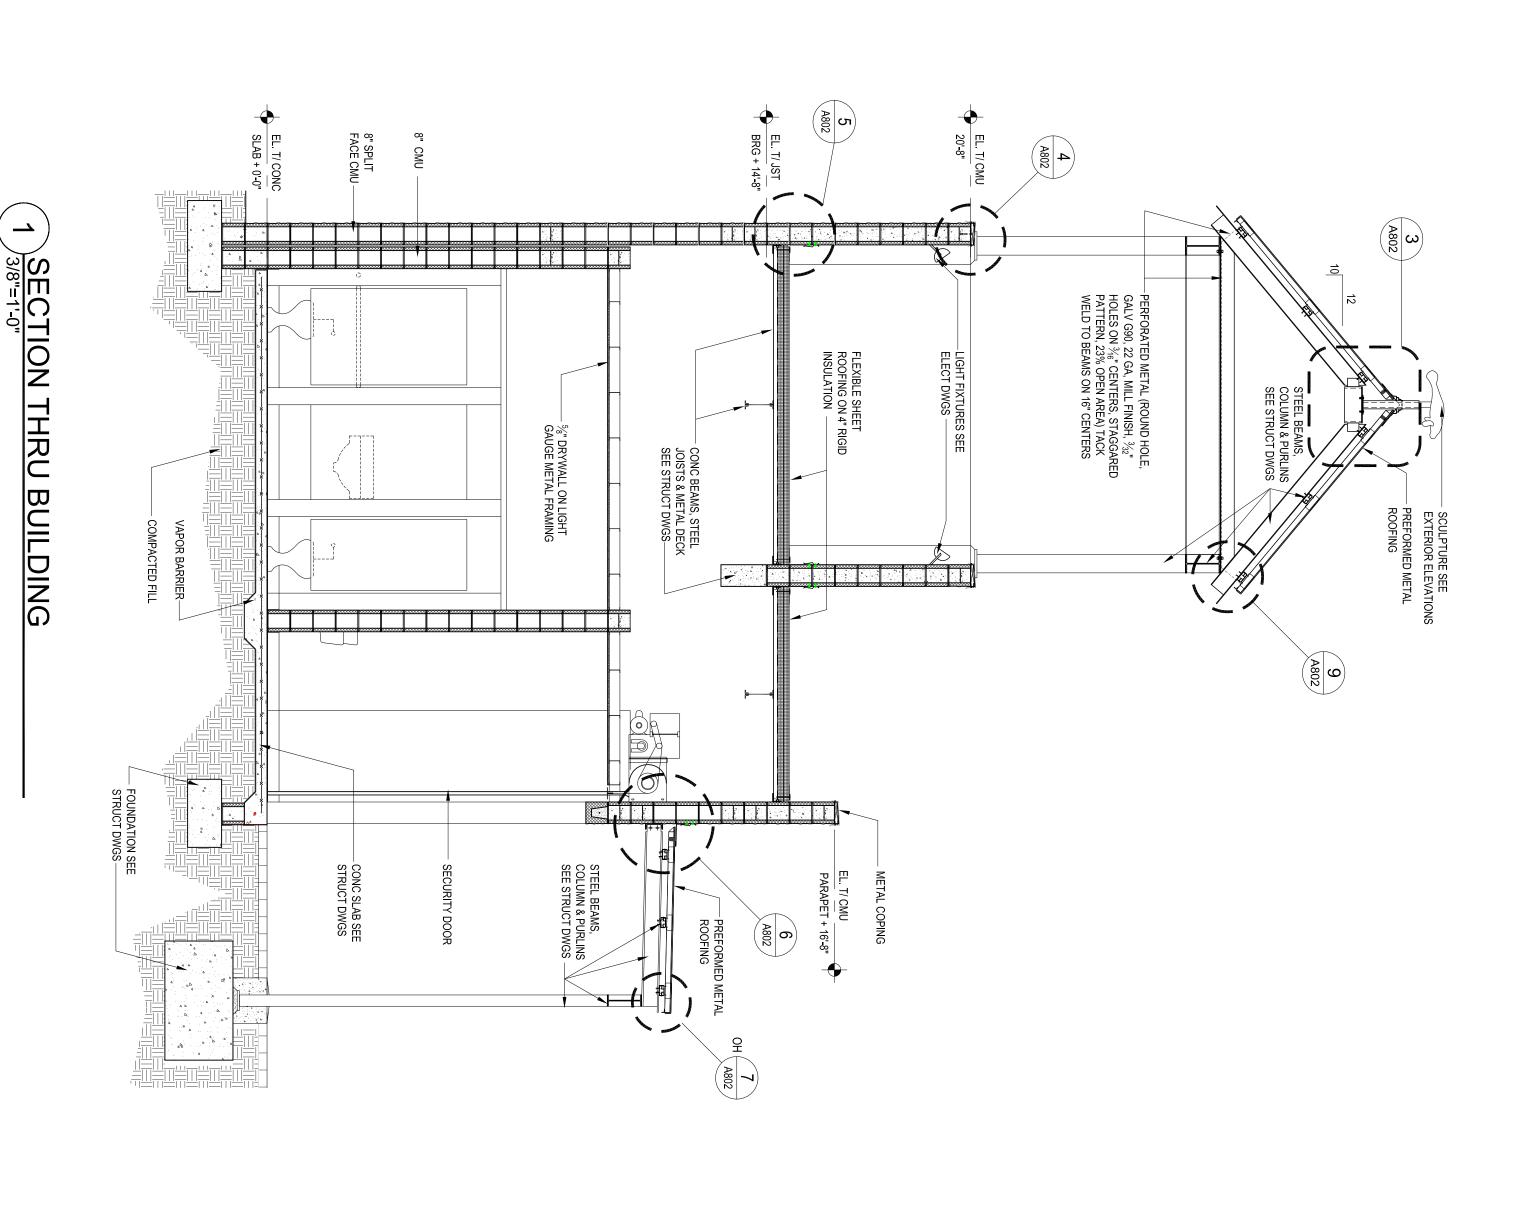

100% Construction Documents

(N)

677 North Washington Blvd.
Sarasota, Fl 34236
voice 941.952.5875
fax 941.957.3630
schenkelshultz.com
SS Lic No - AA-C000937

DRAŽEN AHMEDIĆ

ARCHITECT

AR 94855

SCHENKELSHULTZ


Bradenton Downtown Transit Station


601 13th Street West Bradenton, FI 34205


Manatee County Government 1112 Manatee Ave West 8th Floor Bradenton, FI 34208

drawn: Da
checked: Da
date: 11.12.10
comm. no.: 0920818

WALL SECTIONS

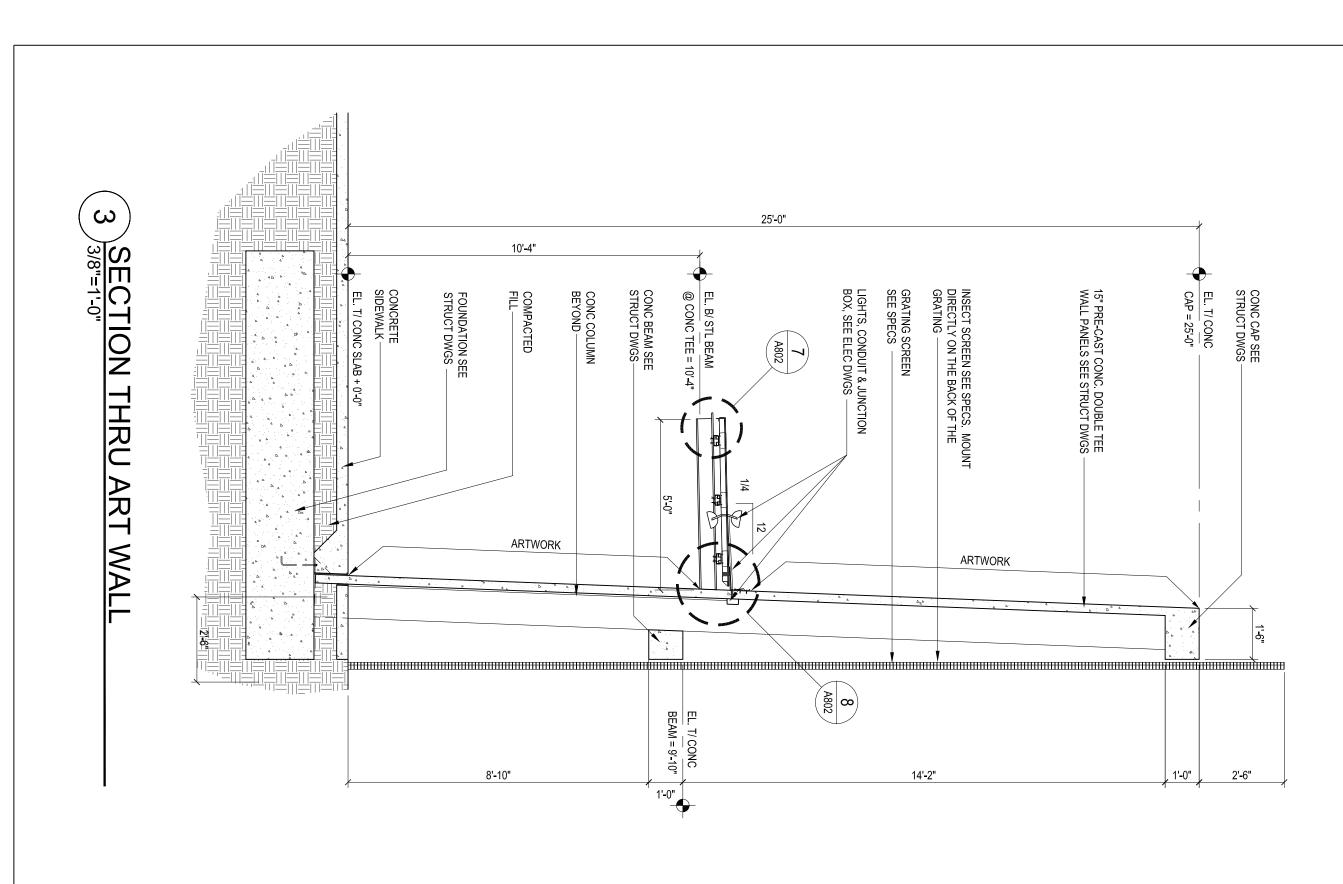

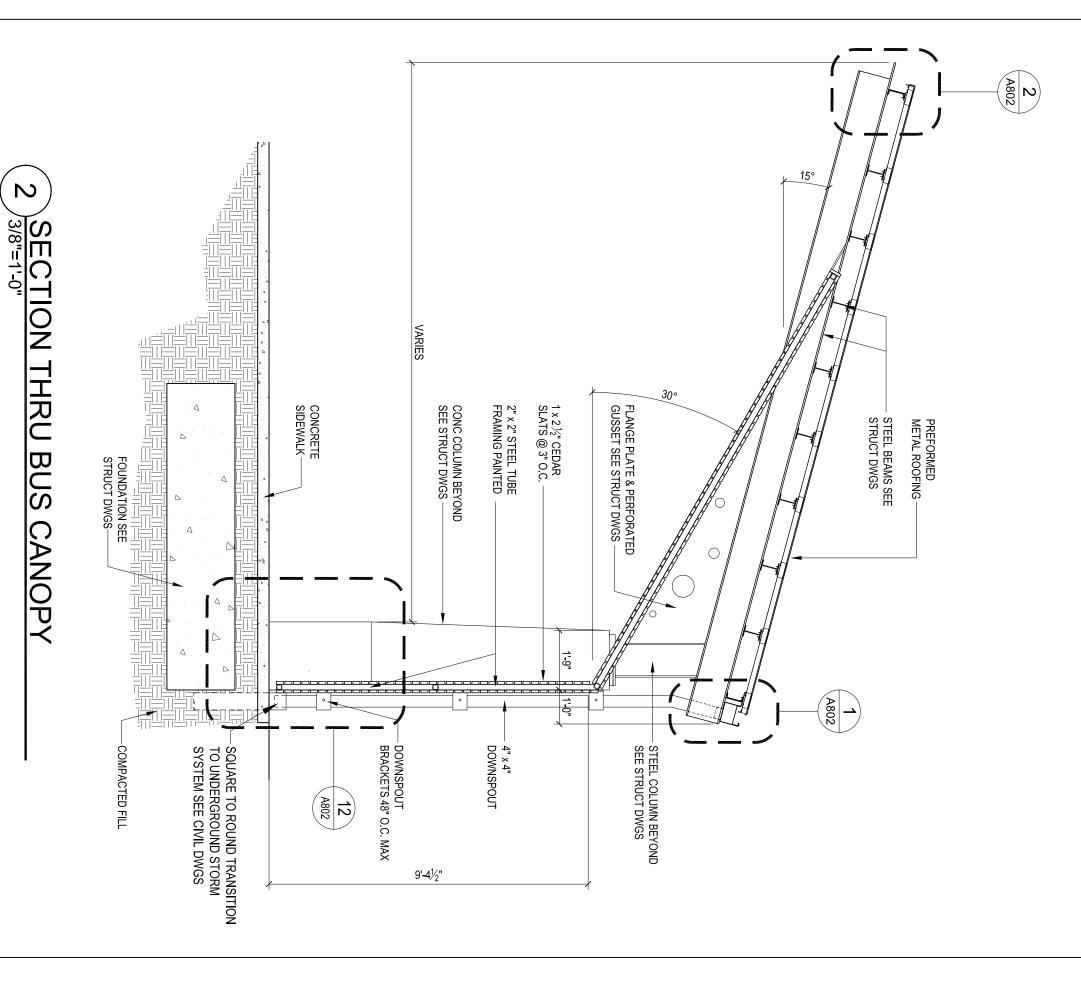

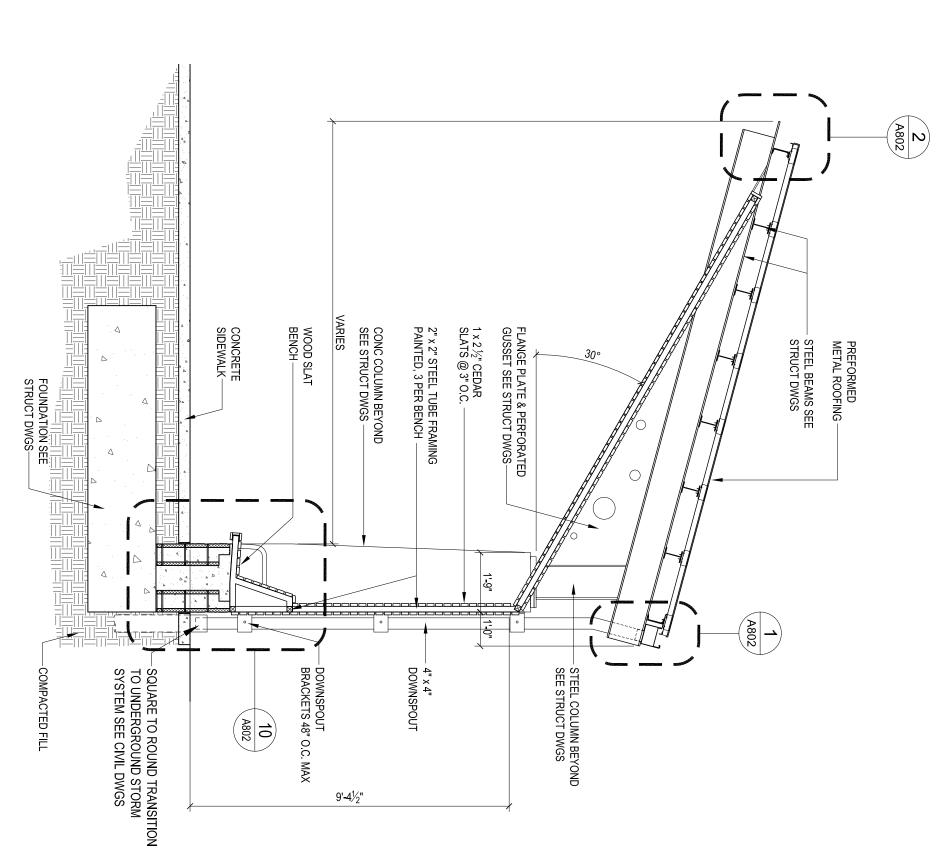



Bradenton 601 13th Street West Bradenton, FI 34205 Transit Station

Manatee County Government 1112 Manatee Ave West 8th Floor Bradenton, FI 34208

drawn: Jr
checked: Da
date: 11.12.10
comm. no.: 0920818 WALL SECTIONS

**M712** 

100% Construction Documents

SECTION THRU BUS CANOPY


(N)


677 North Washington Blvd.
Sarasota, Fl 34236
voice 941.952.5875
fax 941.957.3630
schenkelshultz.com
SS Lic No - AA-C000937 SCHENKELSHULTZ


DRAŽEN AHMEDIĆ


ARCHITECT

AR 94855

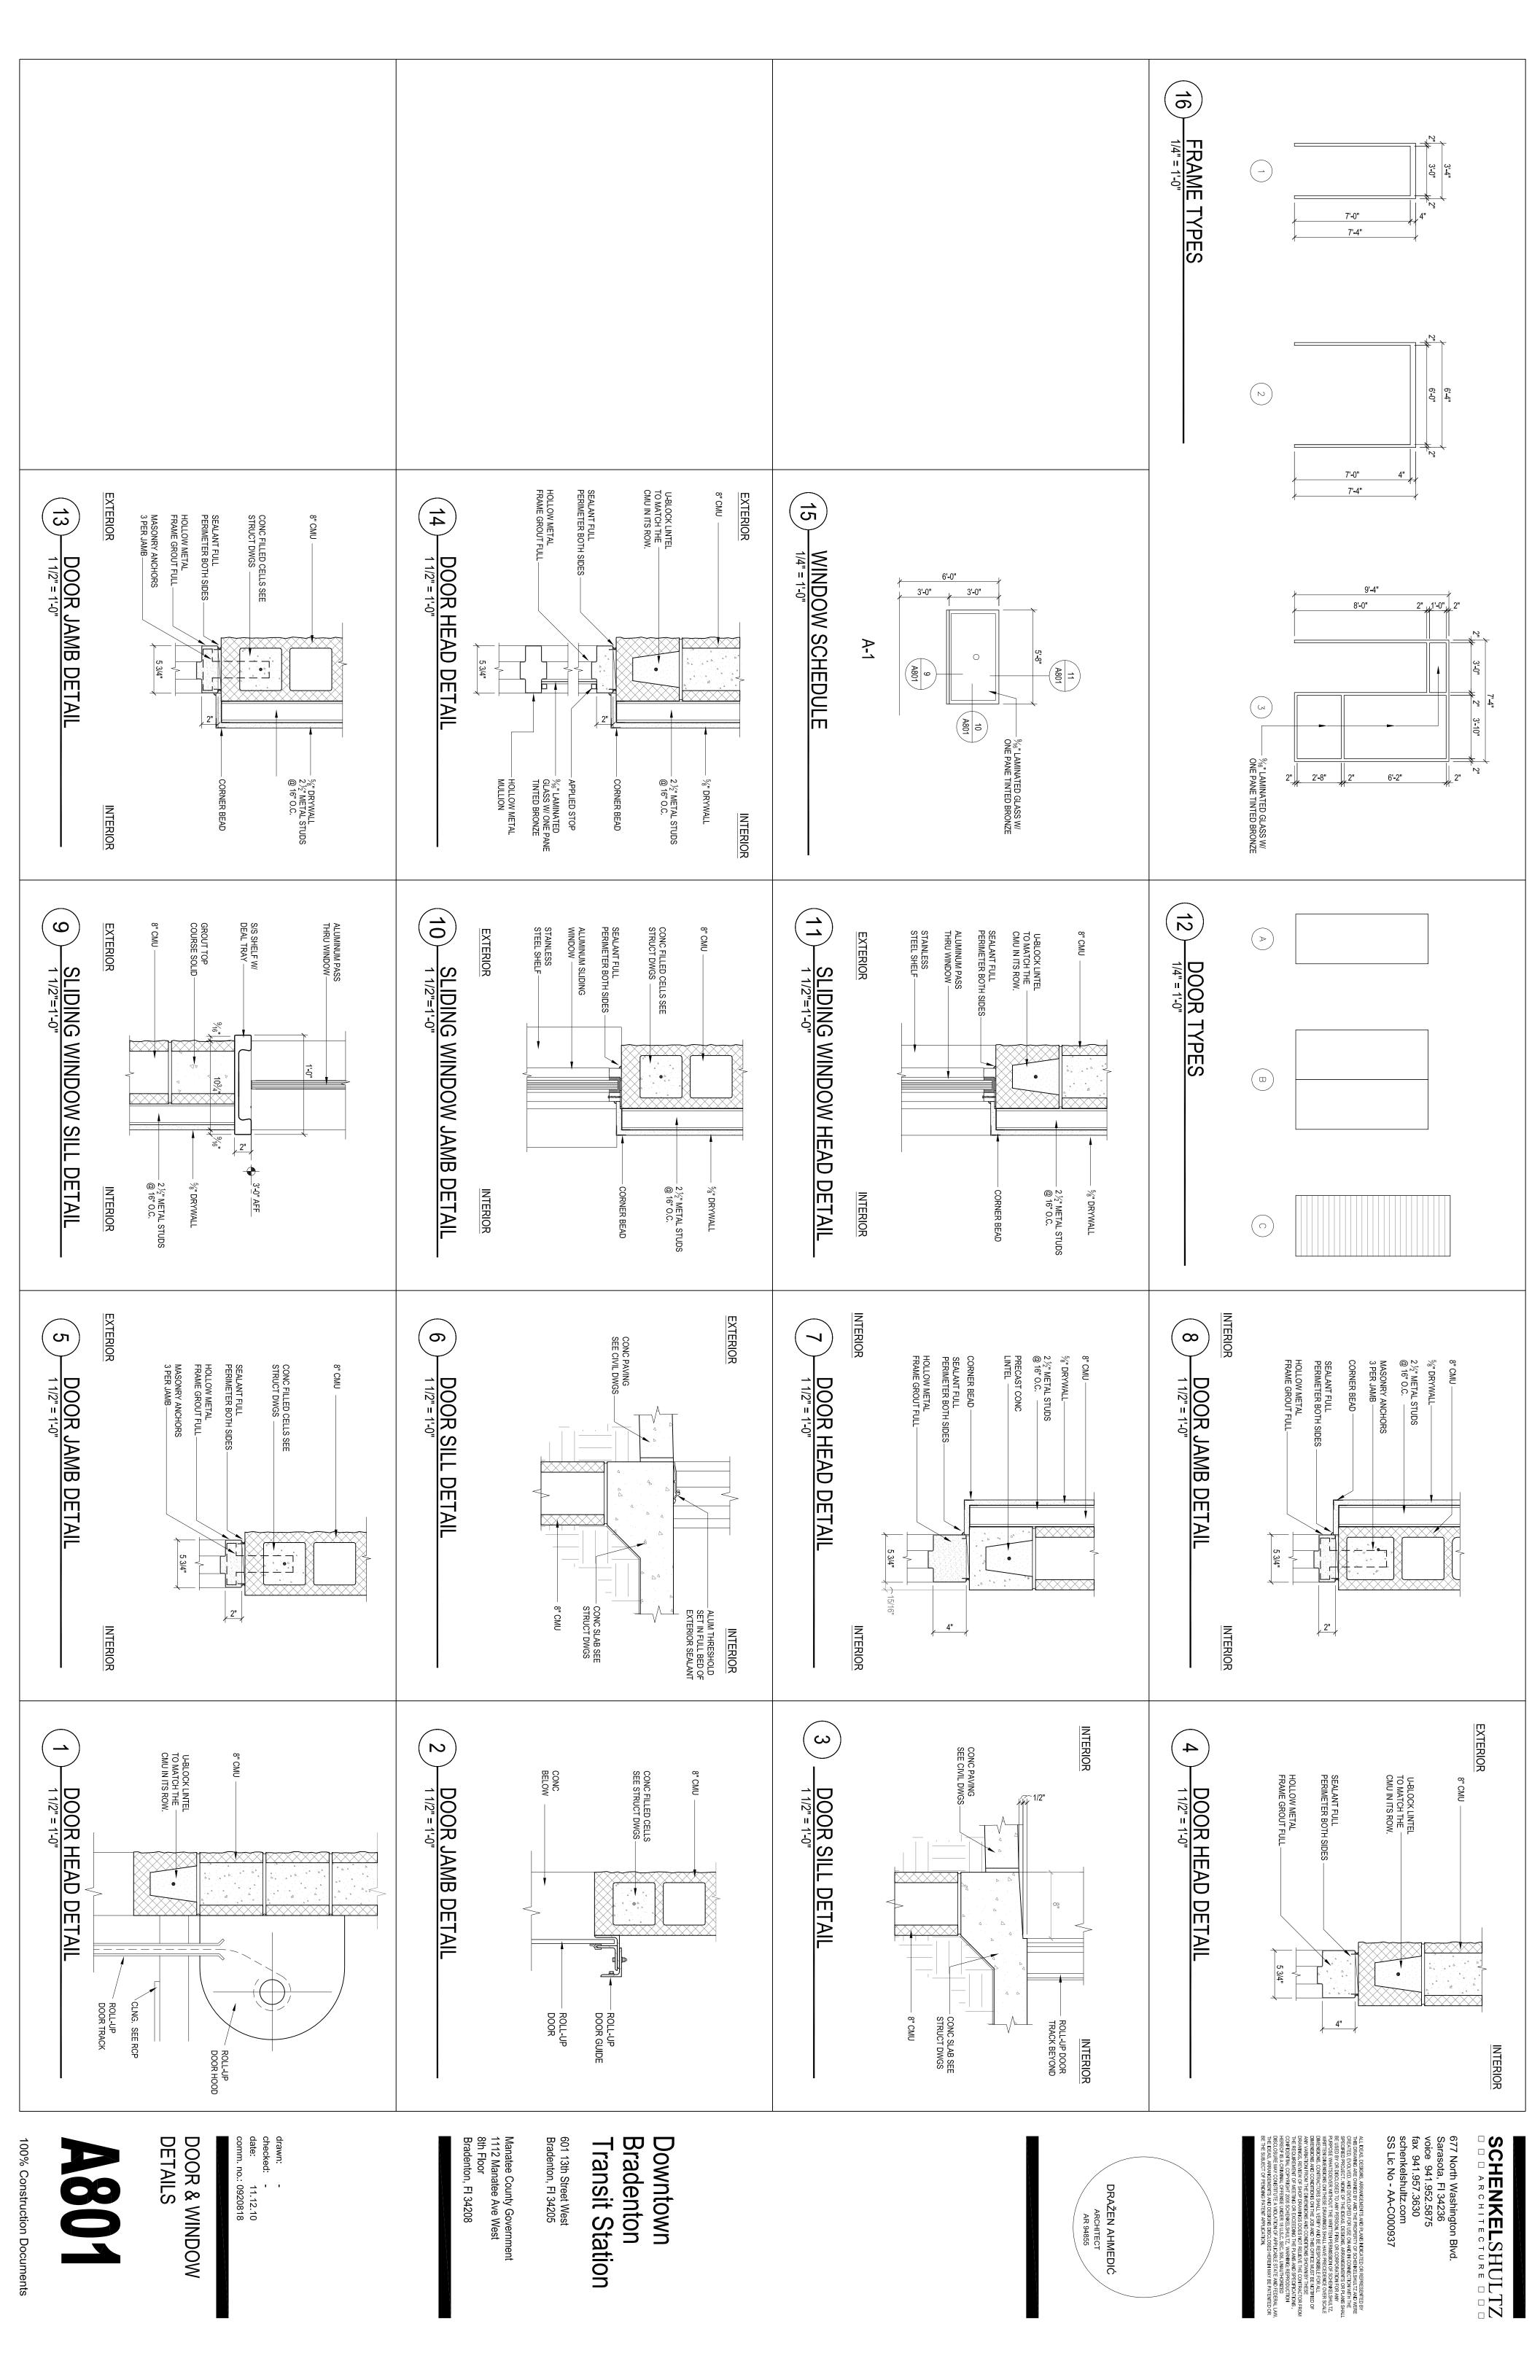

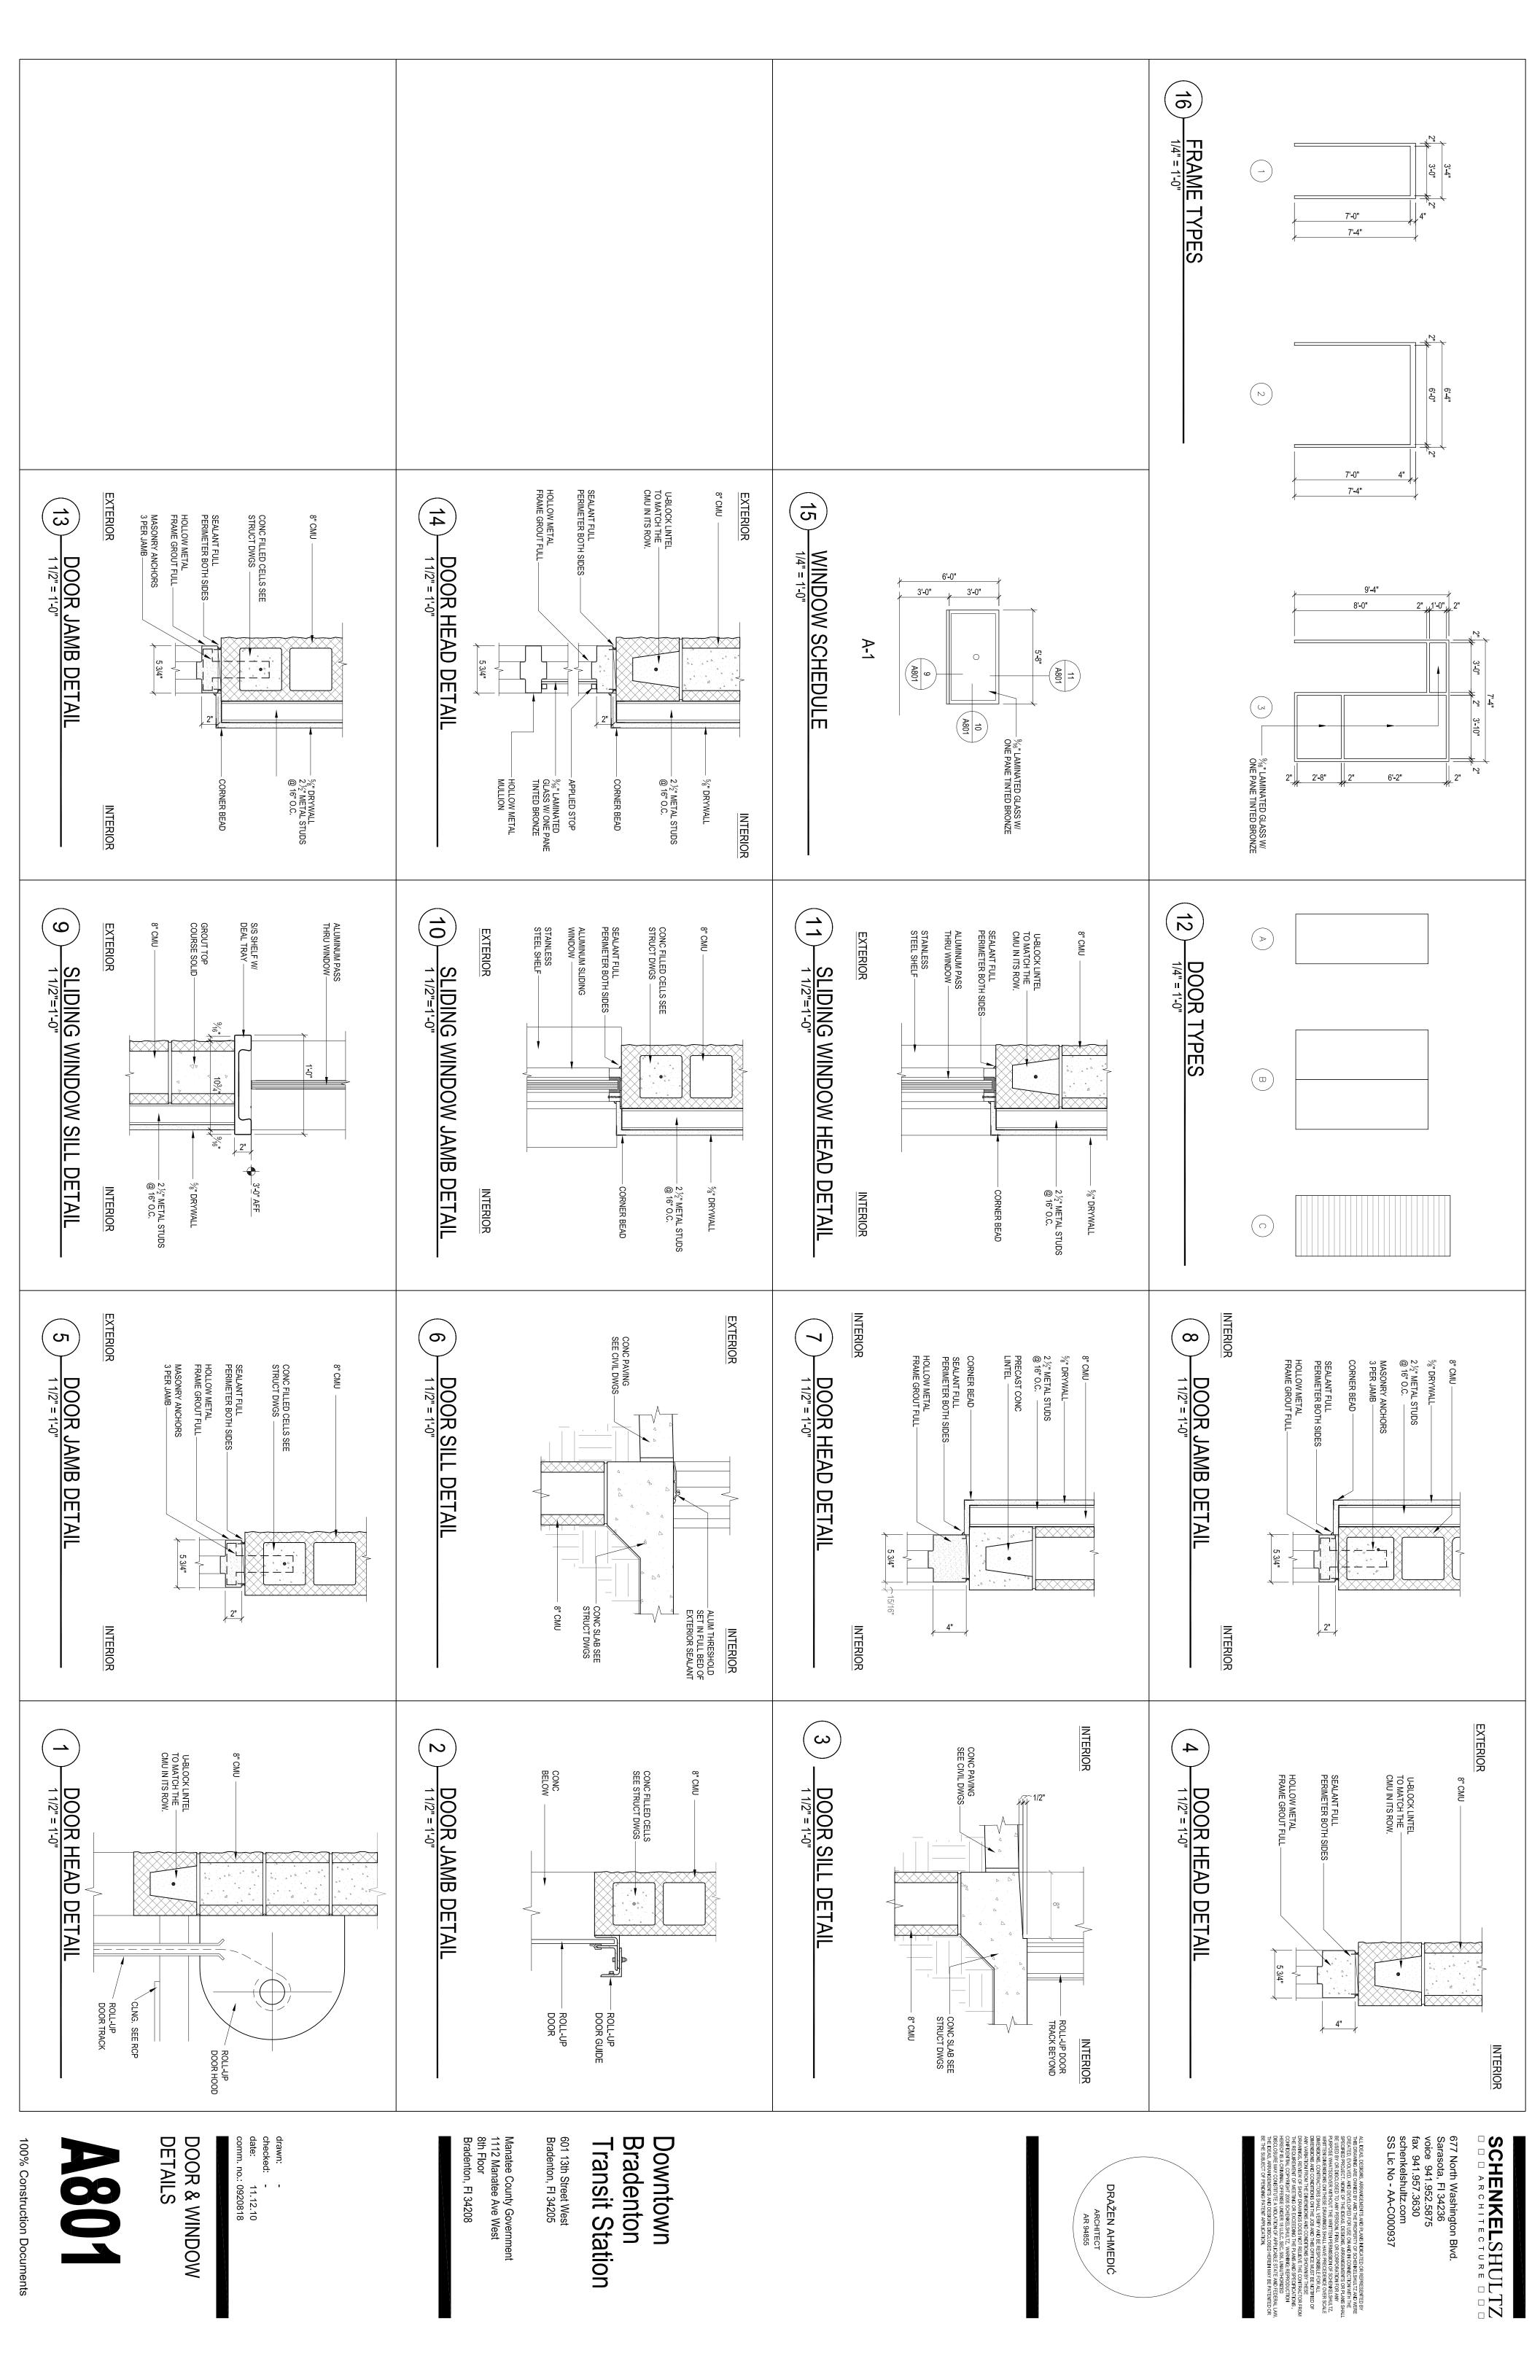

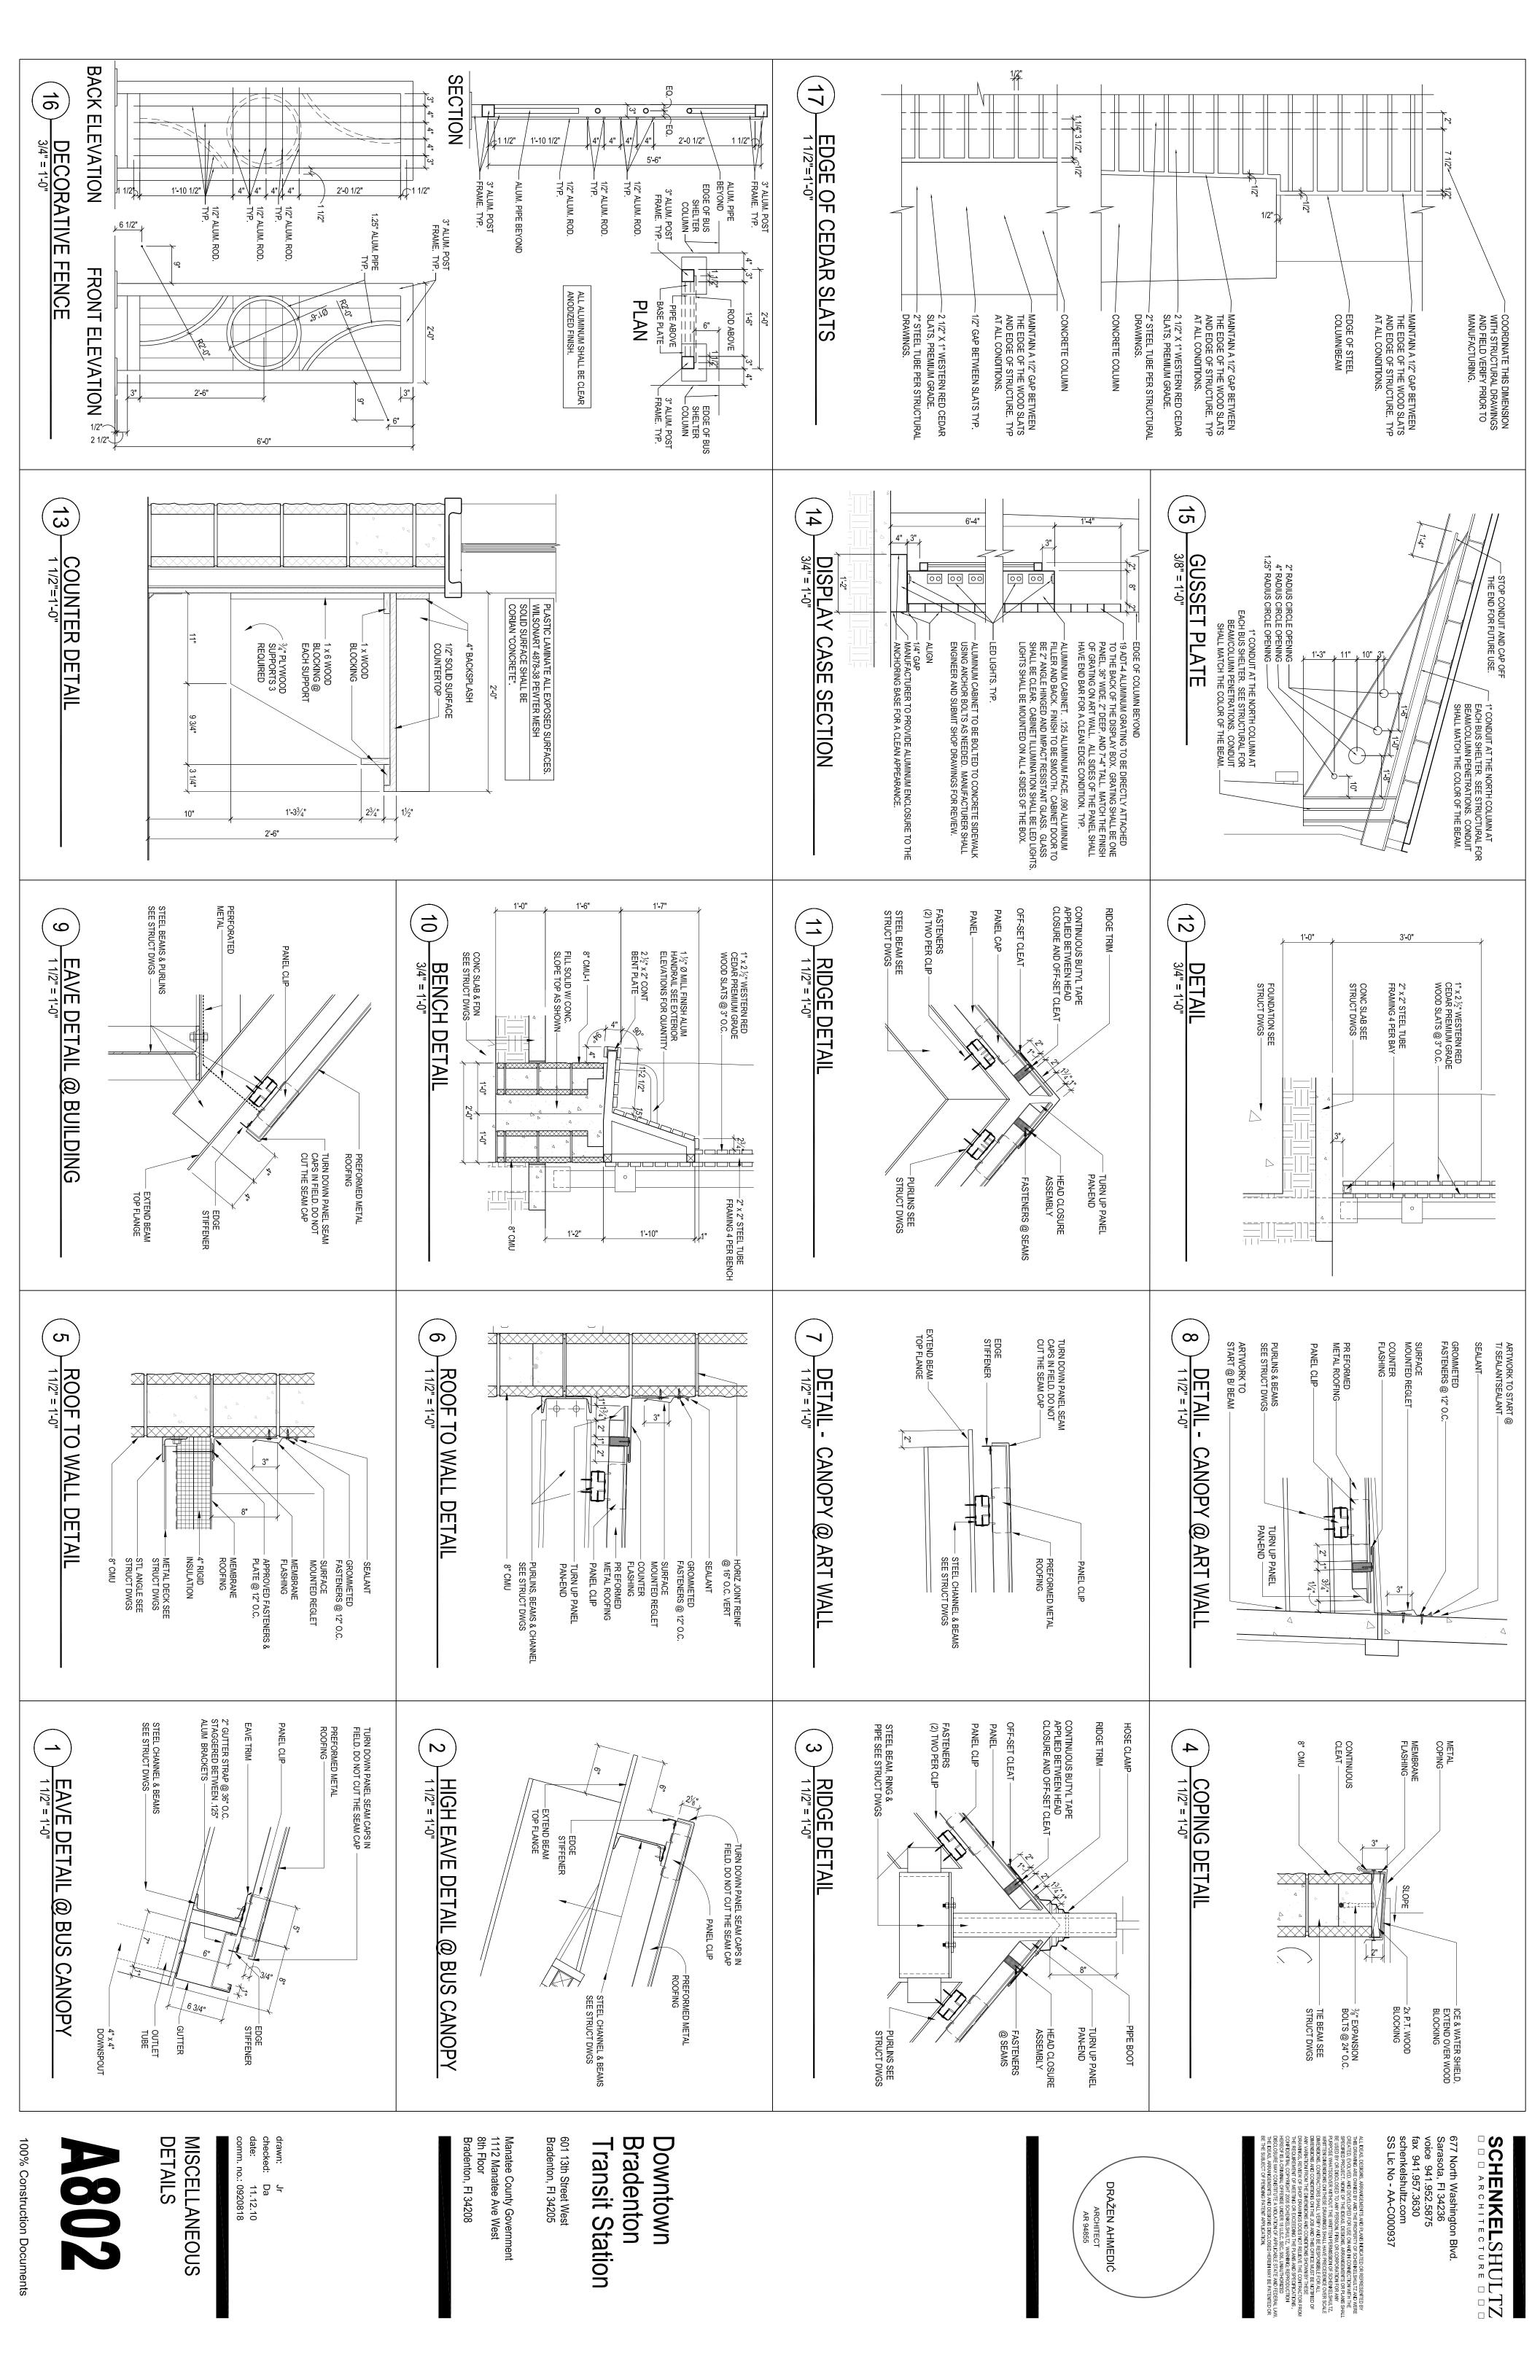

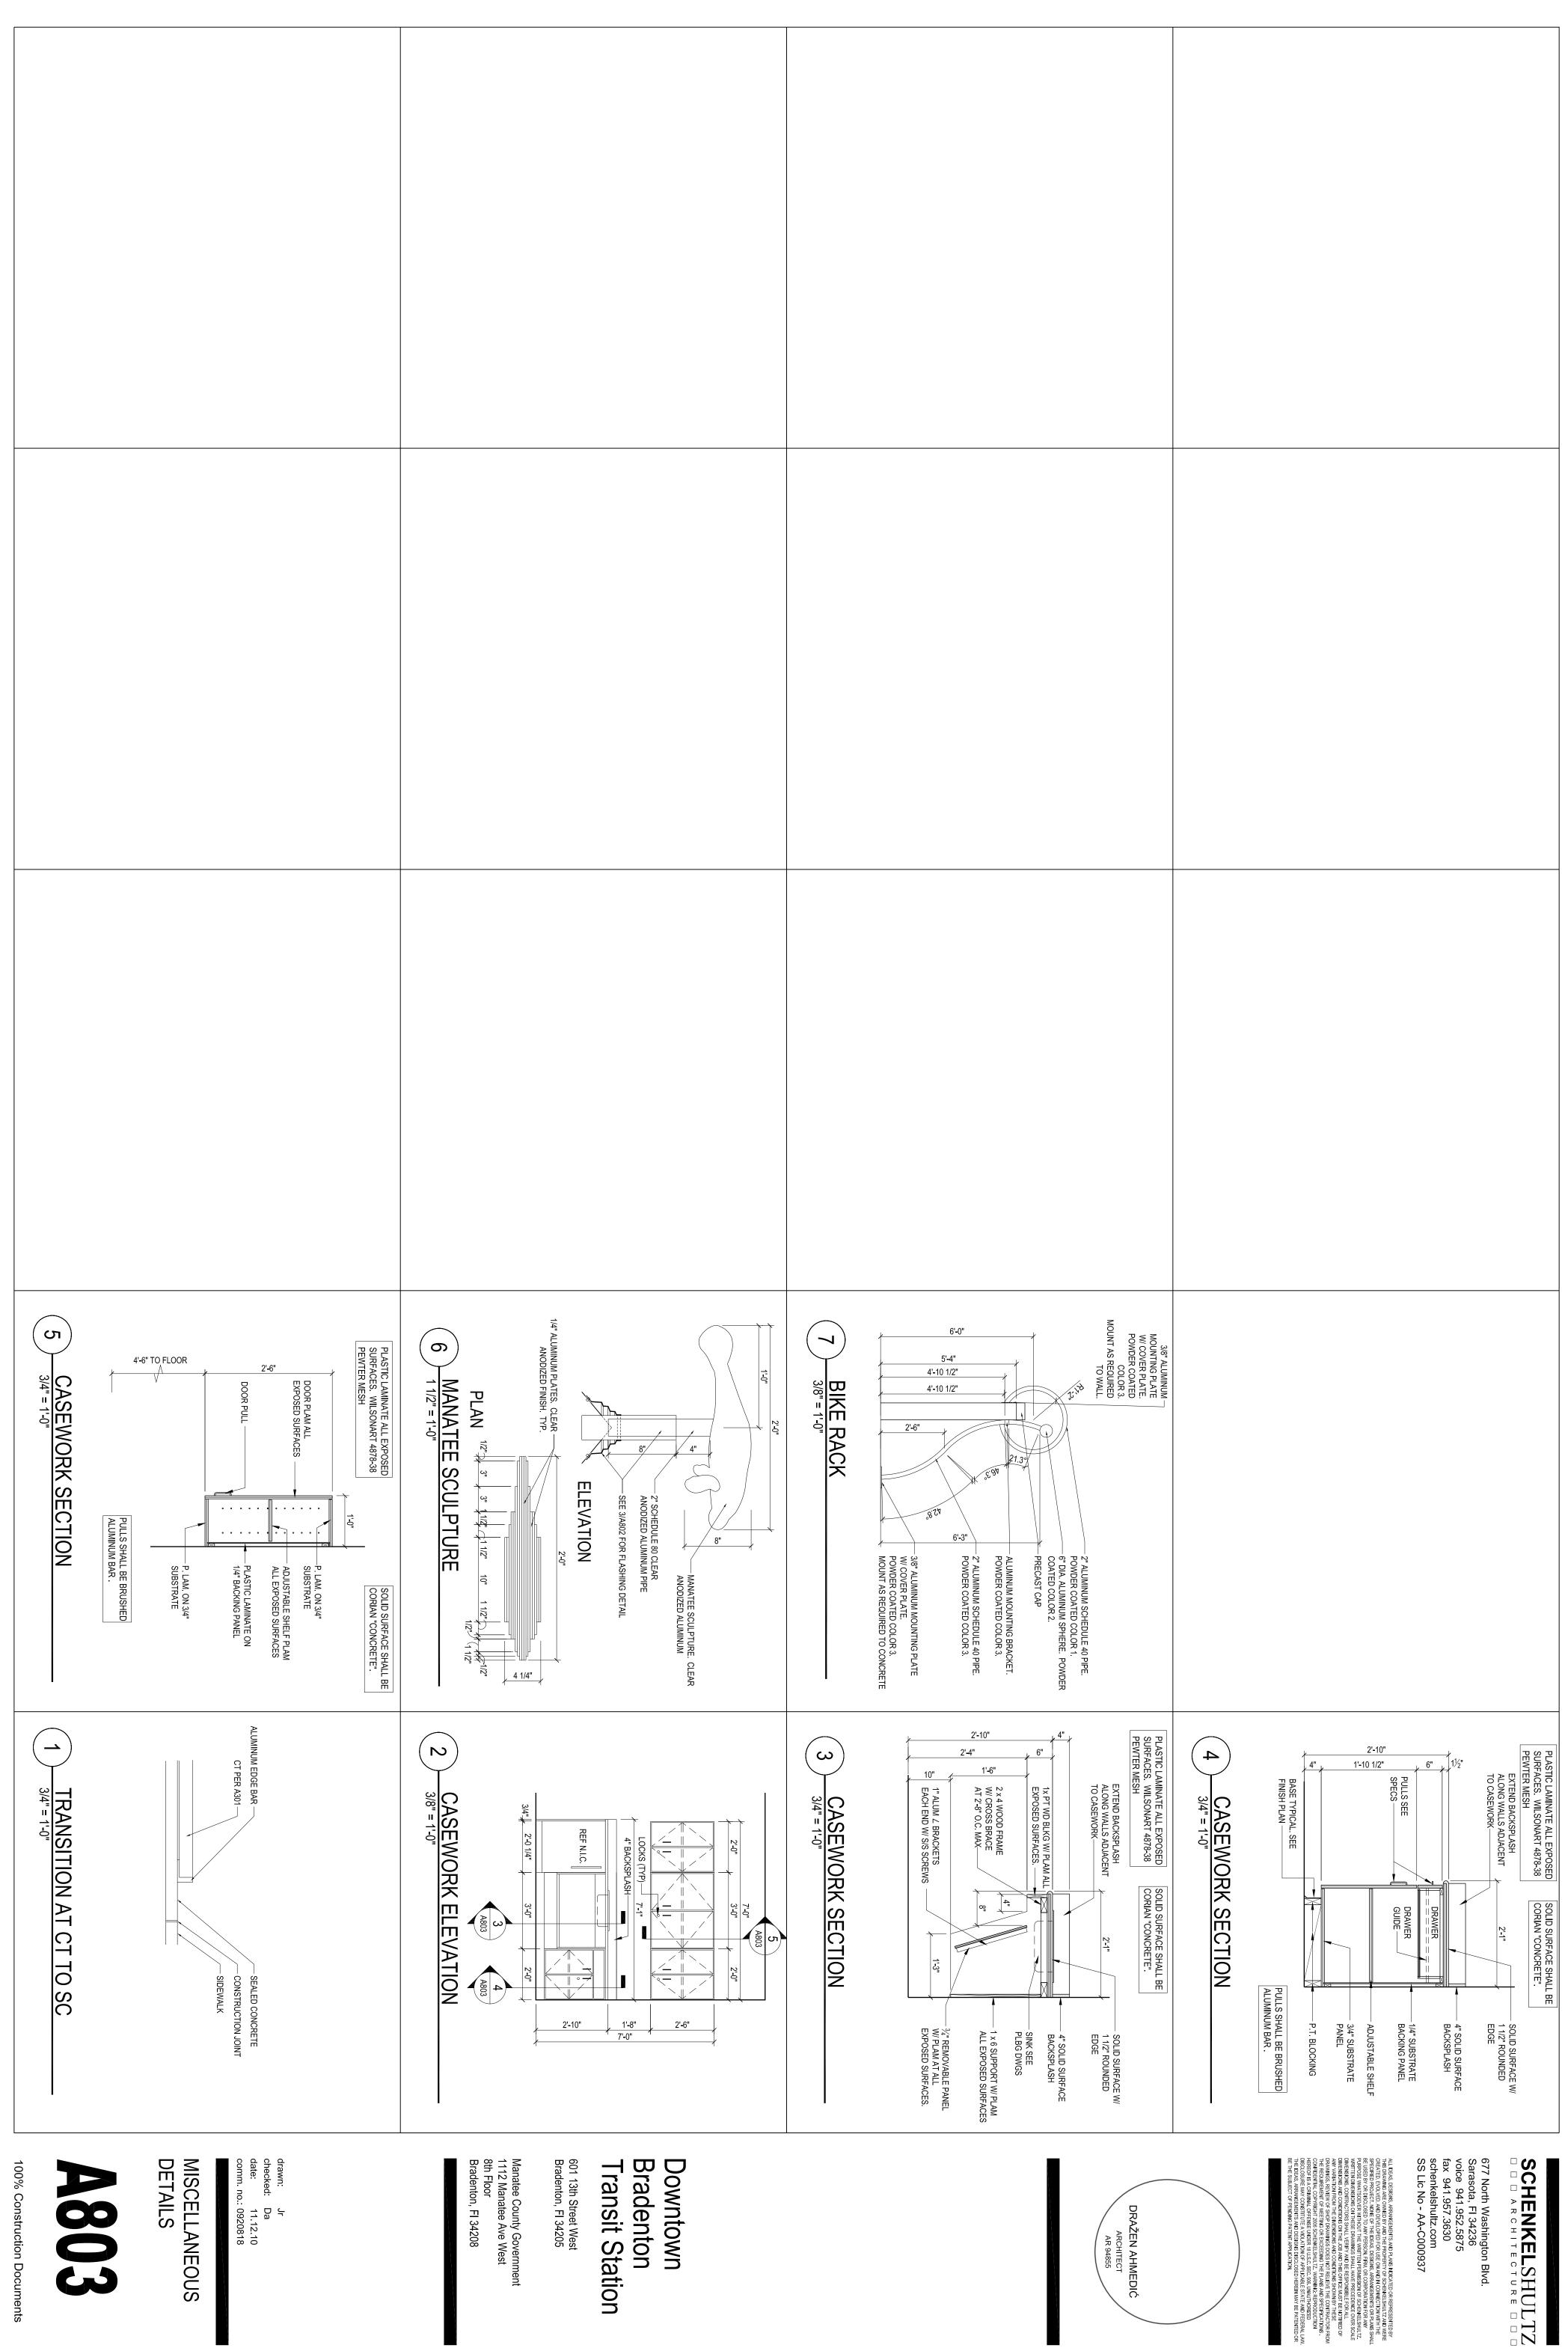

Bradenton Transit Station

Manatee County Government 1112 Manatee Ave West 8th Floor Bradenton, FI 34208

**MISCELLANEOUS** 

**A803**